
1st Avenue S. Public Parking Garage

60% DD



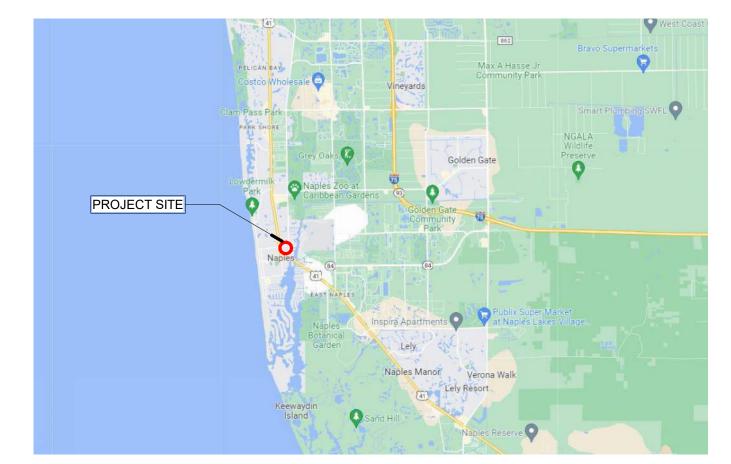

Vicinity Maps



Location Maps

Project Team

OWNER	CITY OF NAPLES	CIVIL ENG.	STANTEC CONSULTING SERVICES, INC
	ADDRESS: CITY HALL, 735 8TH STREET SOUTH NAPLES, FL 34102 PHONE # 239-213-7100		ADDRESS: 3510 KRAFT ROAD, SUITE 200, NAPLES, FL 34108 PHONE # 239 649-4040
ARCHITECT	BSSW ARCHITECTS, INC	LANDSCAPE ARCHITECT	GOETZ+STROPES LANDSCAPE ARCHITECTS, INC
	ADDRESS: 949 CENTRAL AVE, NAPLES, FL 34102 PHONE # 239-643-3103		ADDRESS: 1020 8TH AVENUE SOUTH #6 NAPLES FL 34102 PHONE # 239-643-0077
STRUCTURAL ENG.	DESMAN	MEP ENGINEER	TLC ENGINEERING SOLUTIONS
	ADDRESS: 100 SE THIRD AVE, 10TH FLOOR FORT LAUDERDALE, FL 33394 PHONE # 954 526 6464		ADDRESS: 13099 S CLEVELAND AVE SUITE 500, FORT MYERS, FL 33907 PHONE # (239) 275-4240




License # AA C001863

Phone: 239-278-3838 Fax: 239-275-5356

1st Avenue S.
Public Parking
Garage

Owner:
City of Naples

Consultant:

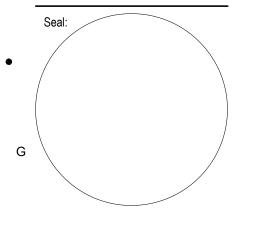

Design Development

Project #: 2204.01
Project Issued: June/20
Sheet Issued: 01-05-2

_		
•		
_		
D		
•		
С		
Ū		
	1	

Copyright © 2022. BSSW Architects, Inc. reserves copyright and other rights restricting these documents to the original site or purpose for which they were prepared. Reproductions, changes or assignments are

were prepared. Reproductions, changes or assignments are prohibited.

Sheet Title:

Cover Sheet

G0.01

GENERAL

Sheet #	Sheet Name	Sheet Issue Date	Current Revision Issued	Current Revision Date	Revision Description
G0.01	Cover Sheet	01-05-2023	No		
G0.02	Sheet Index	01-05-2023	No		
G0 03	General Information	01-05-2023	No		

CIVIL

	Sheet List -Civil					
Sheet Number	Sheet Name	Sheet Issue Date	Current Revision Issued	Current Revision Date	Current Revision Description	
C-1	Survey	01-05-2023	No			
CD101	Existing Condition and Demolition Plan	01-05-2023	No			
CE100	Erosion Control Plan and Details	01-05-2023	No			
CG100	Drainage Paving and Grading Plan	01-05-2023	No			
CG300	Cross Sections and Sections Map	01-05-2023	No			
CG500	Drainage Details	01-05-2023	No			
CG501	Paving Details	01-05-2023	No			
CS101	Zoning Data Sheet and Site Plan	01-05-2023	No			
CU100	Utility Plan	01-05-2023	No			
CU501	General and Water Details	01-05-2023	No			
GC000	Cover Sheet	01-05-2023	No			
GC001	General Notes	01-05-2023	No			

LANDSCAPE

Sheet#	Sheet Name	Sheet Issue Date	Current Revision Issued	Current Revision Date	Current Revision Description
		·			
LP - 1	Planting Plan	12-28-2022	No		
LP - 2	Planting Plan	12-28-2022	No		
LP - 3	Planting Plan	12-28-2022	No		
LP - 4	Planting Specifications	12-28-2022	No		
LP - 5	Planting Details	12-28-2022	No		
LP - 6	Planting Images	12-28-2022	No		

IRRIGATION

		Sheet Issue	Current	Current	Current Revision
Sheet #	Sheet Name	Date	Revision Issued	Revision Date	Description
IR-1	Irrigation Plan	12-23-2022	No		
IR-2	Irrigation Plan	12-23-2022	No		
IR-3	Irrigation Specifications	12-23-2022	No		
IR-4	Irrigation Details	12-23-2022	No		
IR-COV	Cover Sheet	12-23-2022	No		

ARCHITECTURE SITE PLAN

	Sheet List - Architecture Site Plan					
Sheet Number	Sheet Name	Sheet Issue Date	Current Revision Issued	Current Revision Date	Current Revision Description	
AS.01	Architectural Site Plan	01-05-2023	No			
AS.02	Architectural Site Plan Enlarged	01-05-2023	No			

LIFE SAFETY

Sheet #	Sheet Name	Sheet Issue Date	Current Revision Issued	Current Revision Date	Current Revision Description
L0.01	Code Analysis	01-05-2023	No		
Sheet #	Sheet Name	Sheet Issue Date	Current Revision Issued	Current Revision Date	Current Revision Description
A0.11	Life Safety Plan Ground Level	01-05-2023	No		
A0.12	Life Safety Plan Second Level	01-05-2023	No		
A0.13	Life Safety Plan Third Level	01-05-2023	No		
A0.14	Life Safety Plan Roof Level	01-05-2023	No		

ARCHITECTURE

					Ourient
		Sheet Issue	Current	Current	Revision
Sheet #	Sheet Name	Date	Revision Issued	Revision Date	Description
	1	1	1		
A0.11	Life Safety Plan Ground Level	01-05-2023	No		
A0.12	Life Safety Plan Second Level	01-05-2023	No		
A0.13	Life Safety Plan Third Level	01-05-2023	No		
A0.14	Life Safety Plan Roof Level	01-05-2023	No		
A1.02	SECOND FLOOR	01-05-2023	No		
A1.03	THIRD FLOOR	01-05-2023	No		
A1.04	ROOF LEVEL	01-05-2023	No		
A1.31	Roof Plan	01-05-2023	No		
A2.01	Elevations	01-05-2023	No		
A2.02	Elevations	01-05-2023	No		
A2.03	Elevations	01-05-2023	No		
A3.01	Building Sections	01-05-2023	No		
A3.02	Building Sections	01-05-2023	No		
A3.11	Wall Sections	01-05-2023	No		
A3.12	Wall Sections	01-05-2023	No		
A3.13	Wall Sections	01-05-2023	No		
A3.14	Wall Sections	01-05-2023	No		
A5.10	Exterior Details	01-05-2023	No		
A5.11	Exterior Details	01-05-2023	No		
A9.01	3D Views	01-05-2023	No		
A9.02	3D Rendering	01-05-2023	No		
A9.03	3D Rendering	01-05-2023	No		
A9.04	3D Rendering	01-05-2023	No		
A9.05	3D Rendering	01-05-2023	No		
A9.06	3D Rendering	01-05-2023	No		
A9.07	3D Rendering	01-05-2023	No		

STRUCTURE

Sheet #	Sheet Name	Sheet Issue Date	Current Revision Issued	Current Revision Date	Curre Revision Descrip
S001	Abbreviations, Design Criteria and General Notes	01-03-2023	No		
S002	General Notes	01-03-2023	No		
S003	General Notes	01-03-2023	No		
S005	Typical, Slab-on-Grade Details	01-03-2023	No		
S006	Typical, Slab-on-Grade Details	01-03-2023	No		
S101	Foundation Plan	01-03-2023	No		
S201	Grade Level (1) Slab-on-Grade Plan	01-03-2023	No		
S202	Level 2 Framing Plan	01-03-2023	No		
S203	Level 3 Framing Plan	01-03-2023	No		
S204	Level 4 (Roof) Framing Plan	01-03-2023	No		
S231	Skeletal Elevations	01-03-2023	No		
S232	Skeletal Elevations and Sections	01-03-2023	No		
S251	Stair-Elevator Enclosure Enlarged Plan	01-03-2023	No		
S252	Stair-Elevator Enclosure Enlarged Plan	01-03-2023	No		
S253	North Stair Enclosure Enlarged Plan	01-03-2023	No		
S301	Typical Precast Details	01-03-2023	No		
S302	Typical Precast Details	01-03-2023	No		
S303	Typical Precast Details	01-03-2023	No		
S304	Typical Precast Details	01-03-2023	No		
S305	Precast Sections and Details	01-03-2023	No		
S306	Typical Details	01-03-2023	No		
S307	Structural Steel Details	01-03-2023	No		
SP1.01	Level 1 Floor Plan	01-03-2023	No		
SP1.02	Level 2 Floor Plan	01-03-2023	No		
SP1.03	Level 3 Floor Plan	01-03-2023	No		
SP1.04	Level 4 Floor Plan	01-03-2023	No		
SP2.01	Striping Details	01-03-2023	No		

ELECTRICAL

					Current
		Sheet Issue	Current	Current	Revision
Sheet #	Sheet Name	Date	Revision Issued	Revision Date	Description
E0.01	Electrical Symbols, Legend, Notes and Index	12-16-2022	No		
E1.00	Electrical Site Plan	12-16-2022	No		
E1.01	Electrical Power Plan Ground Level	12-16-2022	No		
E1.02	Electrical Power Plan Second Level	12-16-2022	No		
E1.03	Electrical Power Plan Third Level	12-16-2022	No		
E1.04	Electrical Power Plan Roof Level	12-16-2022	No		
E2.01	Electrical Lighting Plan Ground Level	12-16-2022	No		
E2.02	Electrical Lighting Plan Second Level	12-16-2022	No		
E2.03	Electrical Lighting Plan Third Level	12-16-2022	No		
E2.04	Electrical Lighting Plan Roof Level	12-16-2022	No		
E6.00	Electrical Schedules & Risers	12-16-2022	No		
E6.01	Electrical Panel Schedules	12-16-2022	No		

MECHANICAL

Sheet#	Sheet Name	Sheet Issue Date	Current Revision Issued	Current Revision Description
M001	Mechanical Symbols, Legend and Notes	12-17-2022	No	
M1.03	Mechanical Floor Plan Third Level	12-17-2022	No	
M6.0	Mechanical Schedules	12-17-2022	No	

PLUMBING

Sheet#	Sheet Name	Sheet Issue Date	Current Revision Issued	Revision Description
P0.01	Plumbing Symbols, Legend, Notes and Index	12-17-2022	No	
P1.00	Plumbing Site Plan	12-17-2022	No	
P1.01	Fire Protection Symbols, Legend, Notes and Index	12-17-2022	No	
P1.02	Plumbing Floor Plan Ground Level	12-17-2022	No	
P1.03	Plumbing Floor Plan Second Level	12-17-2022	No	
P1.04	Plumbing Floor Plan Third Level	12-17-2022	No	
P1.05	Plumbing Floor Plan Roof Level	12-17-2022	No	
P6.0	Storm Riser	12-17-2022	No	

FIRE PROTECTION

Sheet#	Sheet Name	Sheet Issue Date	Current Revision Issued	Current Revision Description
FP0.01	Fire Protection Symbols, Legend, Notes and Index	09-23-2022	No	
FP1.0	Fire Protection Site Plan	09-23-2022	No	

FIRE ALARM

Sheet#	Sheet Name	Sheet Issue Date	Current Revision Issued	Revision Description
FA1.01	Fire Alarm Plan-Ground Level	09-23-2022	No	
FA1.02	Fire Alarm Plan-Second Level	09-23-2022	No	
FA1.03	Fire Alarm Plan-Third Level	09-23-2022	No	
FA1.04	Fire Alarm Plan-Roof Level	09-23-2022	No	
FA6.00	Fire Riser and Details	09-23-2022	No	

TECHNOLOGY

Sheet #	Sheet Name	Sheet Issue Date	Current Revision Issued	Current Revision Description
T0.01	Technology Symbols, Legends, Notes and Index	12-16-2022	No	
T1.01	Technology Plan Ground Level	12-16-2022	No	
T1.02	Technology Plan Second Level	12-16-2022	No	
T1.03	Technology Plan Third Level	12-16-2022	No	
T1.04	Technology Plan Roof Level	12-16-2022	No	
T4.01	Technology Enlarged Plans	12-16-2022	No	
T7.01	Technology Details and Risers	12-16-2022	No	

CCTV

Sheet #	Sheet Name	Sheet Issue Date	Current Revision Issued	Revision Description
CCTV.1	Ground Level - CCTV Camera Location Plan	01-12-2023	No	
CCTV.2	Second Level - CCTV Camera Location Plan	01-12-2023	No	
CCTV.3	Third Level - CCTV Camera Location Plan	01-12-2023	No	
CCTV.4	Roof Level - CCTV Camera Location Plan	01-12-2023	No	

SIGNAGE

Sheet #	Sheet Name	Sheet Issue Date	Current Revision Issued	Revision Description
SIGN.01	Site Signage Plan	01-12-2023	No	
SIGN.02	Exterior Details	01-12-2023	No	



1500 Jackson Street, Suite 200 Fort Myers, Florida 33901 Phone: 239-278-3838 Fax: 239-275-5356


949 Central Ave.
Naples, Florida 34102
Phone: 239-643-3103 Fax: 239-643-7435

Drainati

1st Avenue S. Public Parking Garage

Owner:
City of Naple

Consultant:

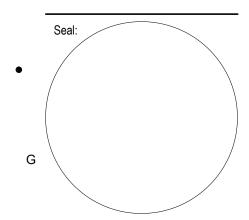

Design Development

Project #: 2204.01
Project Issued: June/2022
Sheet Issued: 01-05-2023

Е	No	Date	Revision
•			
D			
_			
•			
С			
O			
•			

Copyright © 2022. BSSW Architects, Inc. reserves copyright and other rights restricting these documents to the original site or purpose for which they were prepared. Reproductions, changes or assignments are

Sheet Title:
Sheet Index

Sheet No.

Autodesk Docs://2204.01 - Naples Playhouse Parking Garage/2204.01 - 1st Avenue S. Public Parking Garage_R-22.rvt 1/12/2023 5:58:51 PM

G0.02

13. STANDARD FOR PORTABLE FIRE EXTINGUISHERS (NFPA 10) 2018 EDITION

14. STANDARD FOR PARKING STRUCTURES

	1. BUILDING SUMMARY							
	Building Summary Category	FBC	FFPC					
		-						
•	LEVEL OF WORK	NEW CONSTRUCTION						
	NUMBER OF LEVELS	3	3					
	OVERALL SF:							
	CONSTRUCTION TYPE	TYPE II-B						
	BUILDING FULLY SPRINKLERED	YES	YES					
K	OCCUPANCY [FBC CHPT. 4/FFPC CHPT. 6]	OPEN AIR PARKING GARAGE	OPEN PARKING STRUCTURES					

(NFPA 88A) 2019 EDITION

	AREA CALCULATIONS	GROSS SQ. FT	OCCUPANCY
•	Ground Level Second Level	34,399 34,239	34,399 / 200 Gross = 172 34,239 / 200 Gross = 172
	Third Level	34,239	34,239 / 200 Gross = 172
	Roof Level	20,269	20,269 / 200 Gross = 102
	TOTAL	123,146	621 OCCUPANTS

	TABLE 406.5.4OPEN PARKING GARAGES AREA AND HEIGHT									
	TYPE II-B	ALLOWABLE	PROVIDED							
•		•								
	AREA PER TIER	50,000 SF	34,399 SF							
	HEIGH IN TIERS (RAMP ACCESS)	8 TIERS	4 TIERS							

C. BUILDING HEIGHT CALCULATIONS FBC 504.3 & 504.4												
	CONSTRUCTION TYPES						ALLOWED HT. (FEET)					
•	BLDG	FBC	FFPC	FBC	FFPC	FBC	FFPC	PROPOSED HT. (STORIES)	FBC	FFPC	PROPOSED HT. (FEET) FBC	COMMENTS
	PARKING GARAGE	II-B		S-2		4		3	75'-0"	47'-10"		

G	1. MAJOR BUILDING ELEMENTS (PER FBC T601)								
	BLDG ELEMENT	FBC	FFPC	PROPOSED RATING	ASSEMBLY (UL)				
•	a. PRIMARY STRUCTURE FRAME (BEAMS, GIRDERS, COLUMNS,	0	8.2.1.2	0					
	TRUSS)								
	b. BEARING WALLS (EXTERIOR)	0	8.2.1.2	0					
	c. BEARING WALLS (INTERIOR)	0	8.2.1.2	0					
	d. NON BEARING WALLS/PARTITIONS (EXTERIOR)	0	8.2.1.2	0					
F	e. NON BEARING WALLS/PARTITIONS (INTERIOR)	0	8.2.1.2	0					
	f. FLOOR CONSTRUCTION (AND SECONDARY MEMBERS)	0	8.2.1.2	0					
	g. ROOF CONSTRUCTION (AND SECONDARY MEMBERS)	0	8.2.1.2	0					

	Space Occ	cupancy Classifica	ation	
Classification	Area Per Occupant. Per FBC T1004.1.1	Area per Occupant Per FFPC 7.3.1.2	Occupancy Gross or Net	Proposed Occupancy
Accessory Storage, Mech, Elec & Comm.	300 SF	300 SF	Gross	
Agricultural building	300 SF	300 31	Gross	
Aircraft Hangars	500 SF		Gross	
Airport Terminals - Baggage Claim	20 SF		Gross	
Airport Terminals - Baggage Handling	300 SF		Gross	
Airport Terminals - Concourse	100 SF		Gross	
Airport Terminals - Waiting Areas	15 SF		Gross	
Assembly - Gaming Floors (keno, slots, etc.)	11 SF		Gross	
Assembly with fixed seats			0.000	
Assembly without fixed seats - Concentrated	7 SF	7 SF	Net	
Assembly without fixed seats - Standing Space	5 SF		Net	
Assembly without fixed seats - Unconcentrated	15 SF	15 SF	Net	
Business areas	100 SF	100 SF	Gross	
Educational - Classroom area	20 SF		Net	
Educational - Shops and other Vocational	50 SF		Net	
Excercise Rooms	50 SF		Gross	
Excercise Rooms with Equipment	50 SF	50 SF	Gross	
Excercise Rooms without Equipment	15 SF	15 SF	Gross	
Institutional (Sleeping)	120 SF	120 SF	Gross	
Kitchens, commerical	200 SF	100 SF	Gross	
Library - Reading rooms	50 SF		Net	
Library - Stack area	100 SF		Gross	
Locker Rooms	50 SF	50 SF	Gross	
Mercantile	60 SF	30 SF		
Parking	200 SF		Gross	200 SF
Pool (Deck)	30 SF	30 SF	Net	
Pool (Wet)	50 SF	50 SF	Net	
Residential	200 SF	200 SF	Gross	
Stage	15 SF		Net	
Storage, stock, shipping areas	300 SF		Gross	300 SF

			2	. EXTERIOR	WALLS, LOA	D BEARING (PE	R FBC T602	& FFPC CHAP	T. 8.2.1.2)			
				2.1 M	OST RESTRI	CTIVE OCCUPAN	NCY: FBC - I	-2 & FFPC - xxx	X			
				2.2	EXTERIOR W	VALLS (LOAD BE	ARING)					
							ALLOWED			PROPOSED		
	a) DIST. TO PROPERTY LINE	c) RATING PER FBC	d) RATING PER FFPC	f) PROPOSED RATING	g) ASSEMBLY	h) PROTECTION	i) % OPEN	j) AREA [b * i]	k) PROTECTION	I) % OPEN	m) AREA [b	n) ASSEMBLY
NORTH	20' 40"	0 HR		0 HR								
EAST	17'-0"	0 HR		0 HR								
SOUTH		0 HR		0 HR								
WEST	1'-4"	1 HR		2HR								

3.2 INCIDENTAL ACCESSORY OCCUPANCY								
USE	SEPERATION PER FBC T508.2.5	SEPERATION PER FFPC	PROPOSED SEPERATION					
a)I . T ROOM	0		0					
b)ELECTRICAL ROOM	0		0					
c)FIRE ROOM	0		0					
d)								
e)								
f)								
g)								
h)								

3.3 EGRESS / LIFESAFETY SEPERATIONS									
PROTECTION OF OPENINGS PER 715.4 PER FBC REQ. RATING FBC (IN HRS.) PER FFPC REQ. RATING FFPC OPENINGS PER FFPC PROPOSED RA									
FIRE WALL	2HR								
SHAFT ENCLOSURE									

OPENNESS REQUIREMENT CALCULATIONS FBC 406.5.2

PERIMETER OF PARKING GARAGE
(2) SIDES @ 274' = 548'
(2) SIDES @ 124' = 248'
TOTAL = 796'

WALL AREA EACH LEVEL = 792'x11' = 8,756 sq. ft./level

OPENING SQUARE FOOTAGE LEVELS Ground, 2nd and 3rd Level

60% OPENNESS REDUCTION PERFORATED METAL PANEL (2ND AND THIRD LEVELS)

				(ZIVD AIVD ITHIN
	EAST ELEVATION =	Ground	520 S.F.	520 S.F.
		2nd	467 S.F.	168 S.F.
		3rd	374 S.F.	149 S.F.
	WEST ELEVATION =	Ground	0 S.F.	
		2nd	0 S.F.	
		3rd	0 S.F.	
_	NORTH ELEVATION =	Ground	2115 S.F.	2115 S.F.
		2nd	1380 S.F.	552 S.F.
		3rd	1380 S.F.	552 S.F.
	SOUTH ELEVATION =	Ground	1100 S.F	1100 S.F
		2nd	1371 S.F.	548 S.F.
-		3rd	1252 S.F.	500 S.F.
4	TOTAL	=	9,959 S.F.	6113 S.F

SUMMARY TOTAL WALL AREA/LEVEL 8,756 S.F. OPEN AREA/LEVEL 2037 S.F. OPEN AREA 23.26%

2. LIFESAFETY REQUIREMENTS (SPRINKLERED/UNSPRINKLERED)

2.1 MAX. TRAVEL DISTANCE							
OCCUPANCY TYPE	FBC	FBC REF.	FFPC	FFPC REF.	PROPOSED		
STORAGE S-2	400 FT	1017.2	400 FT	T42.2.6	SEE LIFE SAFETY PLAN		

	2.2 COMMON PATH OF TRAVEL							
Key Name	Key Name OCCUPANCY TYPE FBC FBC REF. FFPC FFPC REF. PROPOSED							
1	STORAGE S-2	100 FT	1006.2.1	100 FT	T 42.2.5	SEE LIFE SAFETY PLAN		

	2.3 DEAD END CORRIDOR								
OCCUPANCY TYPE	FBC	FBC REF.	FFPC	FFPC REF.	PROPOSED				
STORAGE S-2	50 FT	1020.4	100 FT	T 42.2.5	SEE LIFE SAFETY				

	2.4 EGRESS WIDTH LEVEL								
OCCUPANCY TYPE	FBC	FBC REF.	FFPC	FFPC REF.	PROPOSED				
STORAGE S-2	0.2"/ Occup.	1005.3.2	0.2"/ Occup.	7.3.3.1	SEE LIFE SAFETY PLAN				

		2.5 EGRESS	(WIDTH)		
OCCUPANCY TYPE	FBC	FBC REF.	FFPC	FFPC REF.	PROPOSED
STORAGE S-2	0.3"/ Occup.	1005.3.1	0.3"/ Occup.	7.3.3.1	SEE LIFE SAFET

	2.6 MIN. CORRIDOR WIDTH								
OCCUPANCY TYPE FBC FBC REF. FFPC FFPC REF. PROPOSED									
STORAGE S-2	44	1005.1&1020.2	36"/44"	7.3.4.1 & 42.2	SEE LIFE SAFETY PLAN				

		2.7 MIN. OPENI	NG WIDTH		
OCCUPANCY TYPE	FBC	FBC REF.	FFPC	FFPC REF.	PROPOSED
STORAGE S-2	32"	1010.1 & 1022.2	32"	7.2.1.2.3.2	SEE LIFE SAFETY PLAN

		2.8 MAX. OPENII	NG WIDTH		
OCCUPANCY TPYE	FBC	FBC REF.	FFPC	FFPC REF.	PROPOSED
					•
STORAGE S-2	48"	1010.1.1		7.2.1.2	SEE LIFE SAFETY PLAN

		2.9 MIN. STAII	R WIDTH		
OCCUPANCY TYPE	FBC	FBC REF.	FFPC	FFPC REF.	PROPOSED
STORAGE S-2	44"	1009.3 &	44"	7.2.2.2.1.2	

F. FIRE EXTINGUISHER REQUIREMENTS - NFPA 10, TABLE E.3.4, PG. 10-40							
MAXIMUM TRAVEL	DISTANCE TO EXT	INGUISHER IS 75 FEET	, SEE LIFESAFETY PLAN FO	R LOCATIONS			
			NO. OF FIRE EXTING	UISHERS			
HAZARD TYPE	CLASS A RATING	TOTAL AREA (IN SF.)	REQ'D (AREA / AREA PER EXTIN.)	PROVIDED			
GROUND LEVEL	ORDINARY HZD-10A	34895 SF	34,895/11250=4	SEE LIFE SAFETY PLAN			
SECOND LEVEL	ORDINARY HZD-10A	34735 SF	34735/11250=4	SEE LIFE SAFETY PLAN			
THIRD LEVEL	ORDINARY HZD-10A	34735 SF	34735/11250=4	SEE LIFE SAFETY PLAN			
ROOF LEVEL	ORDINARY HZD-10A	20765 SF	20765/11250=2	SEE LIFE SAFETY PLAN			



License # AA C001863

1500 Jackson Street, Suite 200
Fort Myers, Florida 33901
Phone: 239-278-3838 Fax: 239-275-5356

949 Central Ave.
Naples, Florida 34102
Phone: 239-643-3103 Fax: 239-643-7435

Project:

1st Avenue S. Public Parking Garage

Owner:
City of Naples

Consultant:

Seal:

Design Development

Project #: 2204.01
Project Issued: June/2022
Sheet Issued: 01-05-2023

Ε	No	Date	Revision
•			
D			
•			
С			


Copyright © 2022. BSSW Architects, Inc. reserves copyright and other rights restricting these documents to the original site or purpose for which they were prepared. Reproductions, changes or assignments are

Sheet Title:
Code Analysis

A Sheet No.

Autodesk Docs://2204.01 - Naples Playhouse Parking Garage/2204.01 - 1st Avenue S. Public Parking Garage_R-22.rvt 1/12/2023 5:48:49 PM

L0₋01

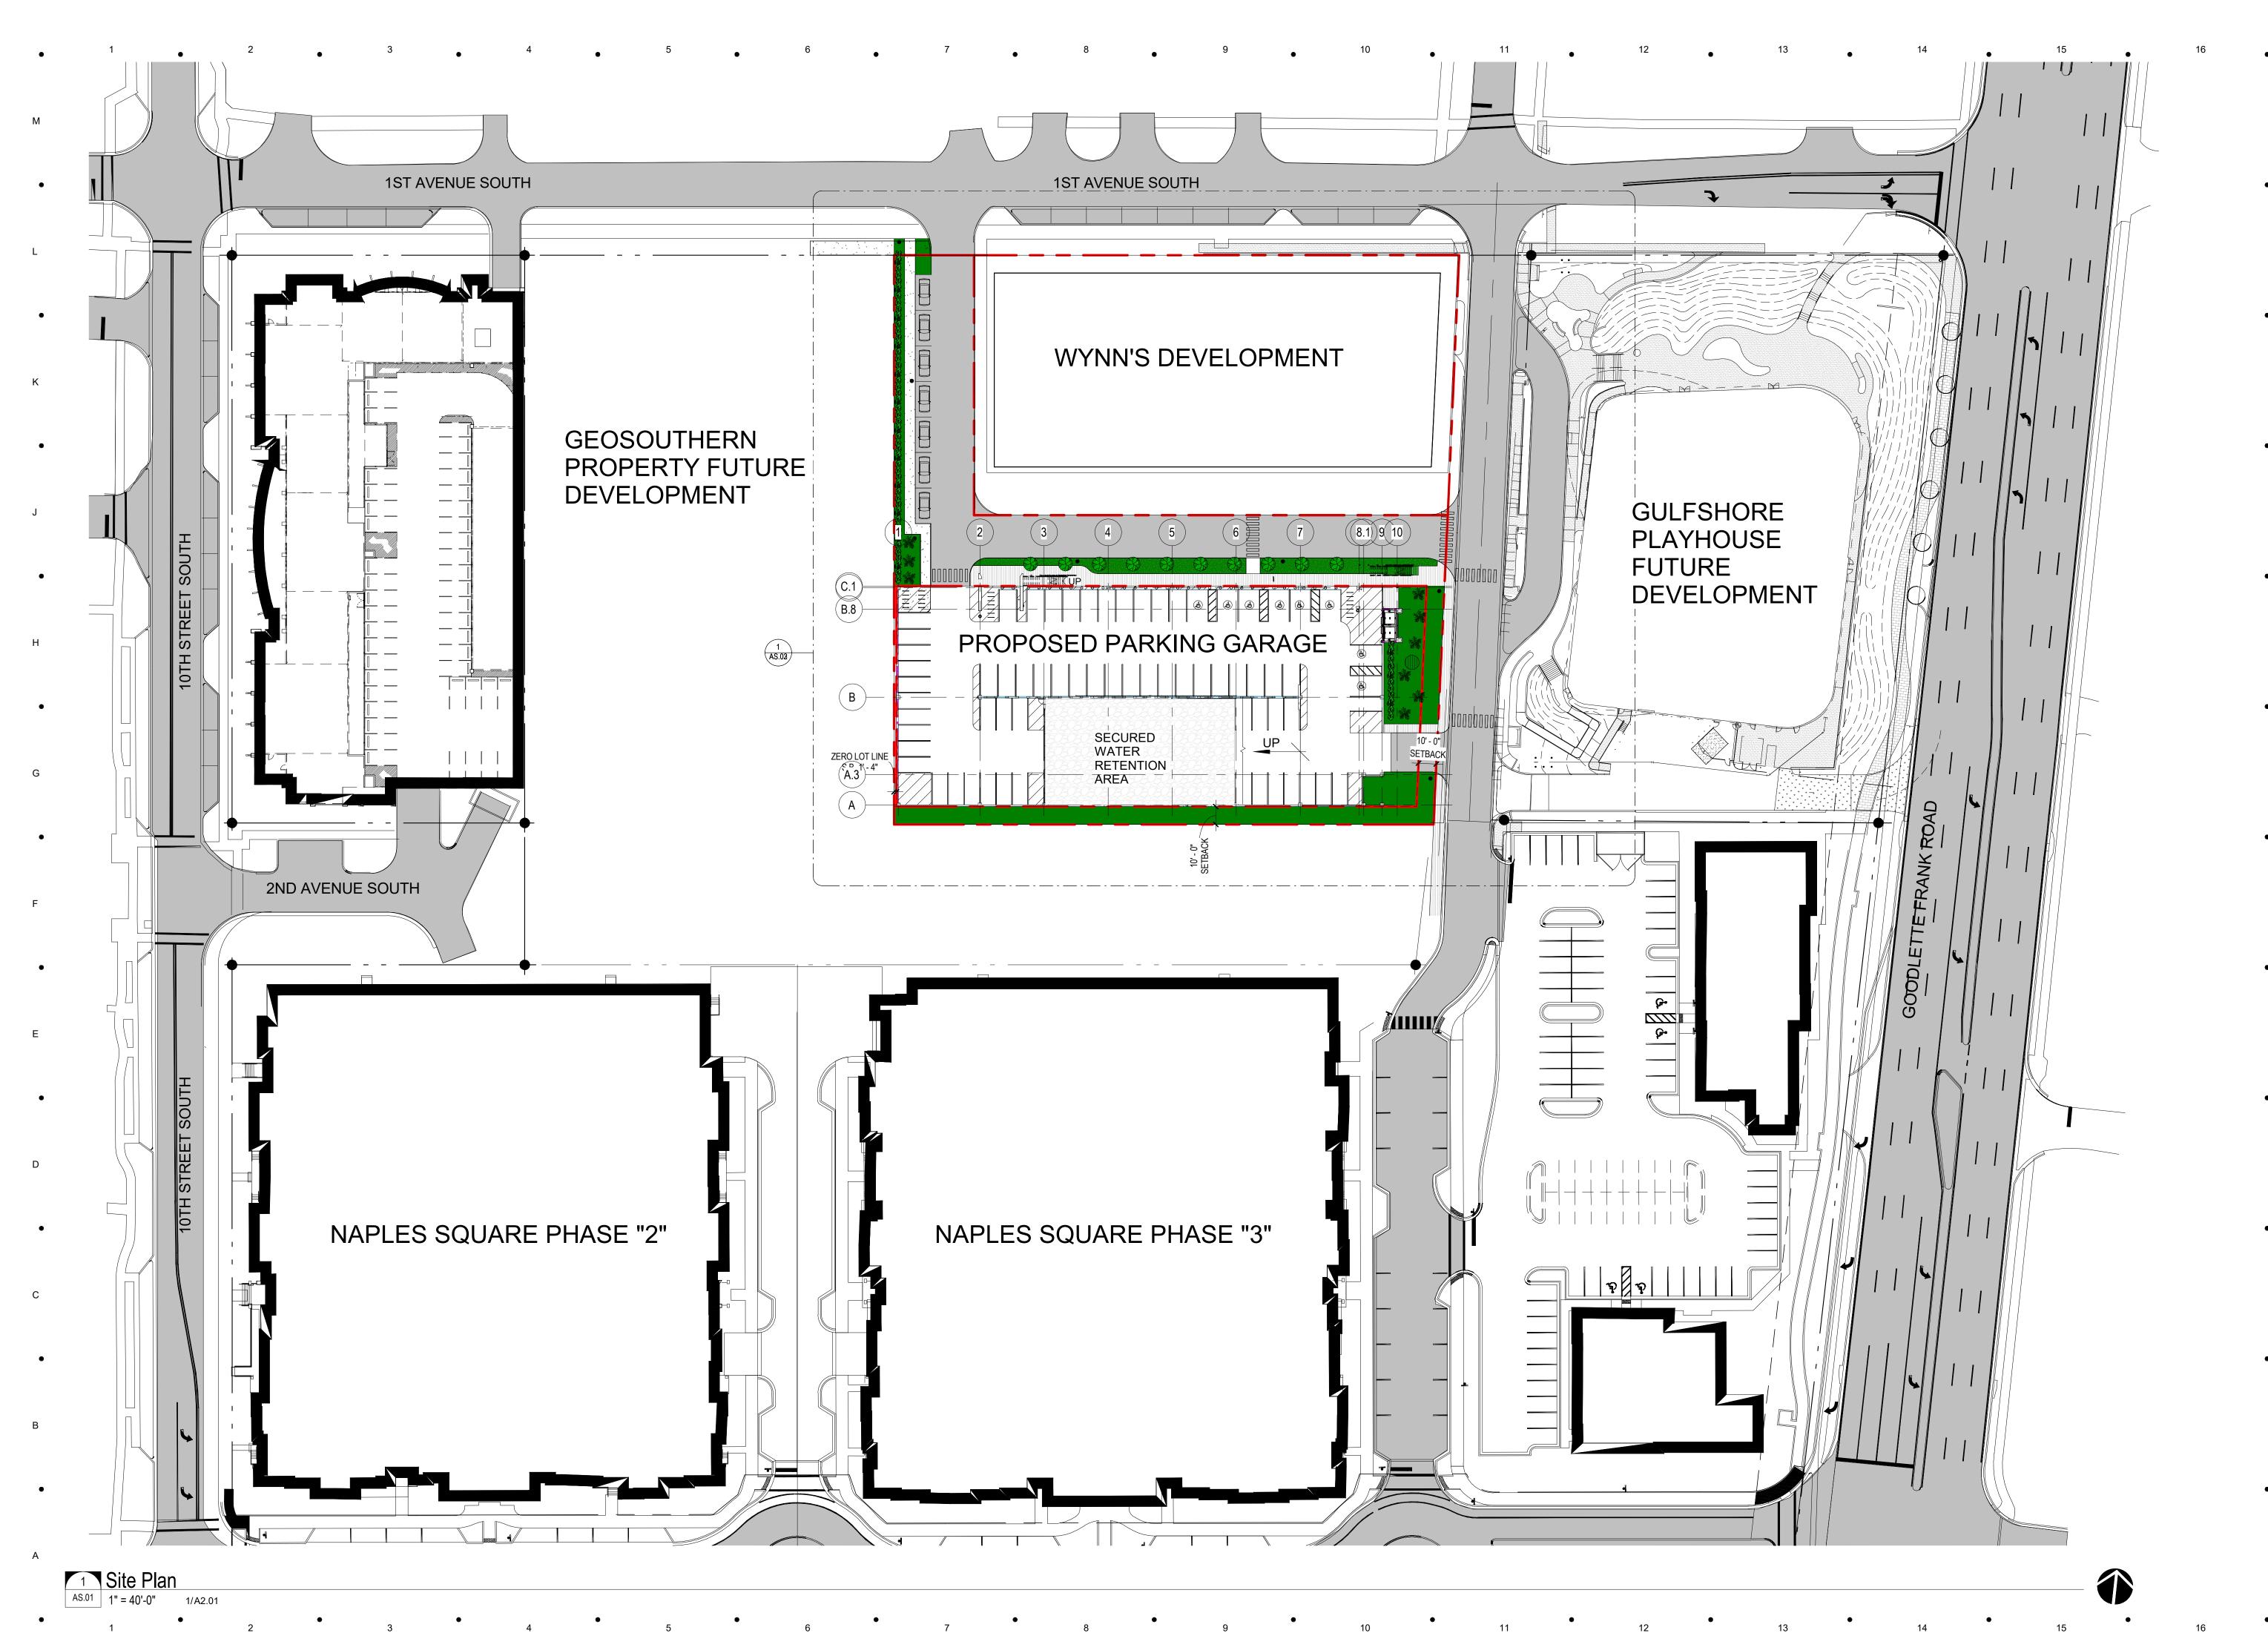

A R C H I T E C T S I N C License # AA C001863

Phone: 239-278-3838 Fax: 239-275-538


949 Central Ave.
Naples, Florida 34102
Phone: 239-643-3103 Fax: 239-643-7435

Proiect:

1st Avenue S.
Public Parking
Garage

Owner:
City of Naples

Consultant:

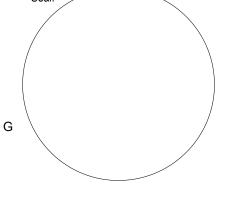

Design Development

Project #: 2204.01
Project Issued: June/202

No Date Revision


Copyright © 2022. BSSW Architects Inc. reserves copyright and other rig restricting these documents to the original site or purpose for which the were prepared. Reproductions,

changes or assignments are prohibited.

Sheet Title: Architectural Site Plan

AS.01

Autodesk Docs://2204.01 - Naples Playhouse Parking Garage/2204.01 - 1st Avenue S. Public Parking Garage_R-22.rvt 1/12/2023 5:48:38 PM

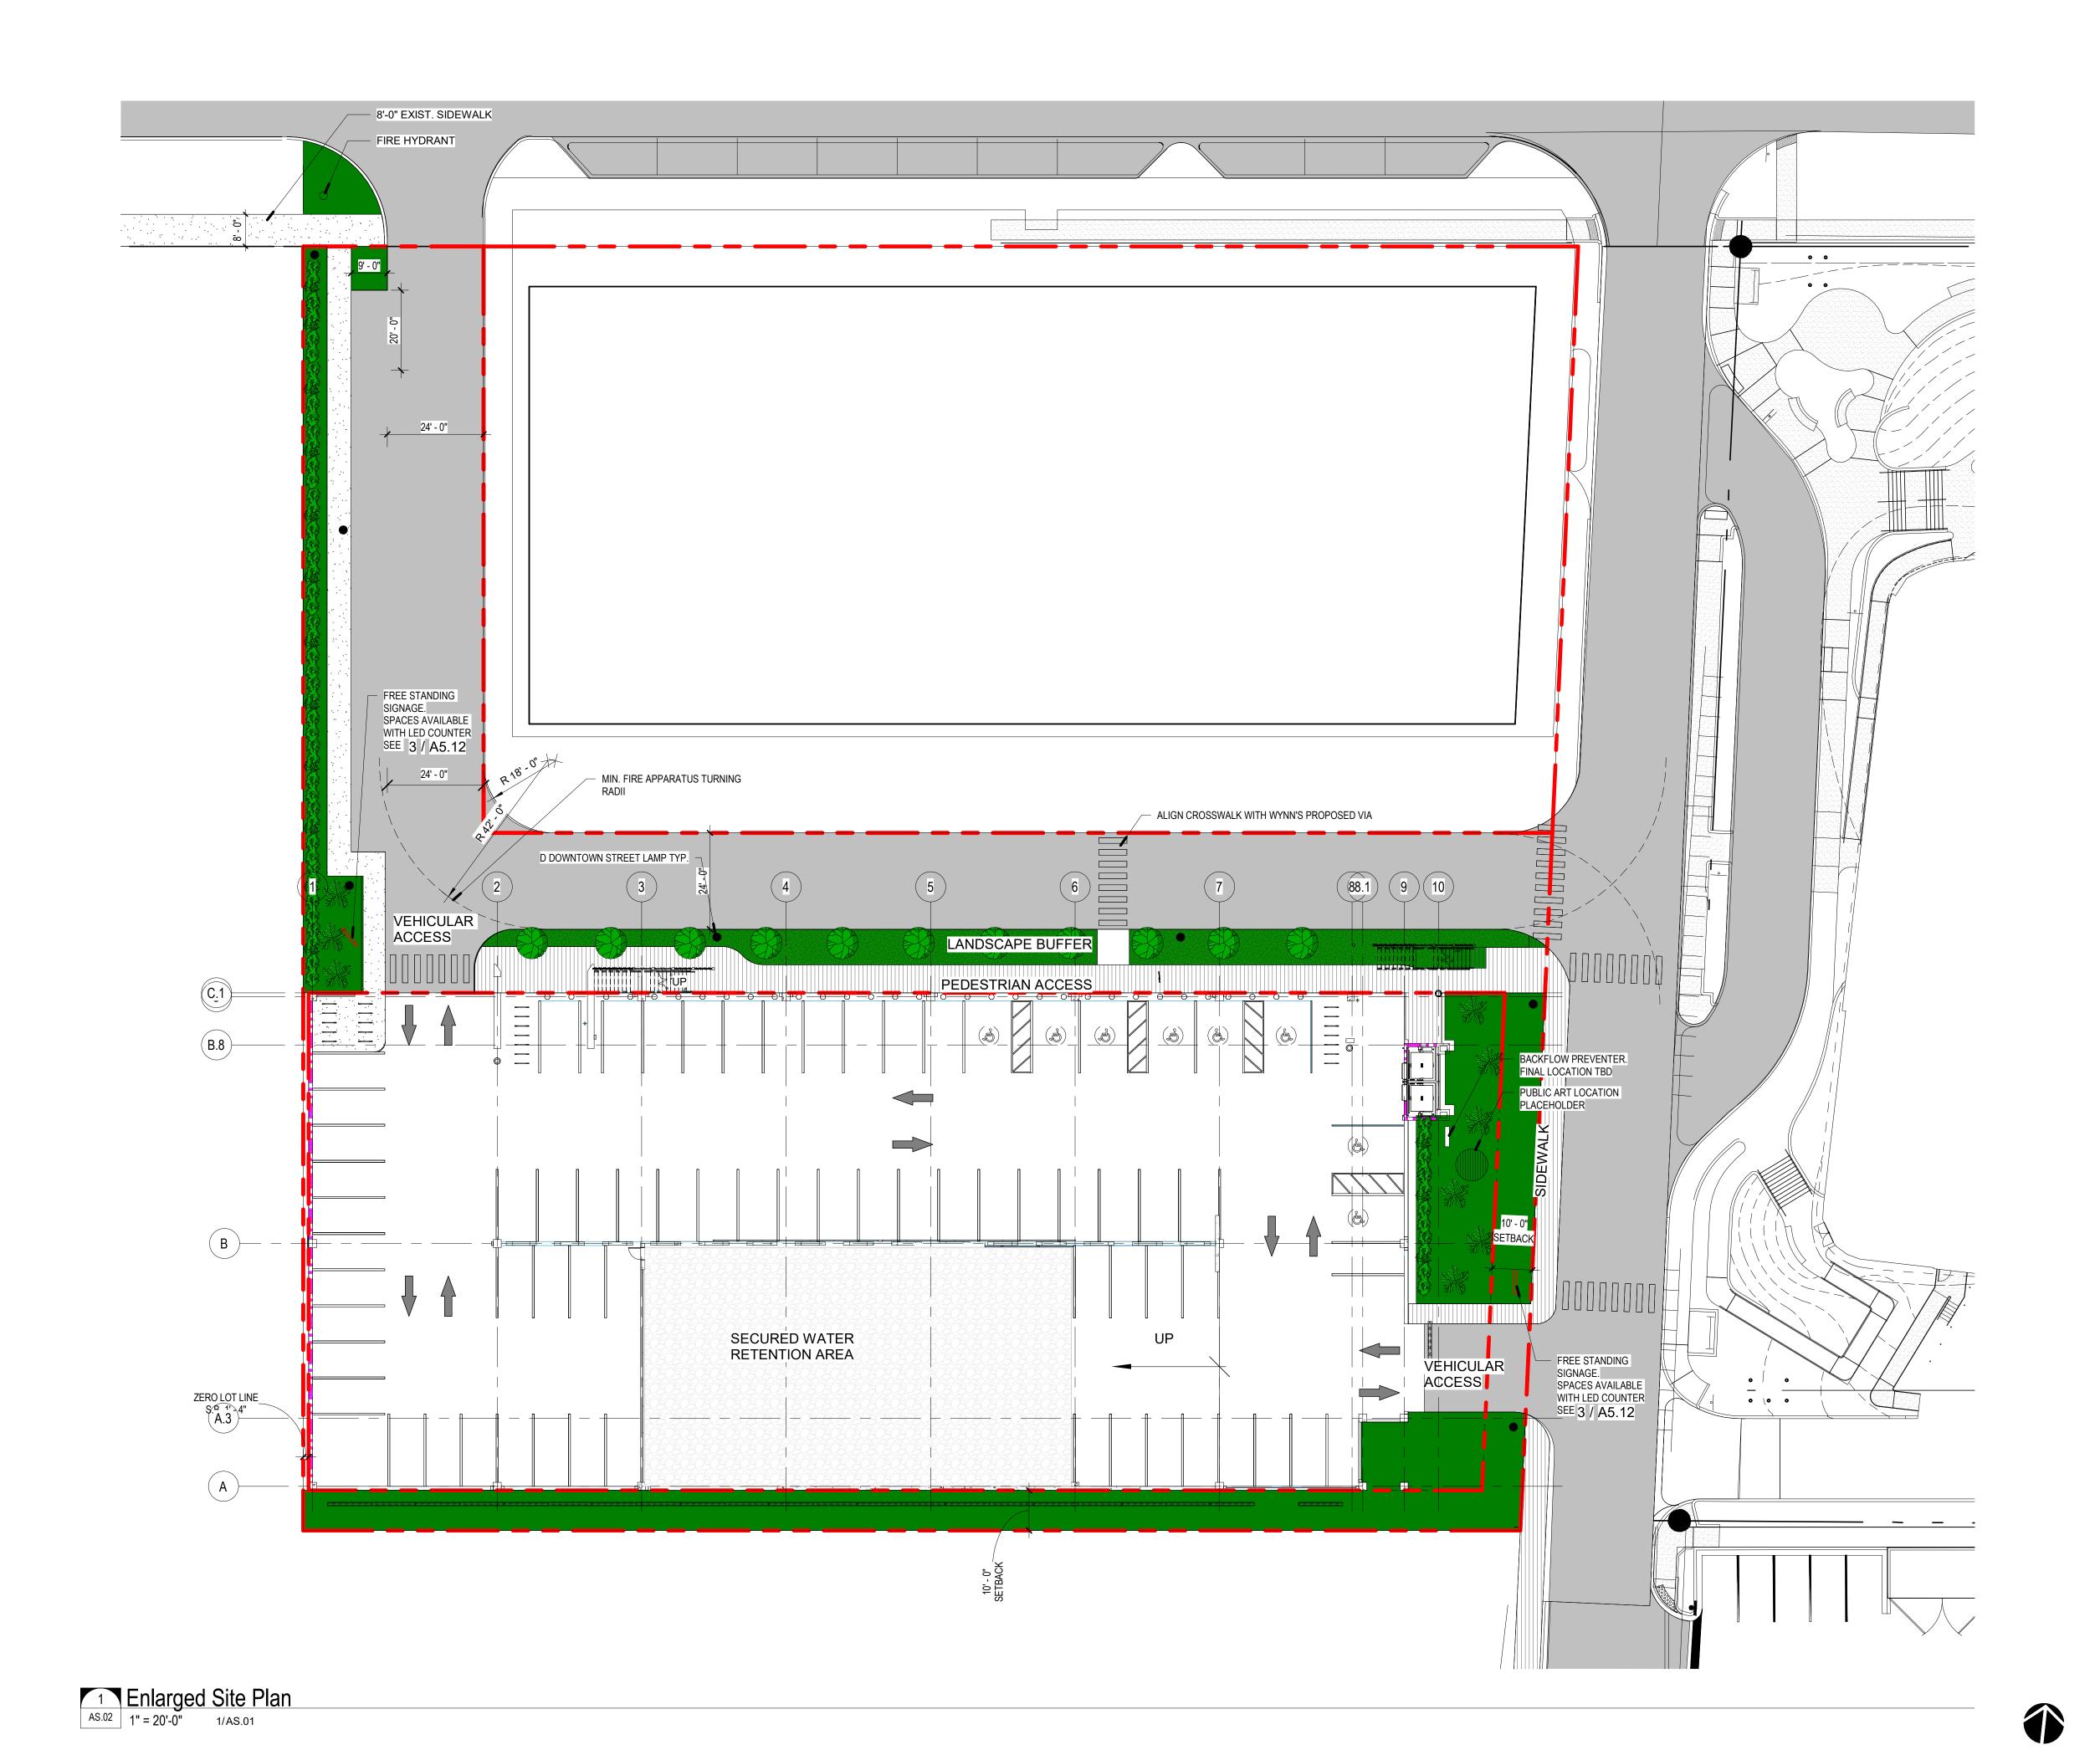



A R C H I T E C T S I N C
License # AA C001863

L 1500 Jackson Street, Suite 200

1500 Jackson Street, Suite 200 Fort Myers, Florida 33901 Phone: 239-278-3838 Fax: 239-275-5356

949 Central Ave.
Naples, Florida 34102
Phone: 239-643-3103 Fax: 239-643-7435

Drainati

1st Avenue S. Public Parking Garage

Owner:
City of Naples

Consultant:

Seal:

Project Phase: Design Development

Project #: 2204.01
Project Issued: June/2022
Sheet Issued: 01-05-2023

E	No	Date	Revision
•			
_			
D			
•			
С			
_			
•			

Copyright © 2022. BSSW Architects, Inc. reserves copyright and other rights restricting these documents to the original site or purpose for which they were prepared. Reproductions,

changes or assignments are prohibited.


Architectural Site Plan

In Enlarged

Sheet No.

Autodesk Docs://2204.01 - Naples Playhouse Parking Garage/2204.01 - 1st Avenue S. Public Parking Garage_R-22.rvt 1/12/2023 5:48:41 PM

AS.02

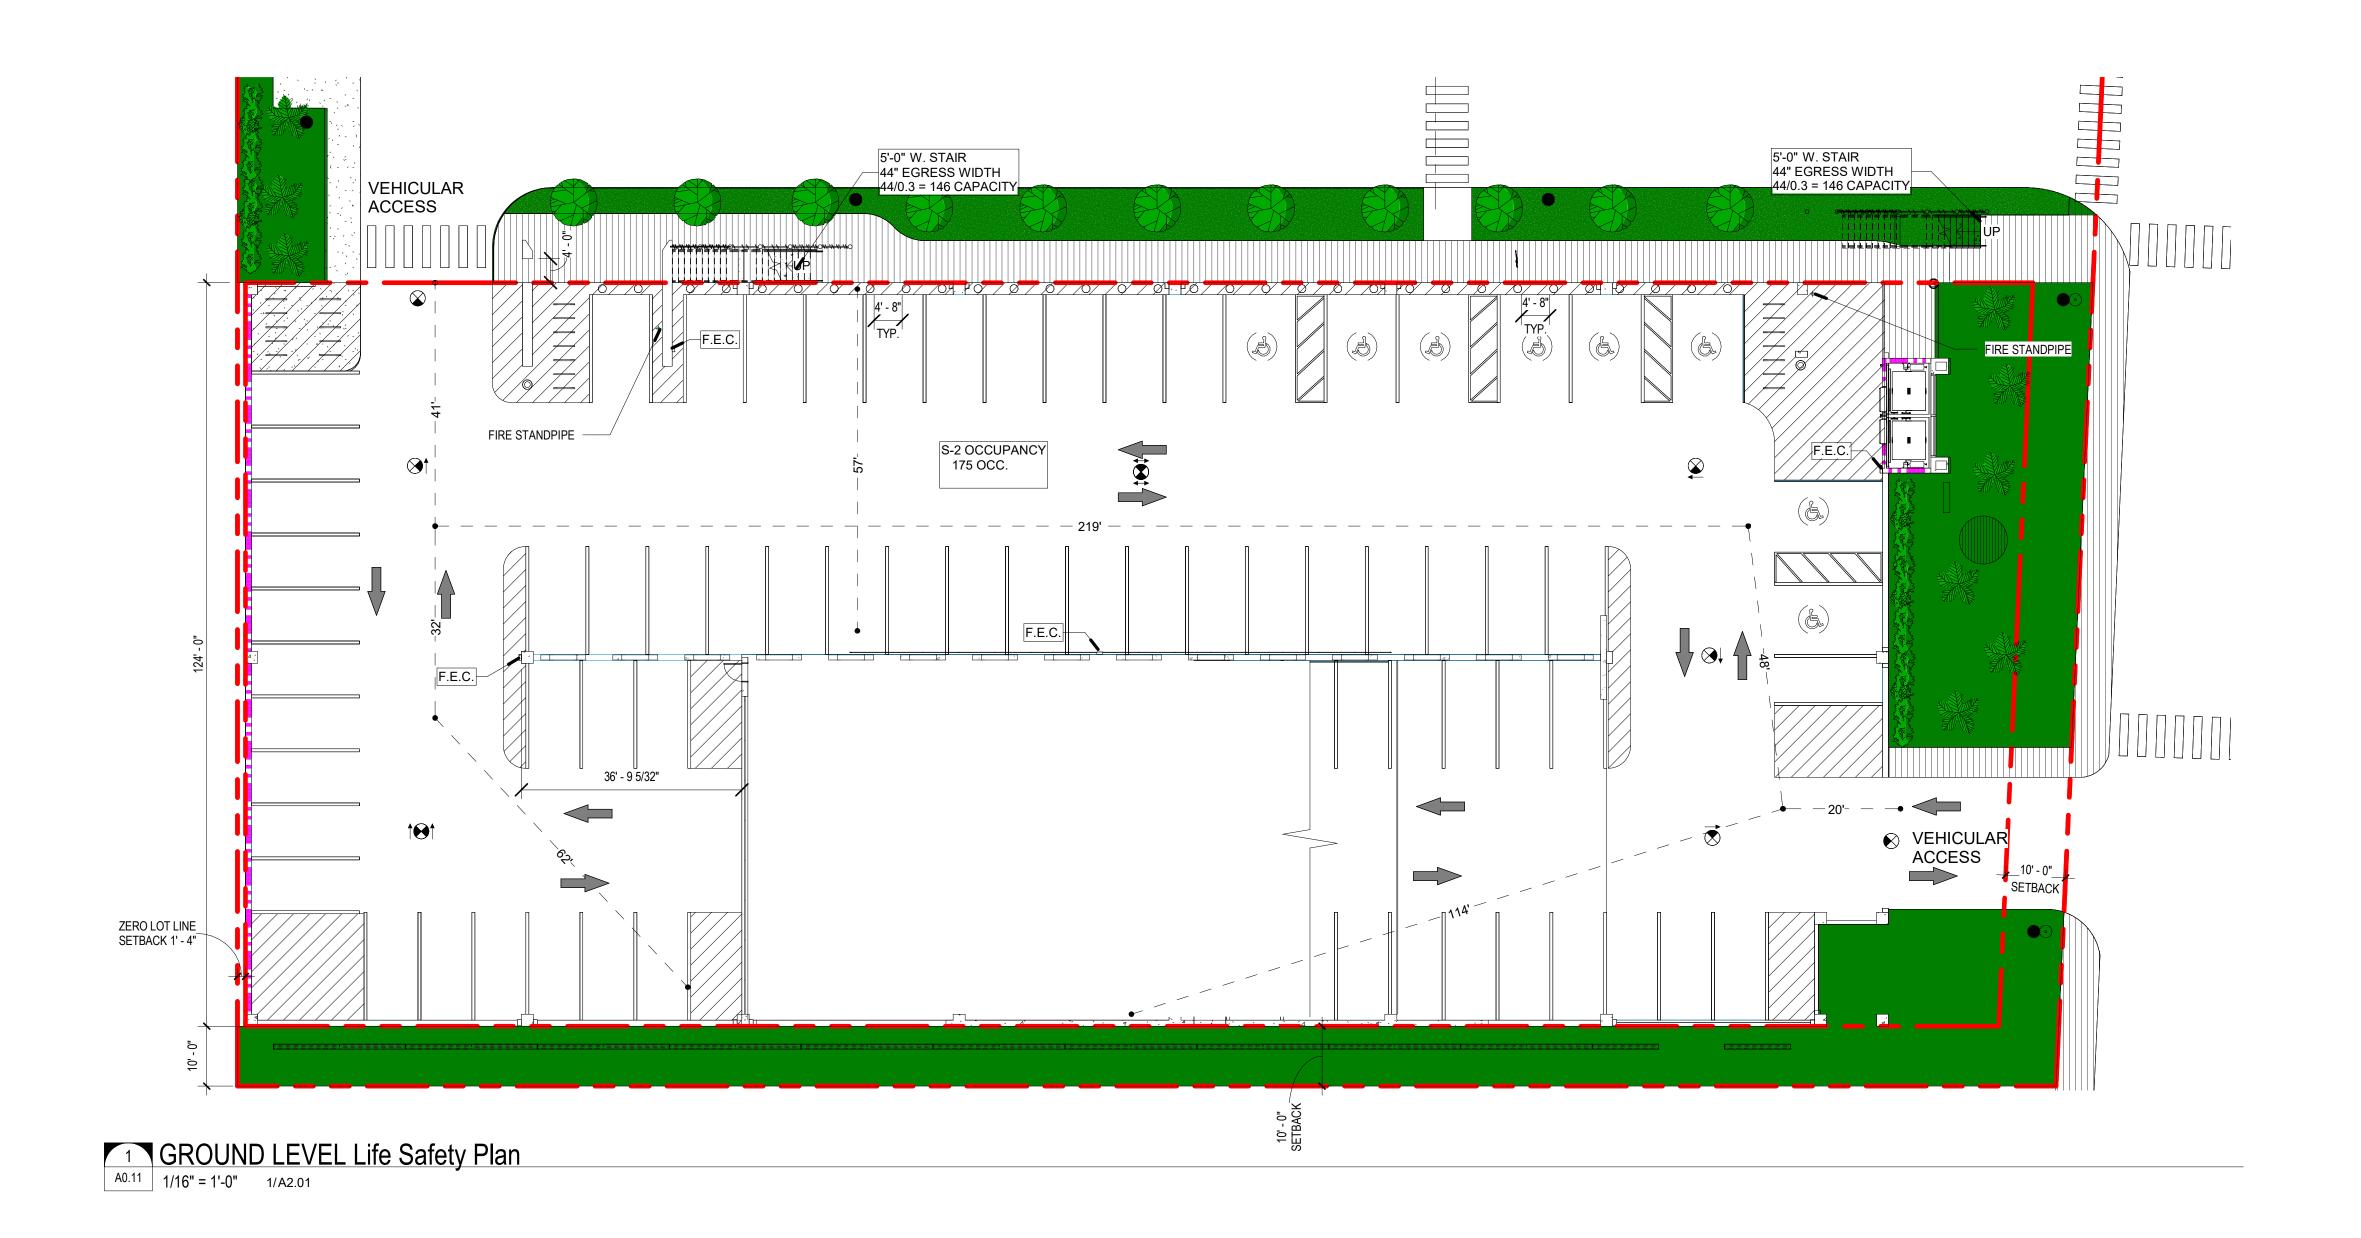

2-HOUR FIRE RATED ELEMENT RATED DOOR (MINUTES / TYPE) COMBINATION AUDIBLE/VISUAL SIGNALING UNIT - HORN/FLASHING "FIRE" X 150 OCCUPANT CAPACITY OF INCHES VISUAL SIGNALING UNIT - WALL MOUNTED - FLASHING "FIRE" LIGHT ONLY PERSON (NO AUDIBLE DEVICE) OCCUPANCY — X X / XXX — OCC. FORMULA SUB X X OCC TOTAL OCCUPANCY CLASSIFICATION CARD READER OCCUPANT LOAD AT EXITS DELAYED EGRESS FIREMAN'S PHONE JACK F.E.C. FIRE EXTINGUISHER CABINET SPRINKLER TAMPER SWITCH CONNECTION WALL HUNG FIRE EXTINGUISHER COMMON PATH OF TRAVEL DISTANCE SPRINKLER WATERFLOW SWITCH

LIFE SAFETY LEGEND

SMOKE RATED PARTITION

1/2-HOUR FIRE RATED ELEMENT

1-HOUR FIRE RATED ELEMENT

TOTAL PATH OF TRAVEL DISTANCE (TO

TRAVEL DISTANCE

BETWEEN POINTS

FURTHEST EXIT)

PATH OF

TRAVEL

TERMINATION

EXIT SIGN (ARROW INDICATES DIRECTION OF

GENERAL INFORMATION

REFERENCE SHEET A0.01 FOR INTERIOR PARTITION ASSEMBLIES
REFERENCE SHEET A0.02 FOR EXTERIOR PARTITION ASSEMBLIES
REFERENCE SHEET A0.03 FOR UL RATED ASSEMBLIES
REFERENCE SHEETS A1.03 THROUGH A1.10 FOR DIMENSIONAL INFORMATION
REFERENCE SHEET A6.11 FOR DOOR & A6.12 WINDOWS TYPES & SCHEDULES

T.C.O. - PROJECT PHASE 1
AREAS WITHIN THESE LINES ARE TO BE
PERMITTED / OCCUPIED BEFORE THE REST OF
THE BUILDING

Autodesk Docs://2204.01 - Naples Playhouse Parking Garage/2204.01 - 1st Avenue S. Public Parking Garage_R-22.rvt 1/12/2023 5:45:32 PM

FIRE ALARM / DETECTION SYSTEM

CEILING SMOKE DETECTOR, PHOTO-

ELECTRIC TYPE UNLESS OTHERWISE

ELECTROMAGNETIC DOOR HOLD OPEN

CONNECTION TO CLOSURE/ HOLDER INCLUDES

DEVICE

DETECTOR

E = ELEVATOR I = IONIZATION

MANUAL PULL STATION

BSSVV

ARCHITECTS IN C
License # AA C001863


1500 Jackson Street, Suite 200 Fort Myers, Florida 33901 Phone: 239-278-3838 Fax: 239-275-5356

949 Central Ave.
Naples, Florida 34102
Phone: 239-643-3103 Fax: 239-643-7435

1st Avenue S.
Public Parking
Garage

Owner:
City of Naples

Consultant

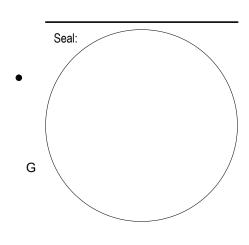

Project Phase:

Design Development

Project #: 2204.01
Project Issued: June/2022
Sheet Issued: 01-05-2023

Ε	No	Date	Revision
D			
С			


Copyright © 2022. BSSW Architects, Inc. reserves copyright and other rights restricting these documents to the original site or purpose for which they were prepared. Reproductions, changes or assignments are

Sheet Title:
Life Safety Plan Ground

Level

Sheet No.

A0.11

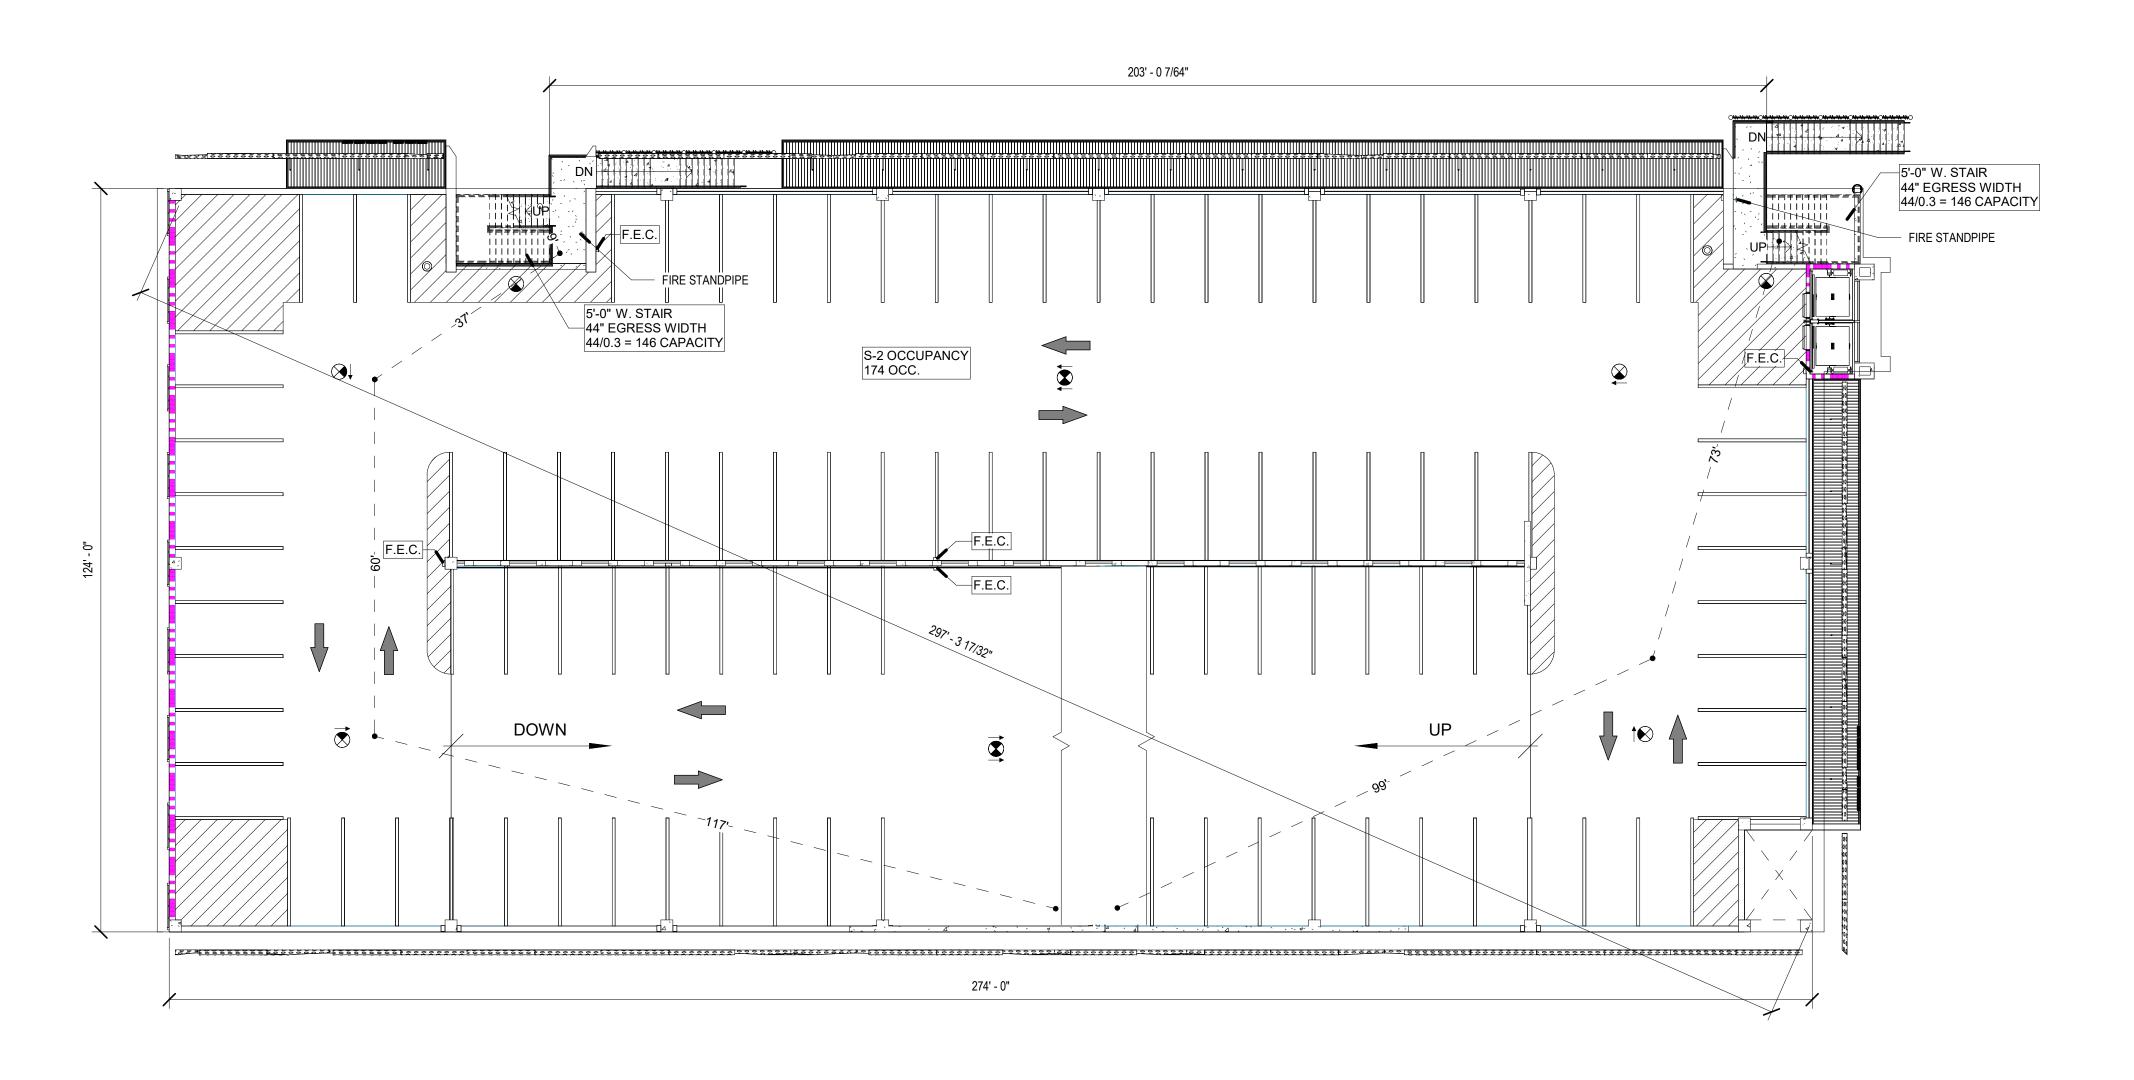

1 SECOND LEVEL Life Safety Plan
A0.12 1/16" = 1'-0" 1/A2.01

CEILING SMOKE DETECTOR, PHOTO-1/2-HOUR FIRE RATED ELEMENT ELECTRIC TYPE UNLESS OTHERWISE 1-HOUR FIRE RATED ELEMENT E = ELEVATOR I = IONIZATION 2-HOUR FIRE RATED ELEMENT RATED DOOR (MINUTES / TYPE) COMBINATION AUDIBLE/VISUAL SIGNALING UNIT - HORN/FLASHING "FIRE" X 150 OCCUPANT CAPACITY OF **INCHES** VISUAL SIGNALING UNIT - WALL MOUNTED - FLASHING "FIRE" LIGHT ONLY WIDTH PER ——.3" CAP EXIT STAIRS PERSON (NO AUDIBLE DEVICE) OCCUPANCY X X/XXX OCC. FORMULA SUB X X OCC TOTAL OCCUPANCY CLASSIFICATION CARD READER OCCUPANT LOAD AT EXITS DELAYED EGRESS FIREMAN'S PHONE JACK F.E.C. FIRE EXTINGUISHER CABINET SPRINKLER TAMPER SWITCH CONNECTION WALL HUNG FIRE EXTINGUISHER COMMON PATH OF TRAVEL DISTANCE SPRINKLER WATERFLOW SWITCH TOTAL PATH OF TRAVEL DISTANCE (TO ELECTROMAGNETIC DOOR HOLD OPEN FURTHEST EXIT) DEVICE

LIFE SAFETY LEGEND

TERMINATION

PATH OF

TRAVEL

SMOKE RATED PARTITION

EXIT SIGN (ARROW INDICATES DIRECTION OF

● 10' — ● TRAVEL DISTANCE BETWEEN POINTS

FIRE ALARM / DETECTION SYSTEM

CONNECTION TO CLOSURE/ HOLDER INCLUDES

PERMITTED / OCCUPIED BEFORE THE REST OF

Autodesk Docs://2204.01 - Naples Playhouse Parking Garage/2204.01 - 1st Avenue S. Public Parking Garage_R-22.rvt 1/12/2023 5:45:36 PM

AREAS WITHIN THESE LINES ARE TO BE

DETECTOR

THE BUILDING

T.C.O. - PROJECT PHASE 1

MANUAL PULL STATION


GENERAL INFORMATION

REFERENCE SHEET A0.01 FOR INTERIOR PARTITION ASSEMBLIES REFERENCE SHEET A0.02 FOR EXTERIOR PARTITION ASSEMBLIES REFERENCE SHEET A0.03 FOR UL RATED ASSEMBLIES REFERENCE SHEETS A1.03 THROUGH A1.10 FOR DIMENSIONAL INFORMATION REFERENCE SHEET A6.11 FOR DOOR & A6.12 WINDOWS TYPES & SCHEDULES

License # AA C001863 1500 Jackson Street, Suite 200 Fort Myers, Florida 33901 Phone: 239-278-3838 Fax: 239-275-5356

949 Central Ave.
Naples, Florida 34102
Phone: 239-643-3103 Fax: 239-643-7435

1st Avenue S. Garage

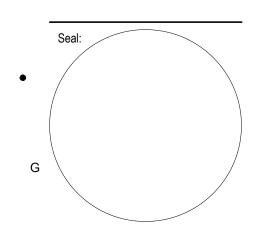

Project Phase: Design Development


Project #: 2204.01 Project Issued: June/2022 Sheet Issued: 01-05-2023

Е	No	Date	Revision
•			
D			
С			

Copyright © 2022. BSSW Architects, Inc. reserves copyright and other rights restricting these documents to the original site or purpose for which they were prepared. Reproductions, changes or assignments are

Sheet Title: Life Safety Plan Second Level

A Sheet No.

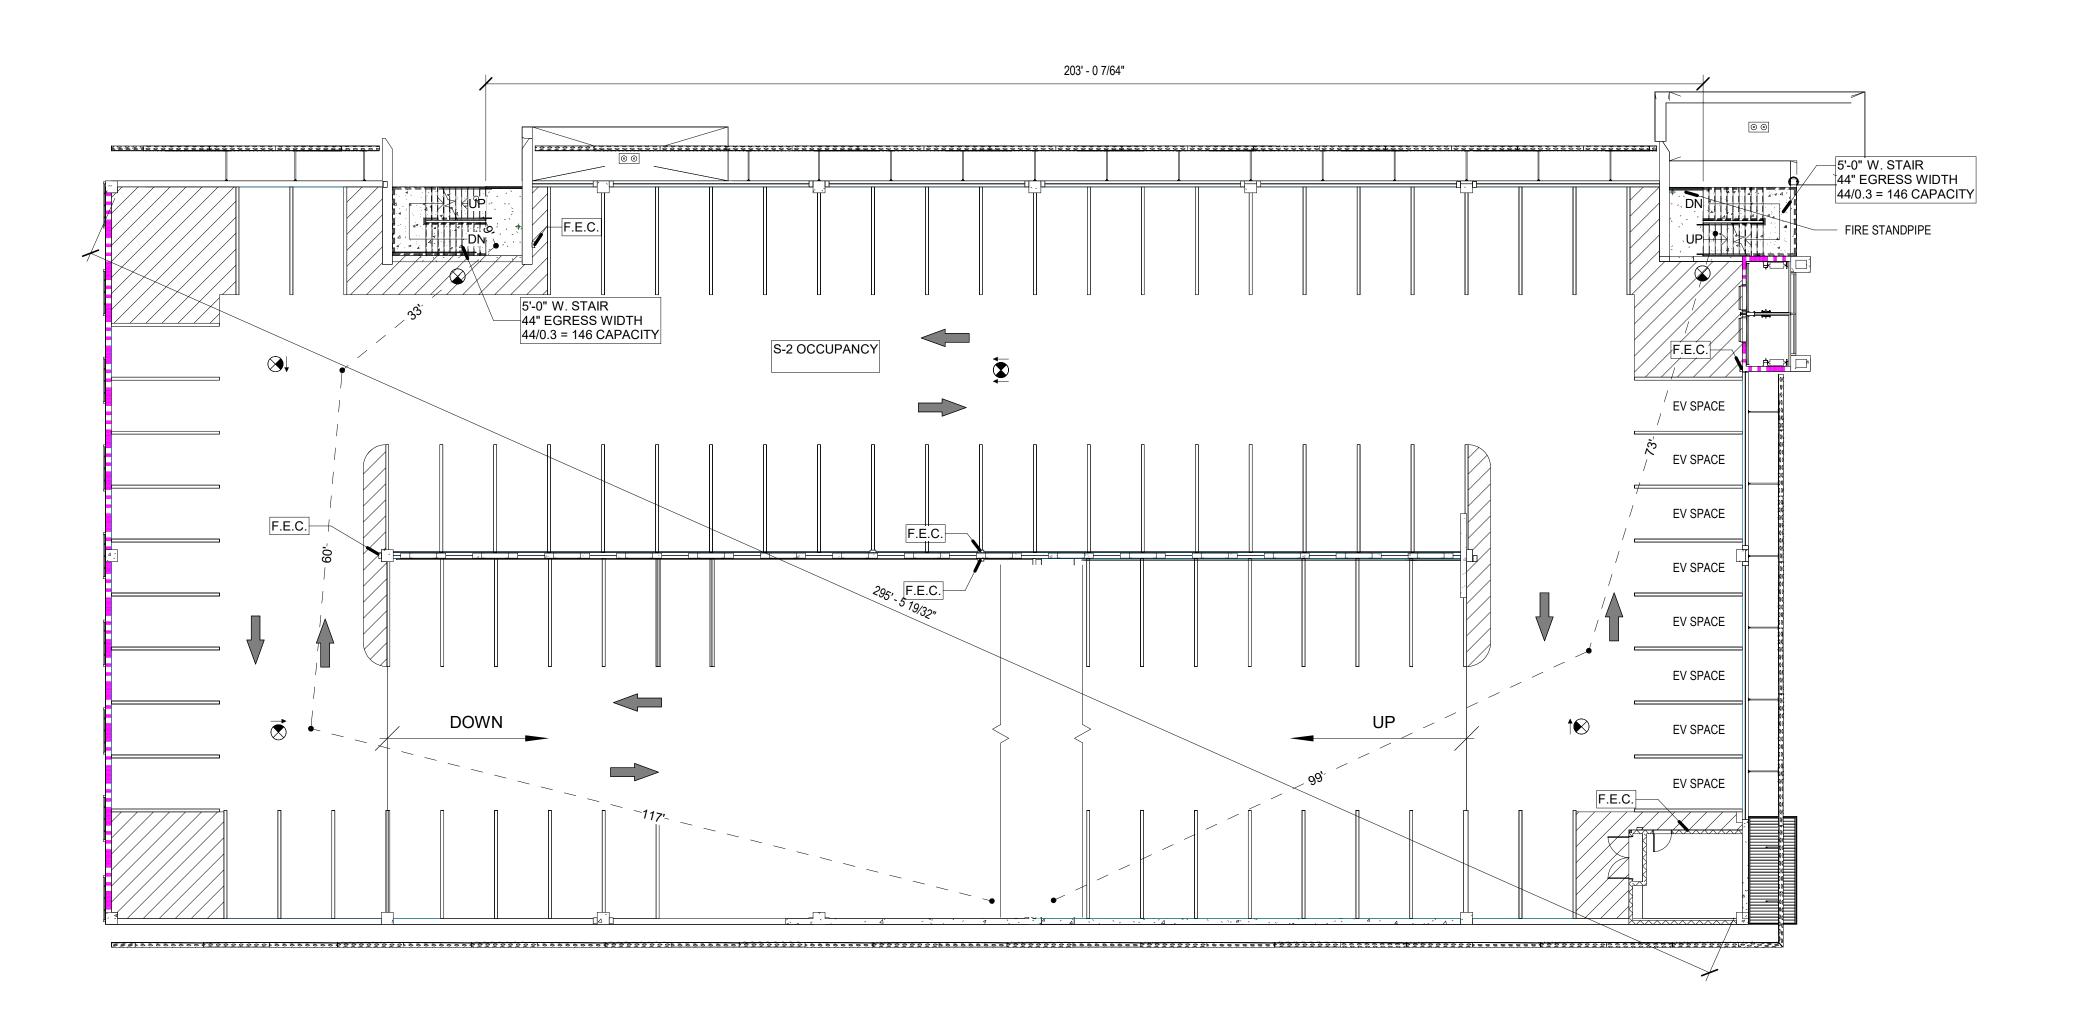


1 THIRD LEVEL Life Safety Plan

A0.13 1/16" = 1'-0" 1/A2.01

GENERAL INFORMATION

REFERENCE SHEET A0.01 FOR INTERIOR PARTITION ASSEMBLIES REFERENCE SHEET A0.02 FOR EXTERIOR PARTITION ASSEMBLIES REFERENCE SHEET A0.03 FOR UL RATED ASSEMBLIES REFERENCE SHEETS A1.03 THROUGH A1.10 FOR DIMENSIONAL INFORMATION REFERENCE SHEET A6.11 FOR DOOR & A6.12 WINDOWS TYPES & SCHEDULES

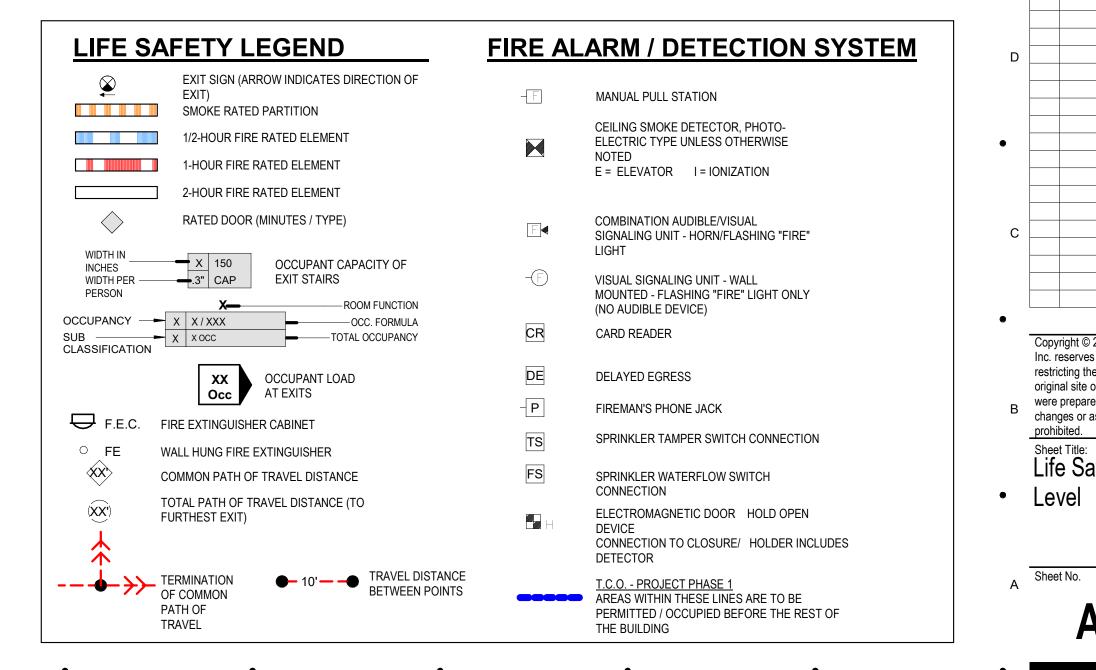


1500 Jackson Street, Suite 200 Fort Myers, Florida 33901 Phone: 239-278-3838 Fax: 239-275-5356

License # AA C001863

949 Central Ave.
Naples, Florida 34102
Phone: 239-643-3103 Fax: 239-643-7435

1st Avenue S. **Public Parking** Garage

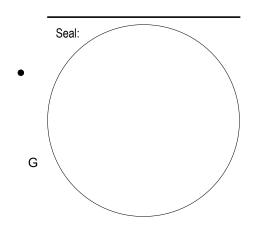


Project Phase: Design Development

Project #: 2204.01 Project Issued: June/2022 Sheet Issued: 01-05-2023

Copyright © 2022. BSSW Architects, Inc. reserves copyright and other rights restricting these documents to the original site or purpose for which they were prepared. Reproductions,

changes or assignments are Sheet Title: Life Safety Plan Third

Level

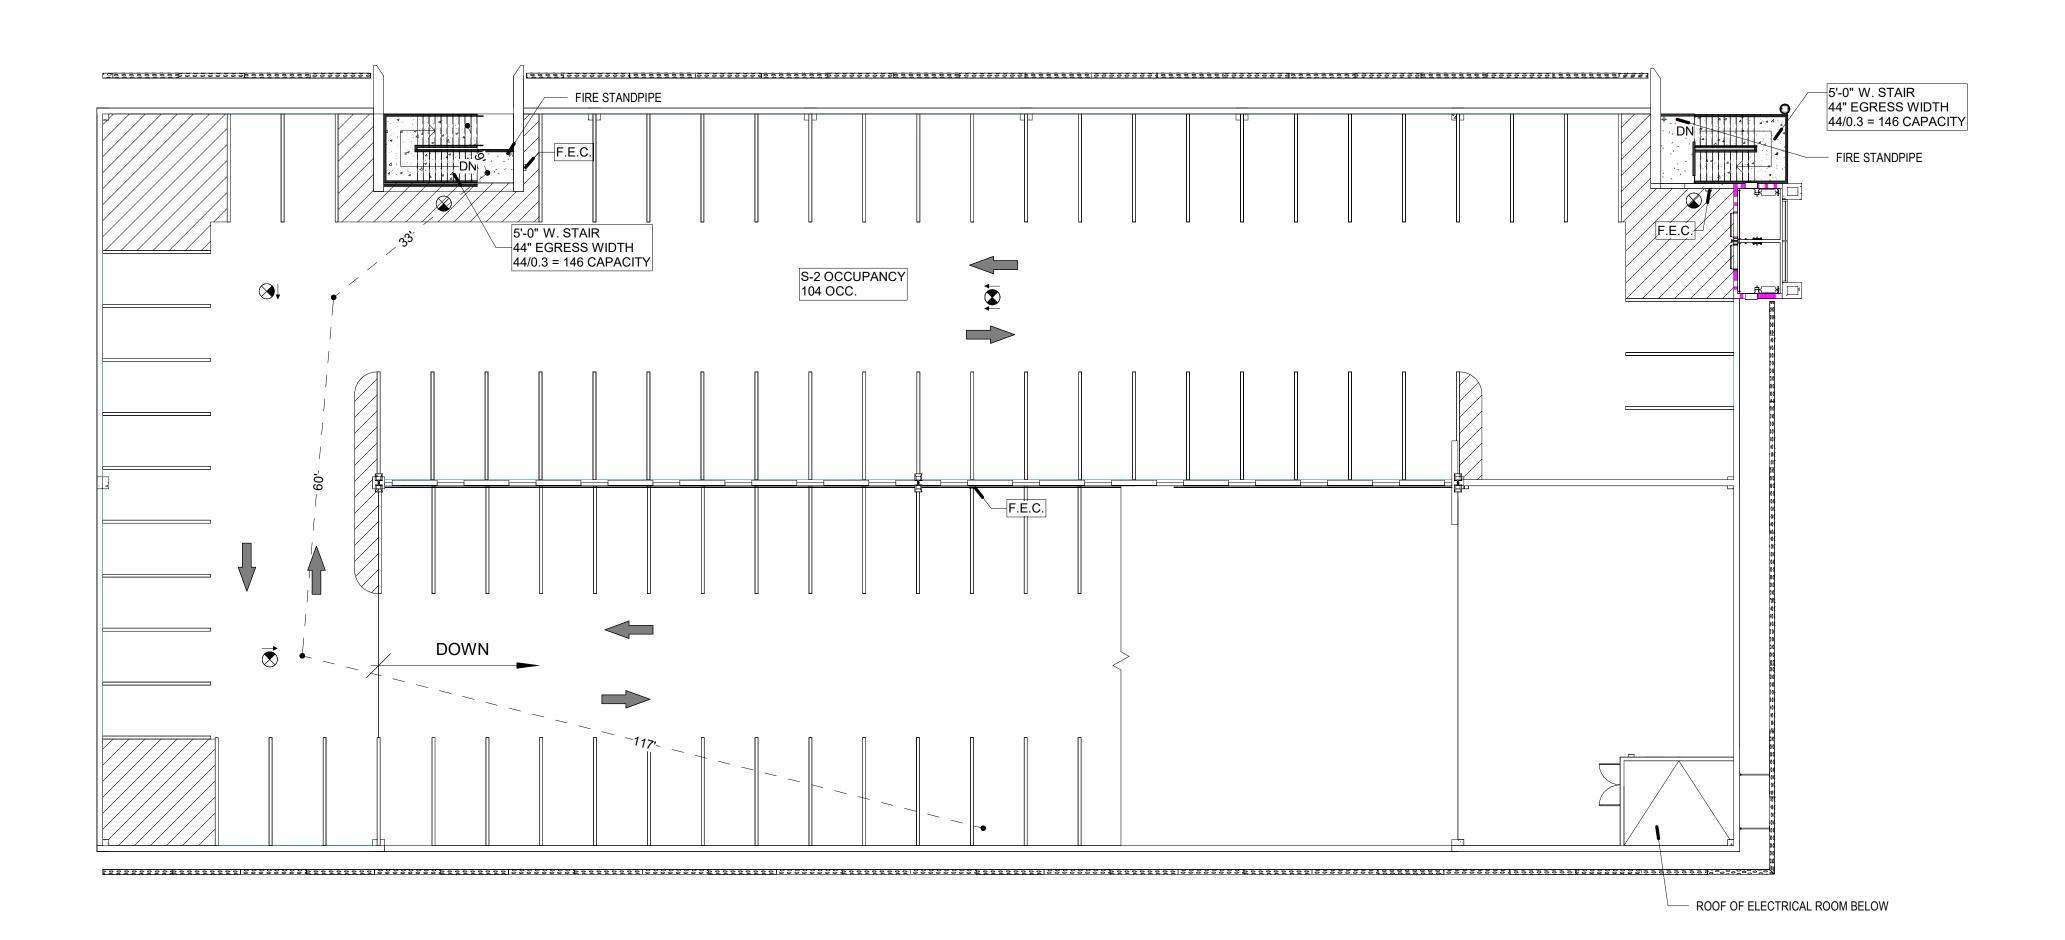

1 ROOF LEVEL Life Safety Plan
A0.14 1/16" = 1'-0" 1/A2.01

SMOKE RATED PARTITION CEILING SMOKE DETECTOR, PHOTO-1/2-HOUR FIRE RATED ELEMENT ELECTRIC TYPE UNLESS OTHERWISE 1-HOUR FIRE RATED ELEMENT E = ELEVATOR I = IONIZATION 2-HOUR FIRE RATED ELEMENT RATED DOOR (MINUTES / TYPE) COMBINATION AUDIBLE/VISUAL SIGNALING UNIT - HORN/FLASHING "FIRE" X 150 OCCUPANT CAPACITY OF **INCHES** VISUAL SIGNALING UNIT - WALL MOUNTED - FLASHING "FIRE" LIGHT ONLY WIDTH PER ——.3" CAP EXIT STAIRS PERSON (NO AUDIBLE DEVICE) OCCUPANCY X X/XXX OCC. FORMULA SUB X X OCC TOTAL OCCUPANCY CARD READER OCCUPANT LOAD AT EXITS DELAYED EGRESS FIREMAN'S PHONE JACK F.E.C. FIRE EXTINGUISHER CABINET SPRINKLER TAMPER SWITCH CONNECTION WALL HUNG FIRE EXTINGUISHER COMMON PATH OF TRAVEL DISTANCE SPRINKLER WATERFLOW SWITCH TOTAL PATH OF TRAVEL DISTANCE (TO ELECTROMAGNETIC DOOR HOLD OPEN FURTHEST EXIT) DEVICE CONNECTION TO CLOSURE/ HOLDER INCLUDES

LIFE SAFETY LEGEND

TERMINATION OF COMMON

PATH OF

TRAVEL

EXIT SIGN (ARROW INDICATES DIRECTION OF

● 10' — ● TRAVEL DISTANCE BETWEEN POINTS

changes or assignments are Sheet Title: Life Safety Plan Roof

Copyright © 2022. BSSW Architects, Inc. reserves copyright and other rights restricting these documents to the

original site or purpose for which they were prepared. Reproductions,

Project Phase:

No Date

Design Development

Project #: 2204.01 Project Issued: June/2022 Sheet Issued: 01-05-2023

License # AA C001863

Phone: 239-278-3838 Fax: 239-275-5356

1500 Jackson Street, Suite 200 Fort Myers, Florida 33901

949 Central Ave.
Naples, Florida 34102
Phone: 239-643-3103 Fax: 239-643-7435

1st Avenue S.

Level

A Sheet No.

REFERENCE SHEET A0.01 FOR INTERIOR PARTITION ASSEMBLIES REFERENCE SHEET A0.02 FOR EXTERIOR PARTITION ASSEMBLIES REFERENCE SHEET A0.03 FOR UL RATED ASSEMBLIES REFERENCE SHEETS A1.03 THROUGH A1.10 FOR DIMENSIONAL INFORMATION REFERENCE SHEET A6.11 FOR DOOR & A6.12 WINDOWS TYPES & SCHEDULES **FIRE ALARM / DETECTION SYSTEM**

MANUAL PULL STATION


DETECTOR

THE BUILDING


T.C.O. - PROJECT PHASE 1

AREAS WITHIN THESE LINES ARE TO BE

PERMITTED / OCCUPIED BEFORE THE REST OF

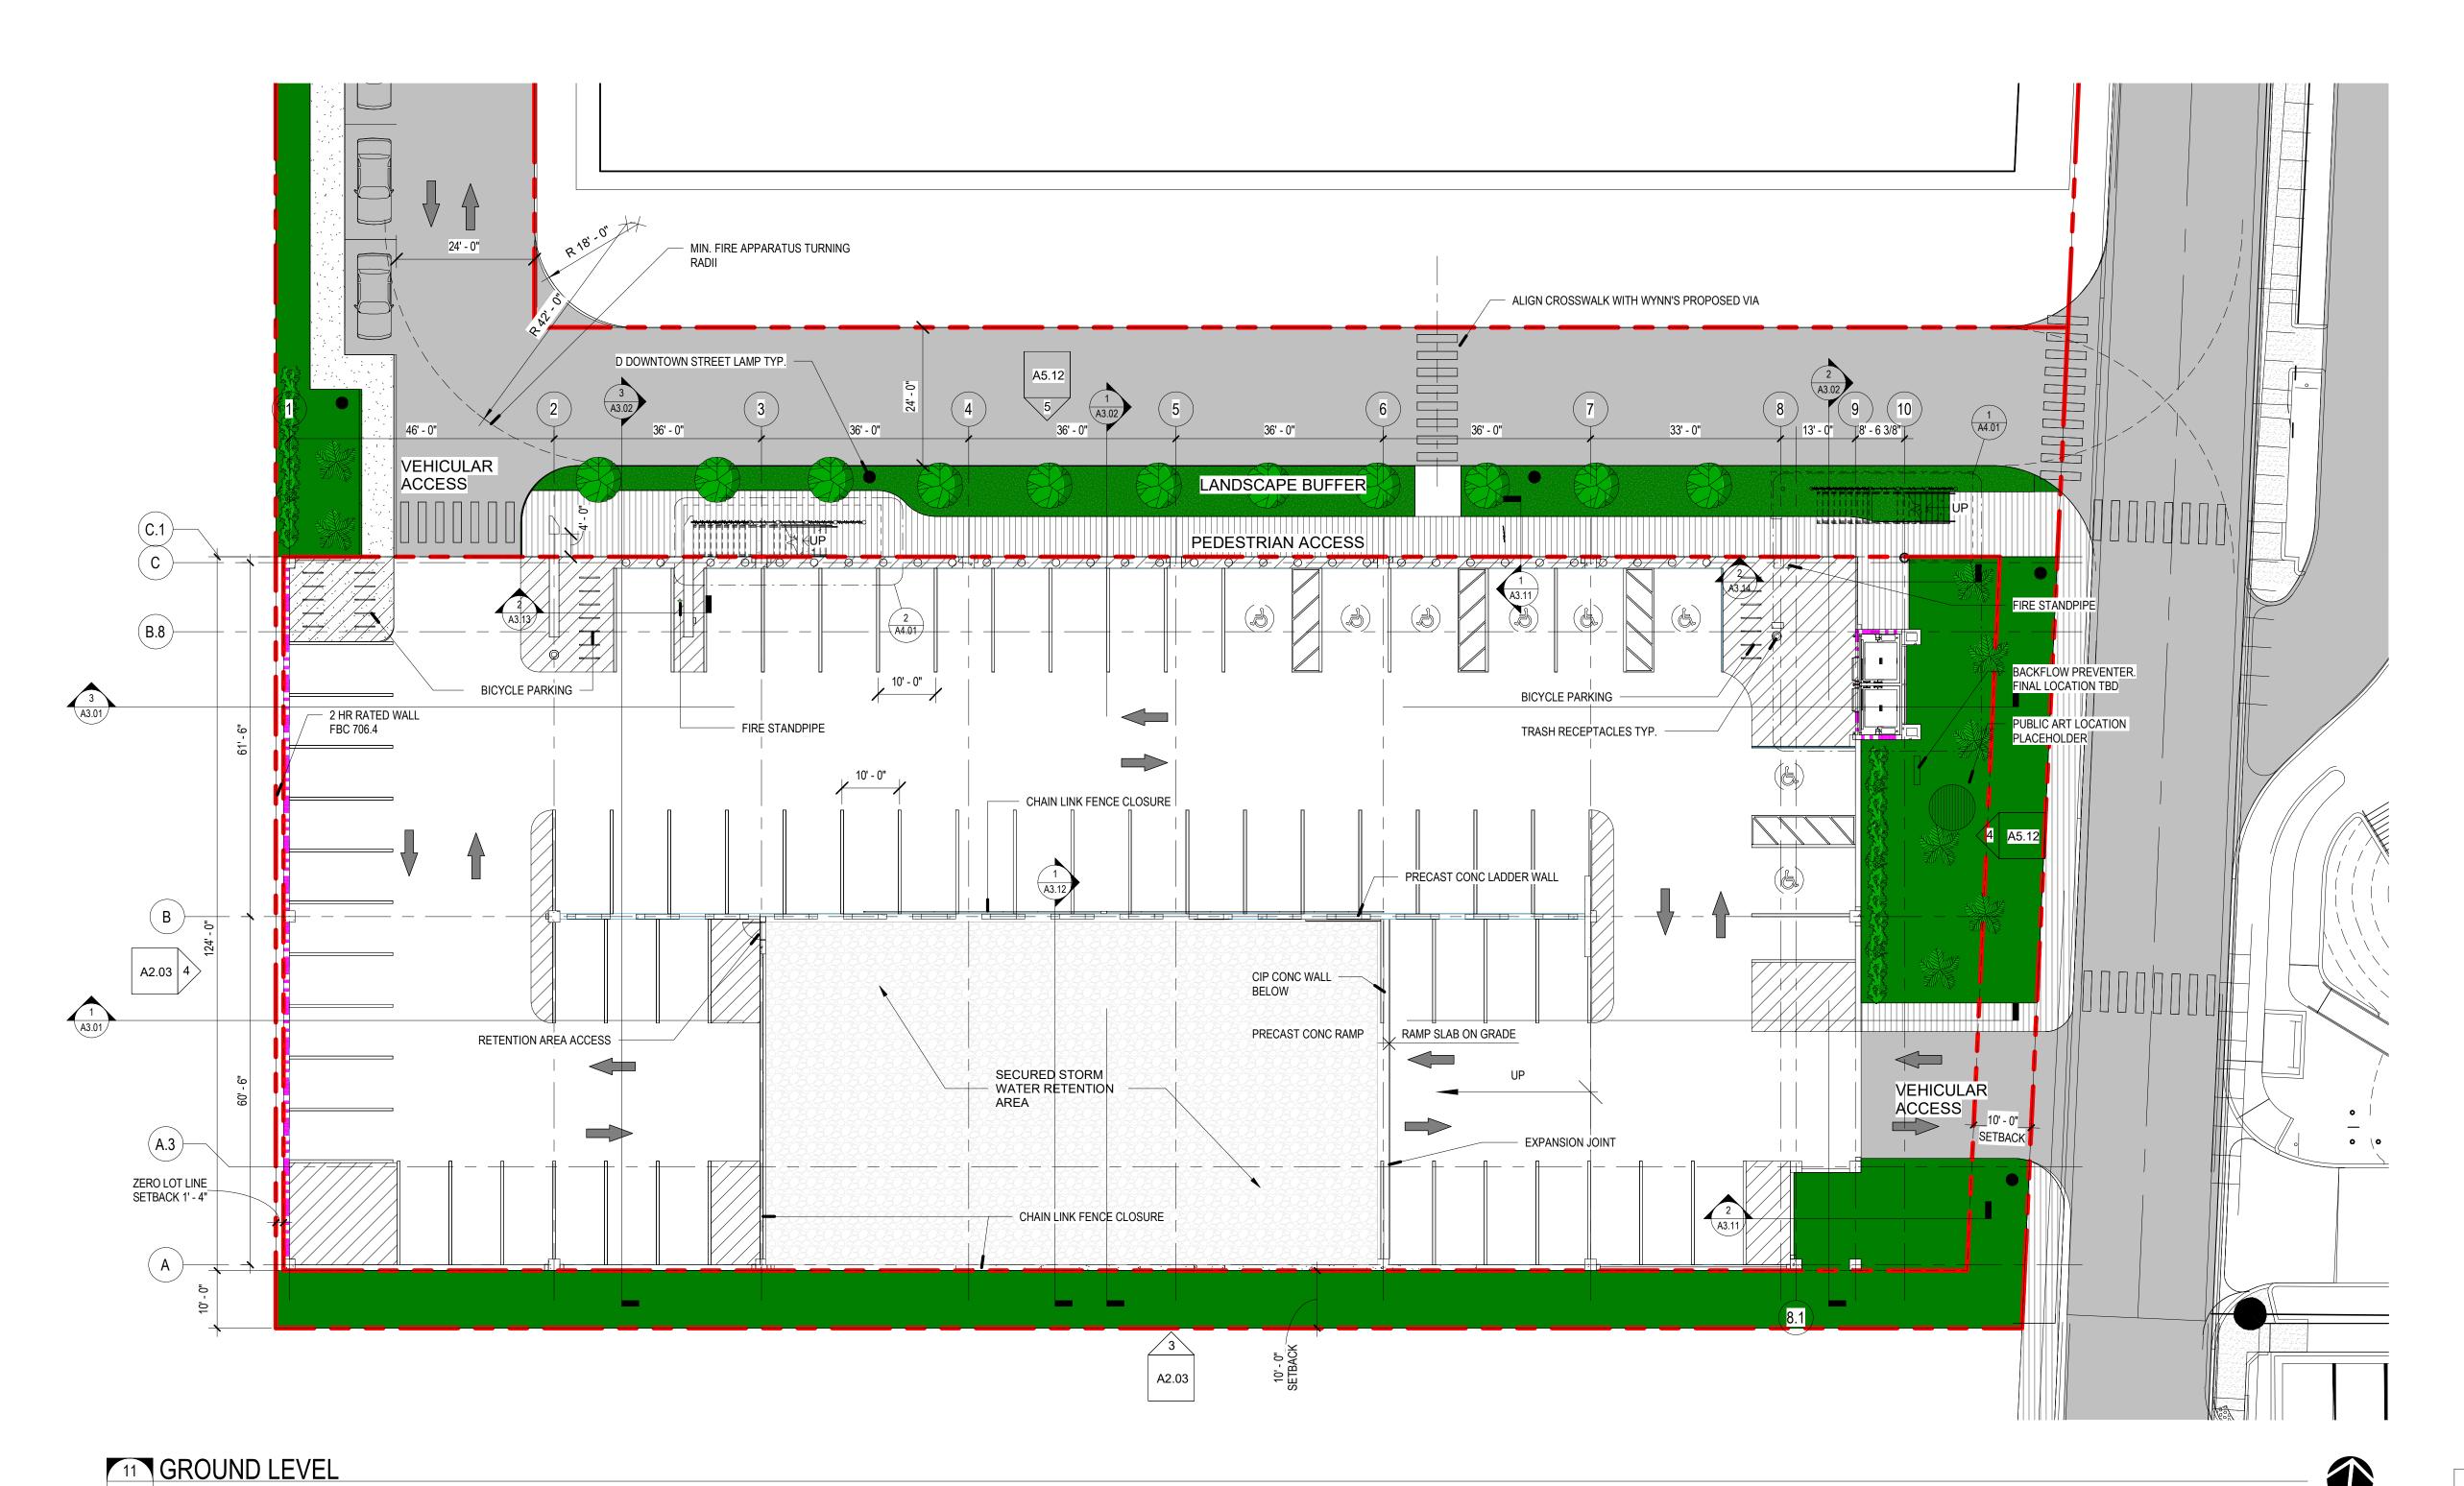

A1.01 1/16" = 1'-0" 1/A2.01

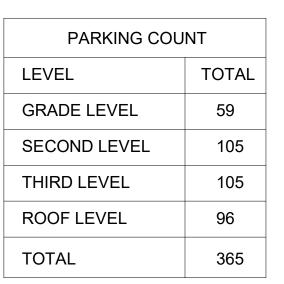

Autodesk Docs://2204.01 - Naples Playhouse Parking Garage/2204.01 - 1st Avenue S. Public Parking Garage_R-22.rvt 1/12/2023 5:45:43 PM

BSSVV

ARCHITECTSINC
License # AA C001863


1500 Jackson Street, Suite 200 Fort Myers, Florida 33901 Phone: 239-278-3838 Fax: 239-275-5356

949 Central Ave.
Naples, Florida 34102
Phone: 239-643-3103 Fax: 239-643-7435

1st Avenue S.
Public Parking
Garage

Owner:
City of Naples

Concultant

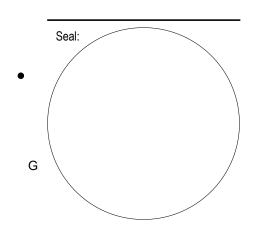

Project Phase:

Design Development


Project #: 2204.01
Project Issued: June/2022
Sheet Issued: --

D C

Copyright © 2022. BSSW Architects, Inc. reserves copyright and other rights restricting these documents to the original site or purpose for which they were prepared. Reproductions, changes or assignments are

Sheet Title:
GROUND FLOOR

A Sheet No.

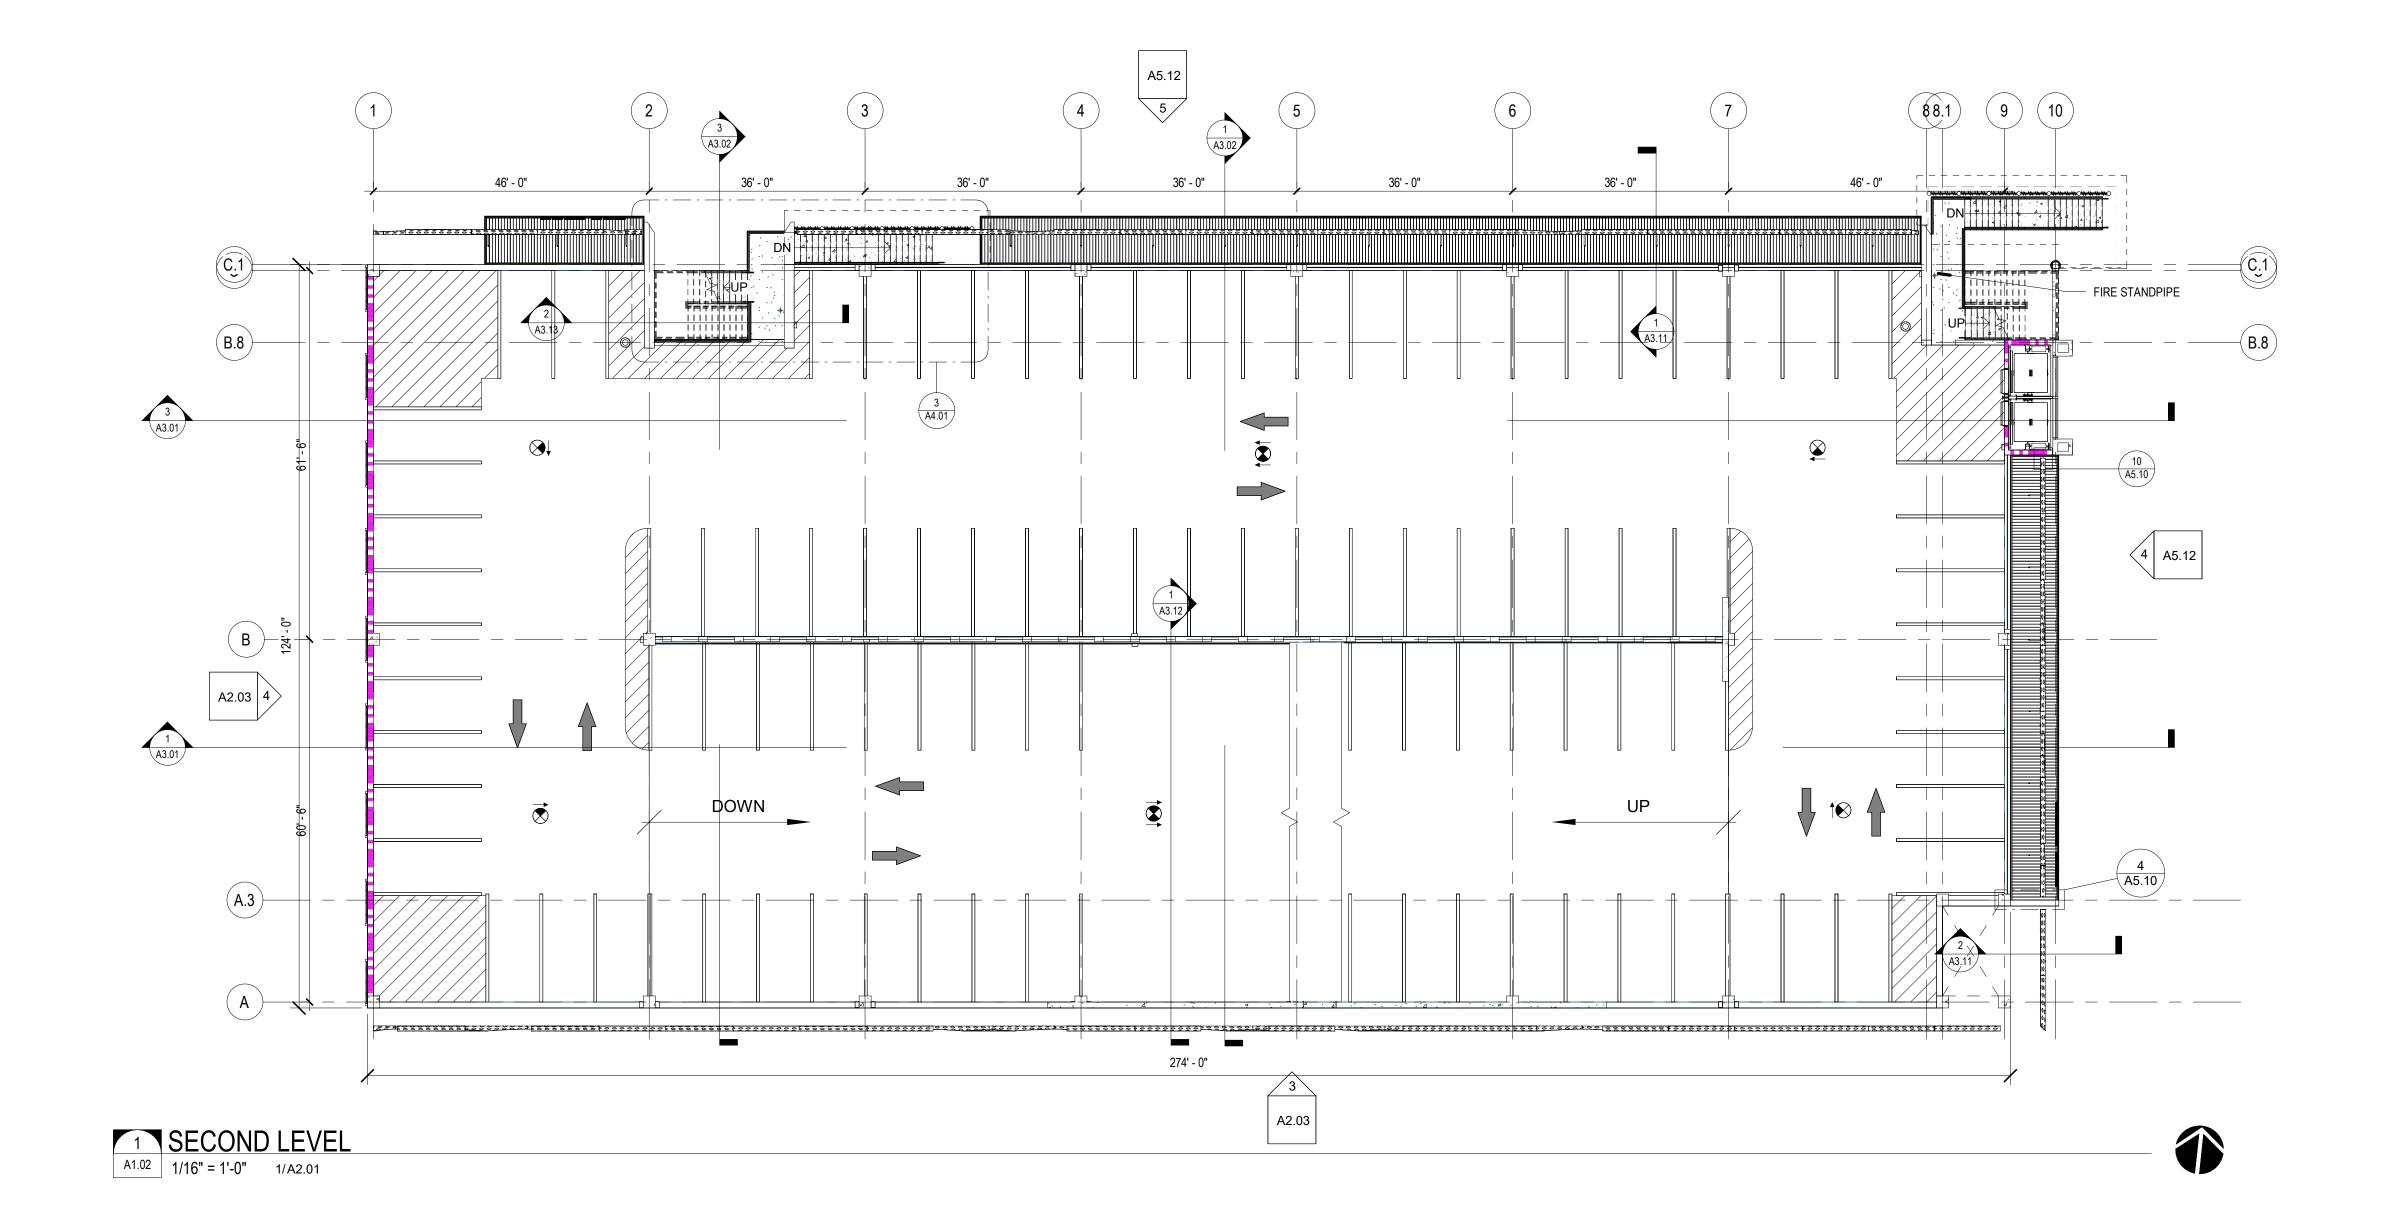




949 Central Ave.
Naples, Florida 34102
Phone: 239-643-3103 Fax: 239-643-7435

Desired

1st Avenue S. Public Parking Garage

Owner:
City of Naples

Consultant:

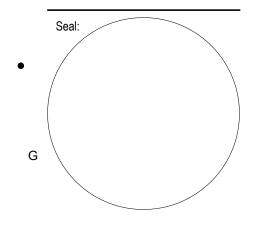

Design Development


Project #: 2204.01
Project Issued: June/2022
Sheet Issued: 01-05-2023

E	No	Date	Revision
•			
D			
D			
•			
0			
С			
•			

Copyright © 2022. BSSW Architects, Inc. reserves copyright and other rights restricting these documents to the original site or purpose for which they were prepared. Reproductions, changes or assignments are

Sheet Title: SECOND FLOOR

Autodesk Docs://2204.01 - Naples Playhouse Parking Garage/2204.01 - 1st Avenue S. Public Parking Garage_R-22.rvt 1/12/2023 5:45:46 PM

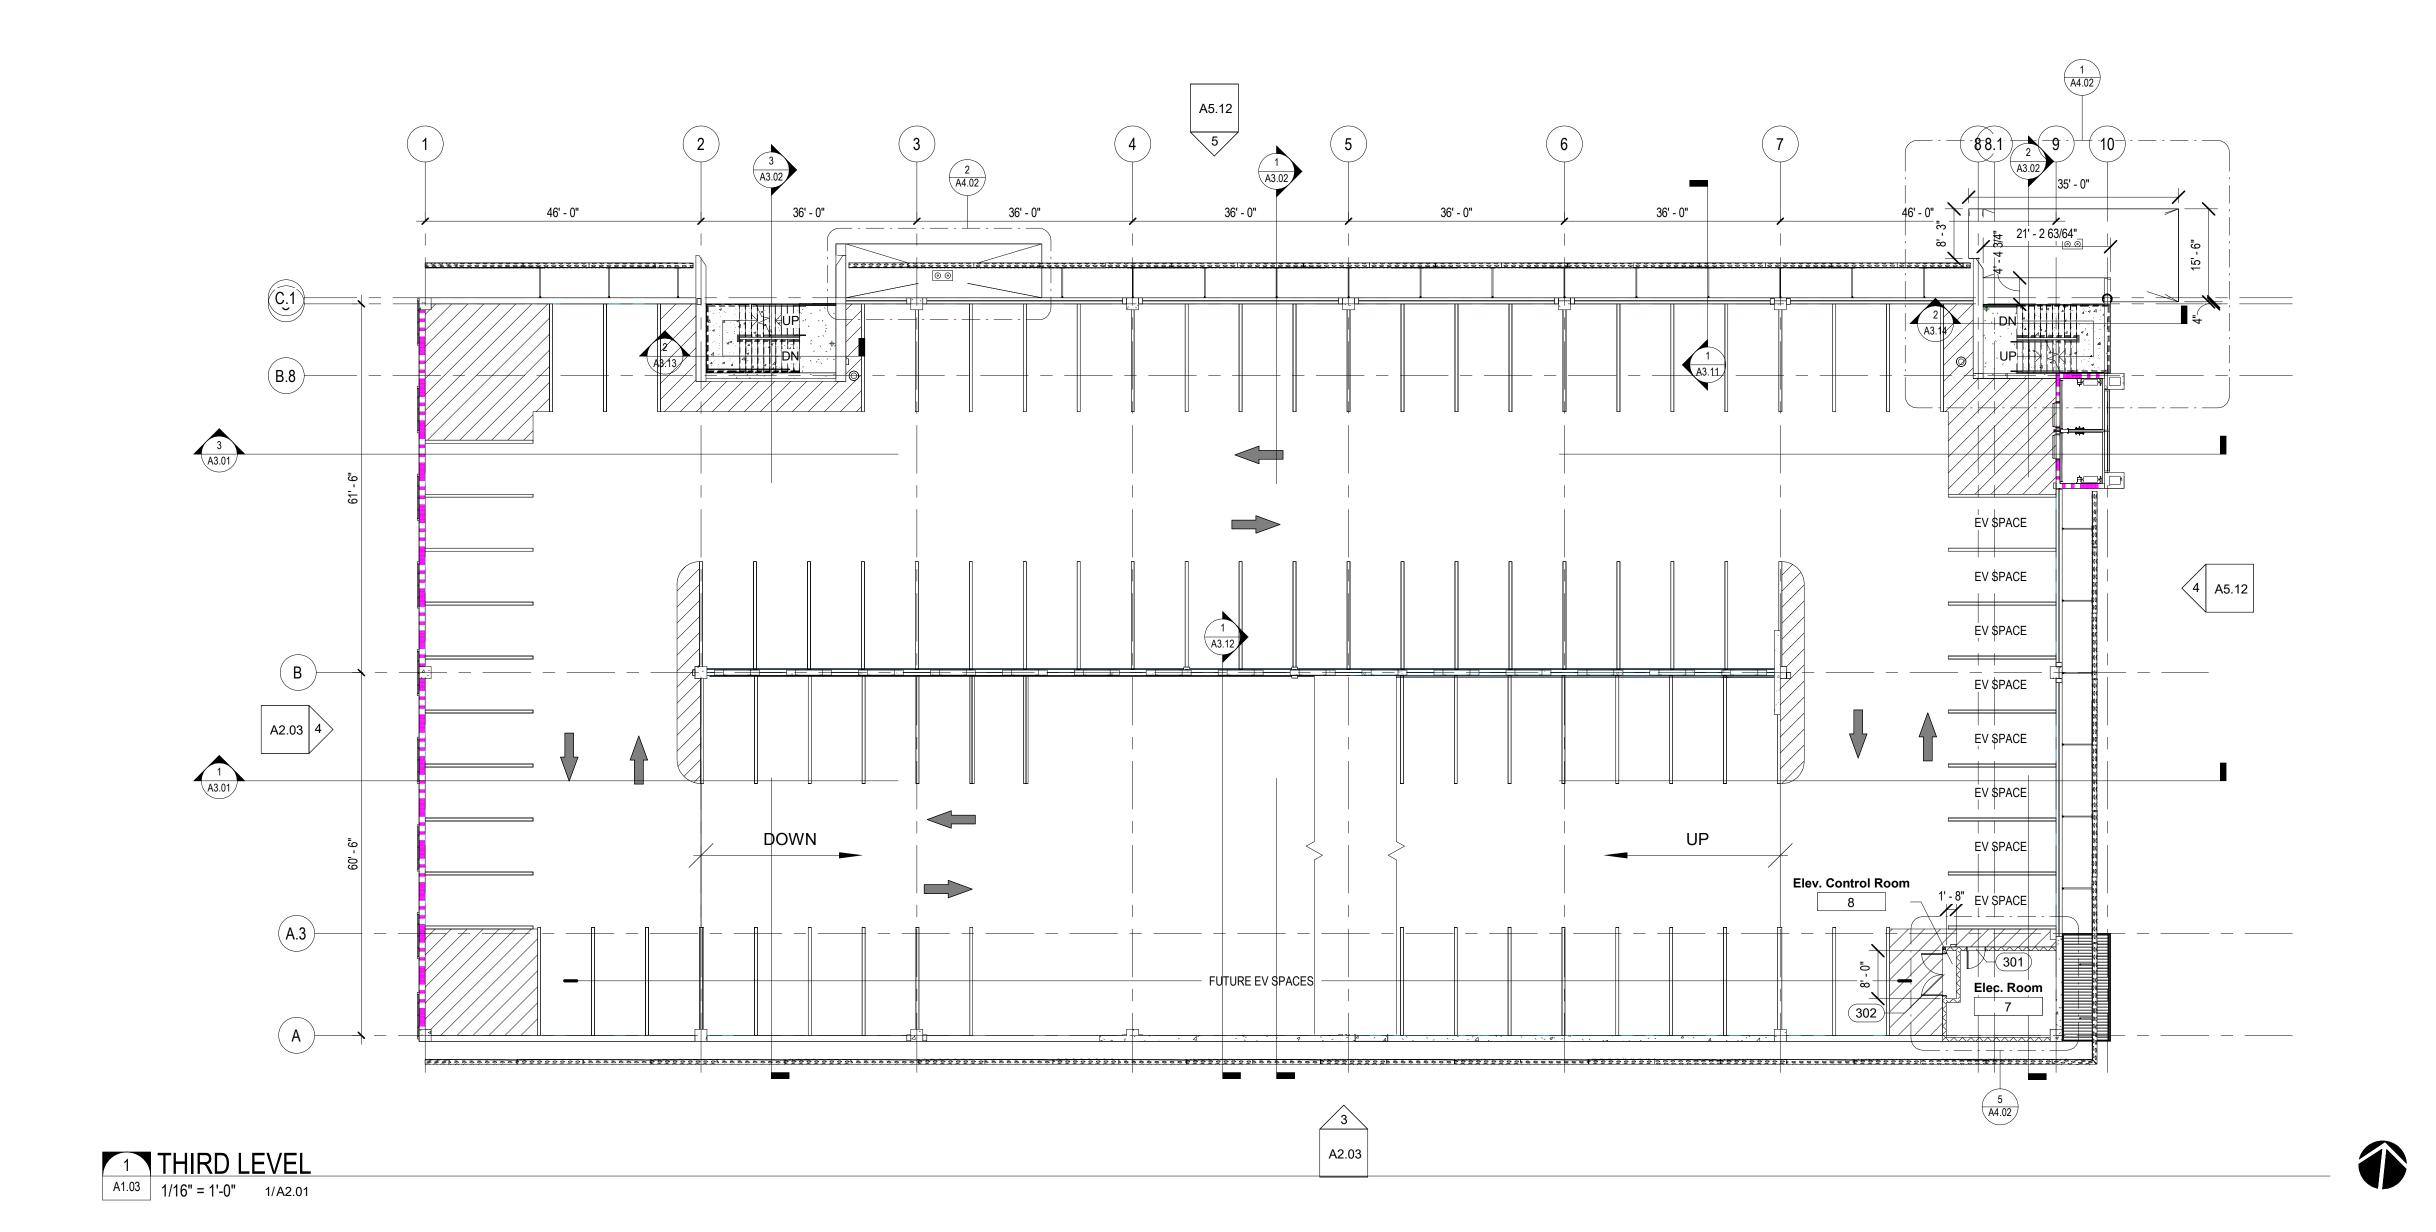




949 Central Ave.
Naples, Florida 34102
Phone: 239-643-3103 Fax: 239-643-7435

1st Avenue S. Public Parking Garage

Owner:
City of Naples

Consultant:

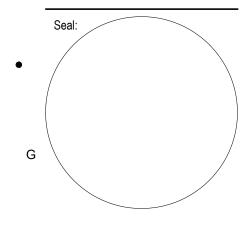

Design Development

Project #: 2204.01
Project Issued: June/2022
Sheet Issued: 01-05-2023


Ε	No	Date	Revision
1			
_			
D			
С			
•			

Copyright © 2022. BSSW Architects, Inc. reserves copyright and other rights restricting these documents to the original site or purpose for which they were prepared. Reproductions, changes or assignments are

Sheet Title: THIRD FLOOR

Sheet No.

Autodesk Docs://2204.01 - Naples Playhouse Parking Garage/2204.01 - 1st Avenue S. Public Parking Garage_R-22.rvt 1/12/2023 5:45:48 PM

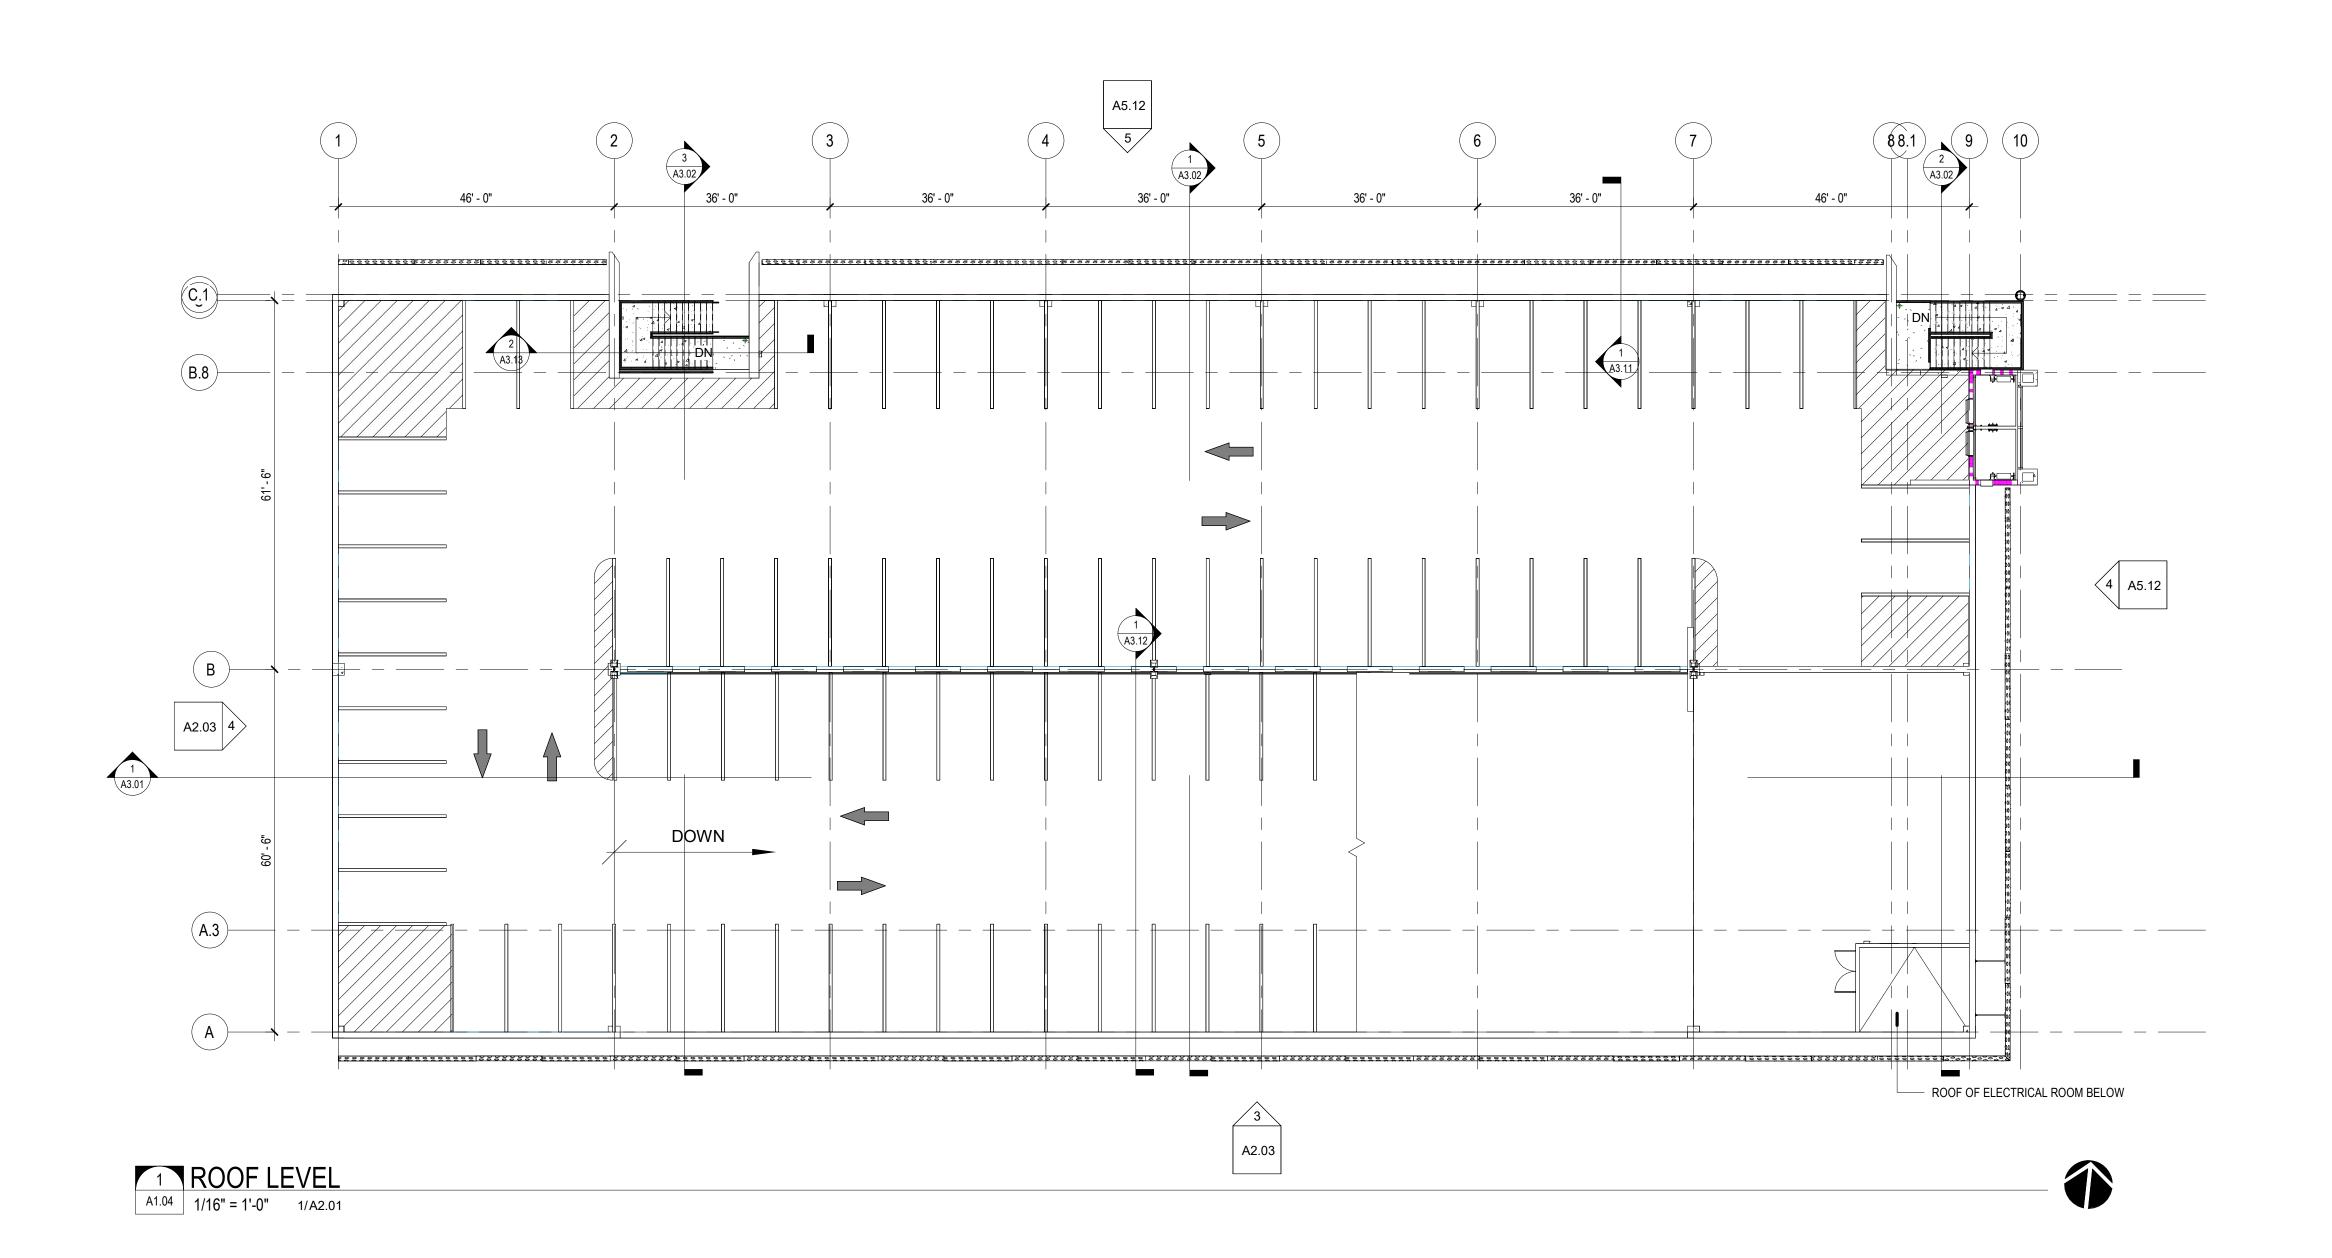




Phone: 239-278-3838 Fax: 239-275-5356

949 Central Ave.
Naples, Florida 34102
Phone: 239-643-3103 Fax: 239-643-7435

1st Avenue S. Public Parking Garage

Owner:
City of Naples

Consultant:

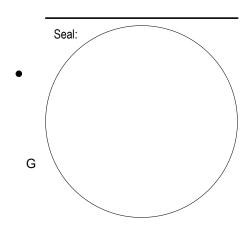

Design Development

Project #: 2204.01
Project Issued: June/2022
Sheet Issued: 01-05-2023

No Date Revision

D


C

Copyright © 2022. BSSW Architects, Inc. reserves copyright and other rights restricting these documents to the original site or purpose for which they were prepared. Reproductions, changes or assignments are

Sheet Title: ROOF LEVEL

Sheet No.

Autodesk Docs://2204.01 - Naples Playhouse Parking Garage/2204.01 - 1st Avenue S. Public Parking Garage_R-22.rvt 1/12/2023 5:45:50 PM

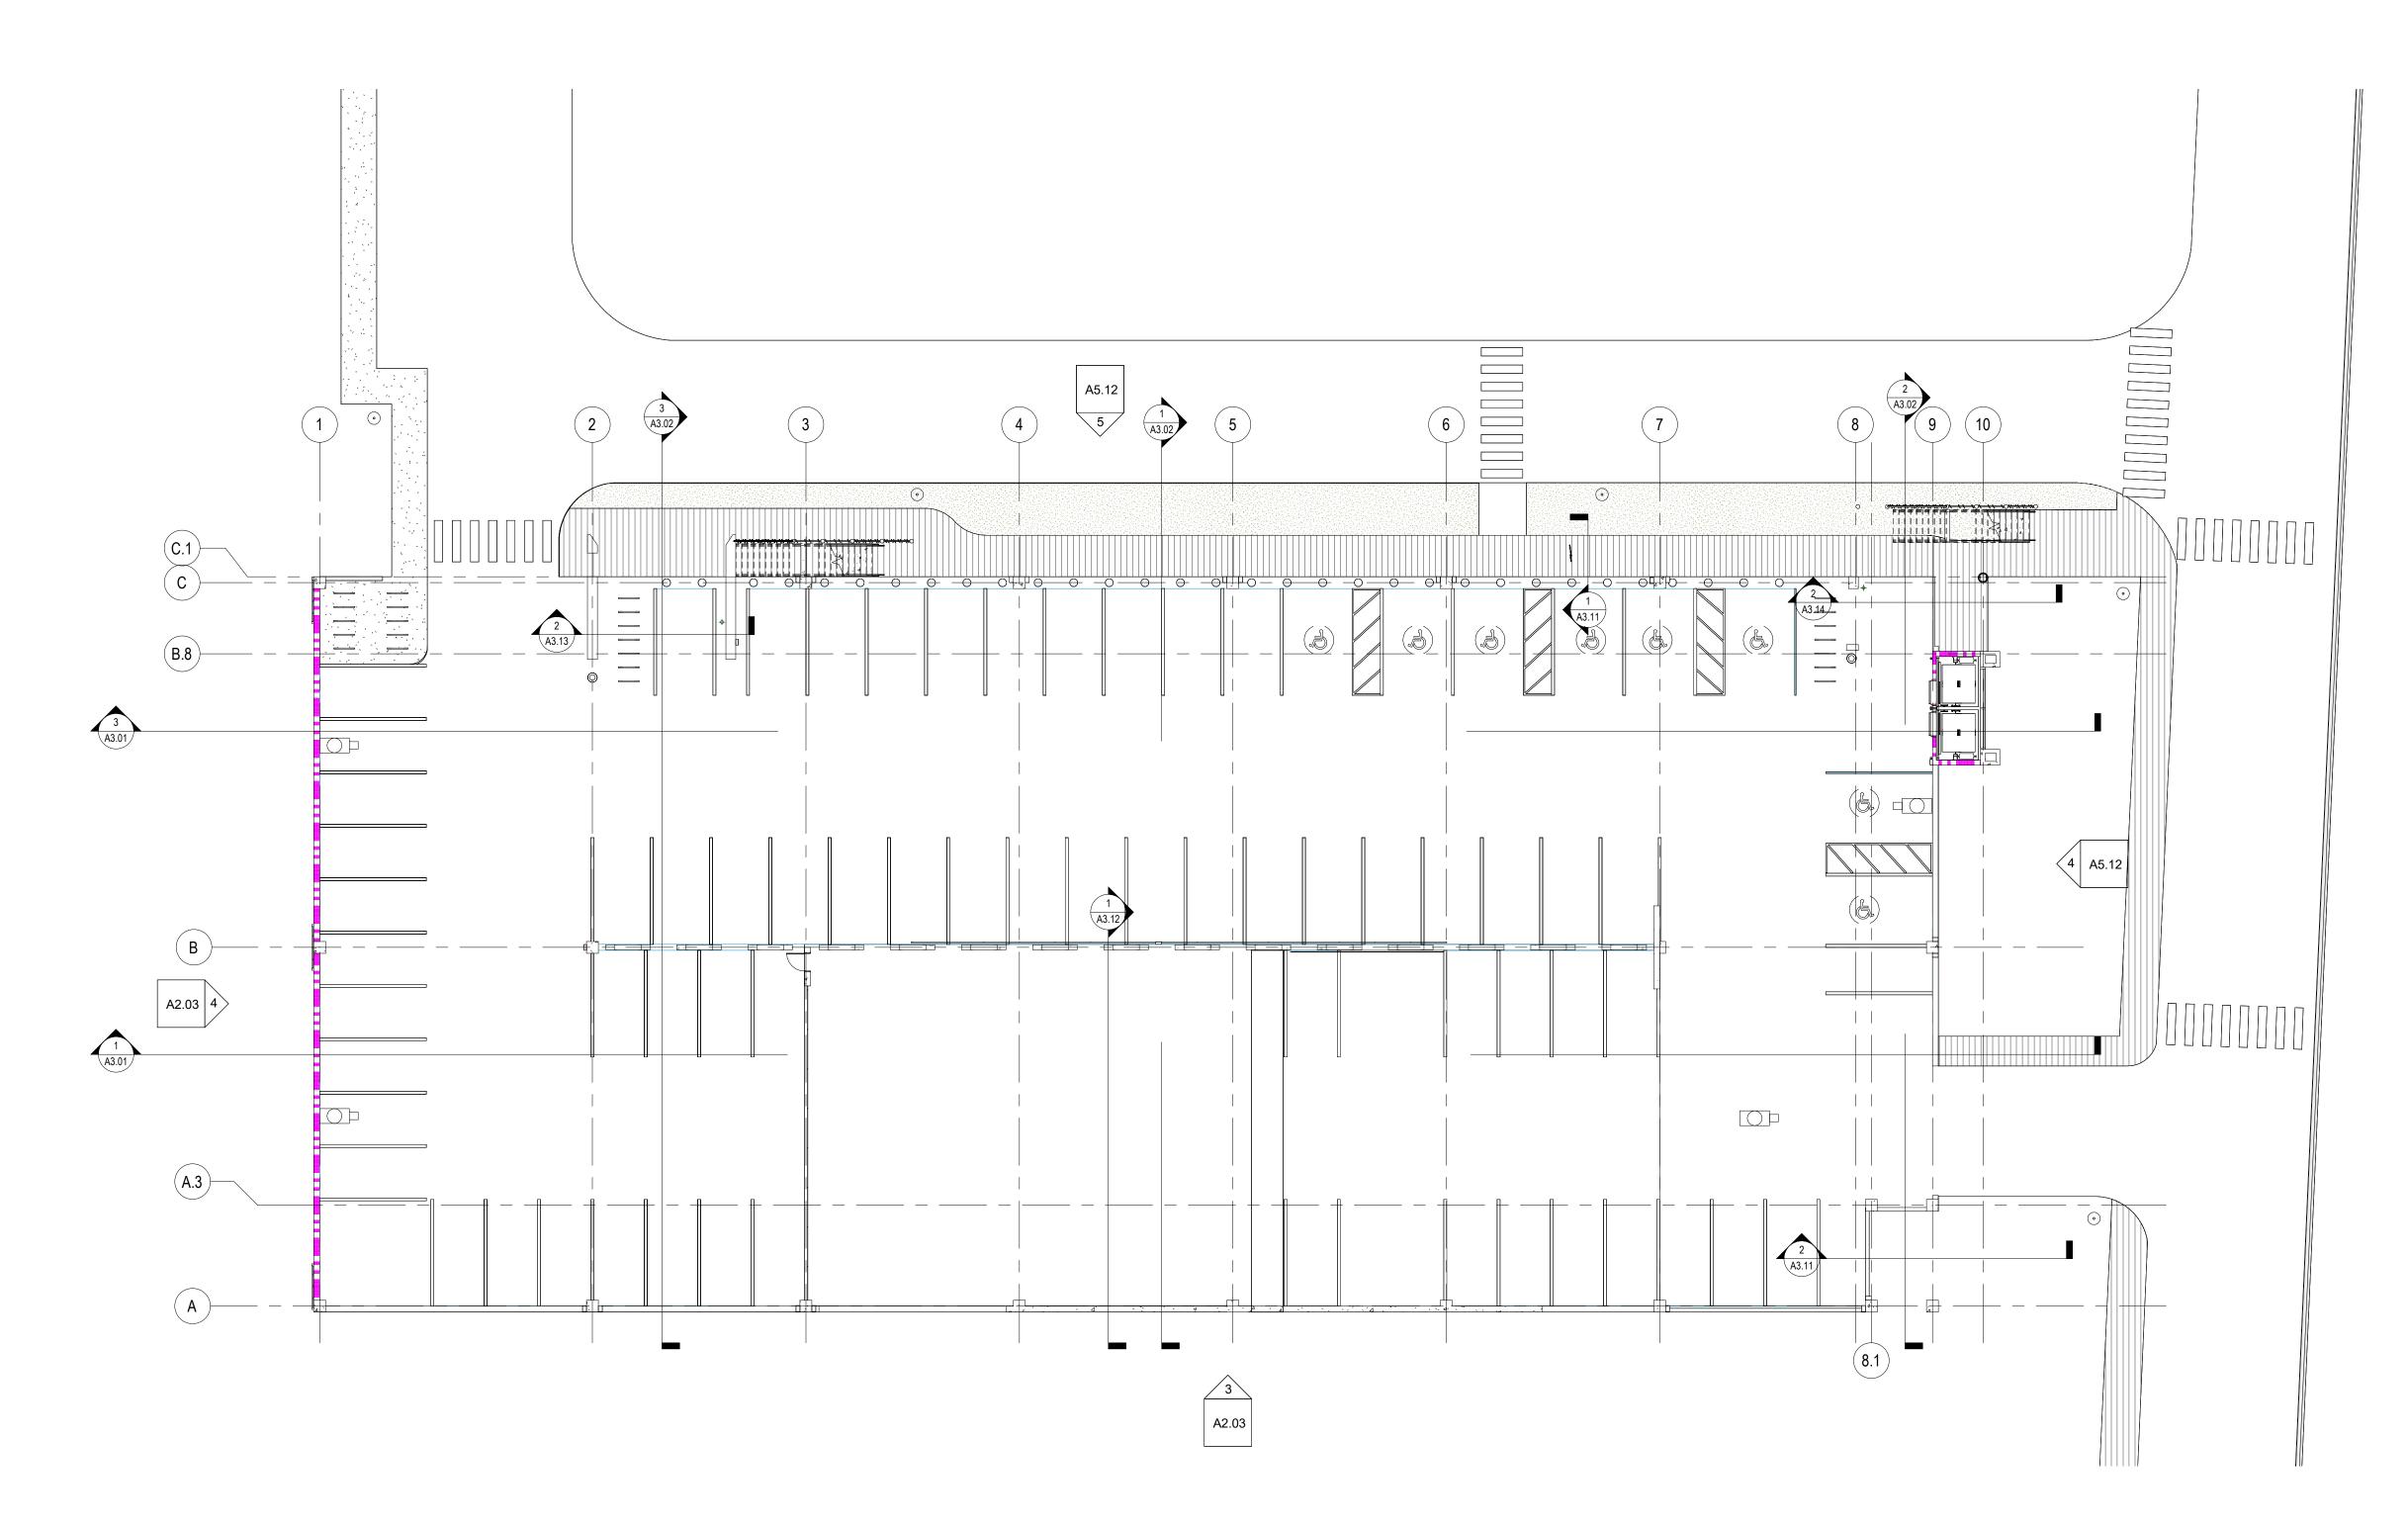

11 Ground Level - CCTV Camera Location Plan
A1.05 1/16" = 1'-0" 1/A2.01



LEGEND

DESCRIPTION CCTV CAMERA

GENERAL NOTES

CAMERA LOCATIONS ARE APPROXIMATE. THE CONTRACTOR SHALL COORDINATE THE EXACT LOCATION AND COVERAGE AREA OF EACH CAMERA WITH THE OWNER'S DESIGNATED REPRESENTATIVE PRIOR TO INSTALLATION. CAMERA FIELDS OF VIEW SHALL BE COORDINATED WITH AND APPROVED BY THE OWNER WITH THE USE OF A HANDHELD VIEWFINDER (CHUGAI VM300 OR EQUIVALENT) TO DETERMINE THE BEST LENS AND CAMERA ANGLE. FINAL CAMERA LOCATIONS SHALL BE ABLE TO MOVE UP TO 30 FEET FROM LOCATION SHOWN WITHOUT ADDITIONAL COST. PARTICULAR ATTENTION SHALL BE GIVEN TO COORDINATION OF CAMERA LOCATIONS RELATIVE TO ANY OBSTRUCTIONS, AND OTHER CAMERA VIEWS. AFTER FINAL

OPERATION, CONTRACTOR SHALL COORDINATE WITH OWNER FOR EXACT CAMERA ANGLES AND LENS SETTINGS.

Autodesk Docs://2204.01 - Naples Playhouse Parking Garage/2204.01 - 1st Avenue S. Public Parking Garage_R-22.rvt 1/12/2023 5:45:51 PM


LOCATION IS DETERMINED AND THE SYSTEM IS IN

A R C H I T E C T S I N C License # AA C001863

1500 Jackson Street, Suite 200 Fort Myers, Florida 33901 Phone: 239-278-3838 Fax: 239-275-5356

949 Central Ave.
Naples, Florida 34102
Phone: 239-643-3103 Fax: 239-643-7435

1st Avenue S. **Public Parking** Garage

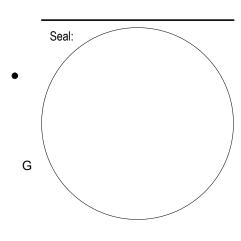

Design Development


Project #: 2204.01 Project Issued: June/2022 Sheet Issued: 01-12-2023

Е	No	Date	Revision
•			
D			
D			
•			
0			
С			
•			

Copyright © 2022. BSSW Architects, Inc. reserves copyright and other rights restricting these documents to the original site or purpose for which they were prepared. Reproductions, changes or assignments are

Ground Level - CCTV Camera Location Plan

A Sheet No.

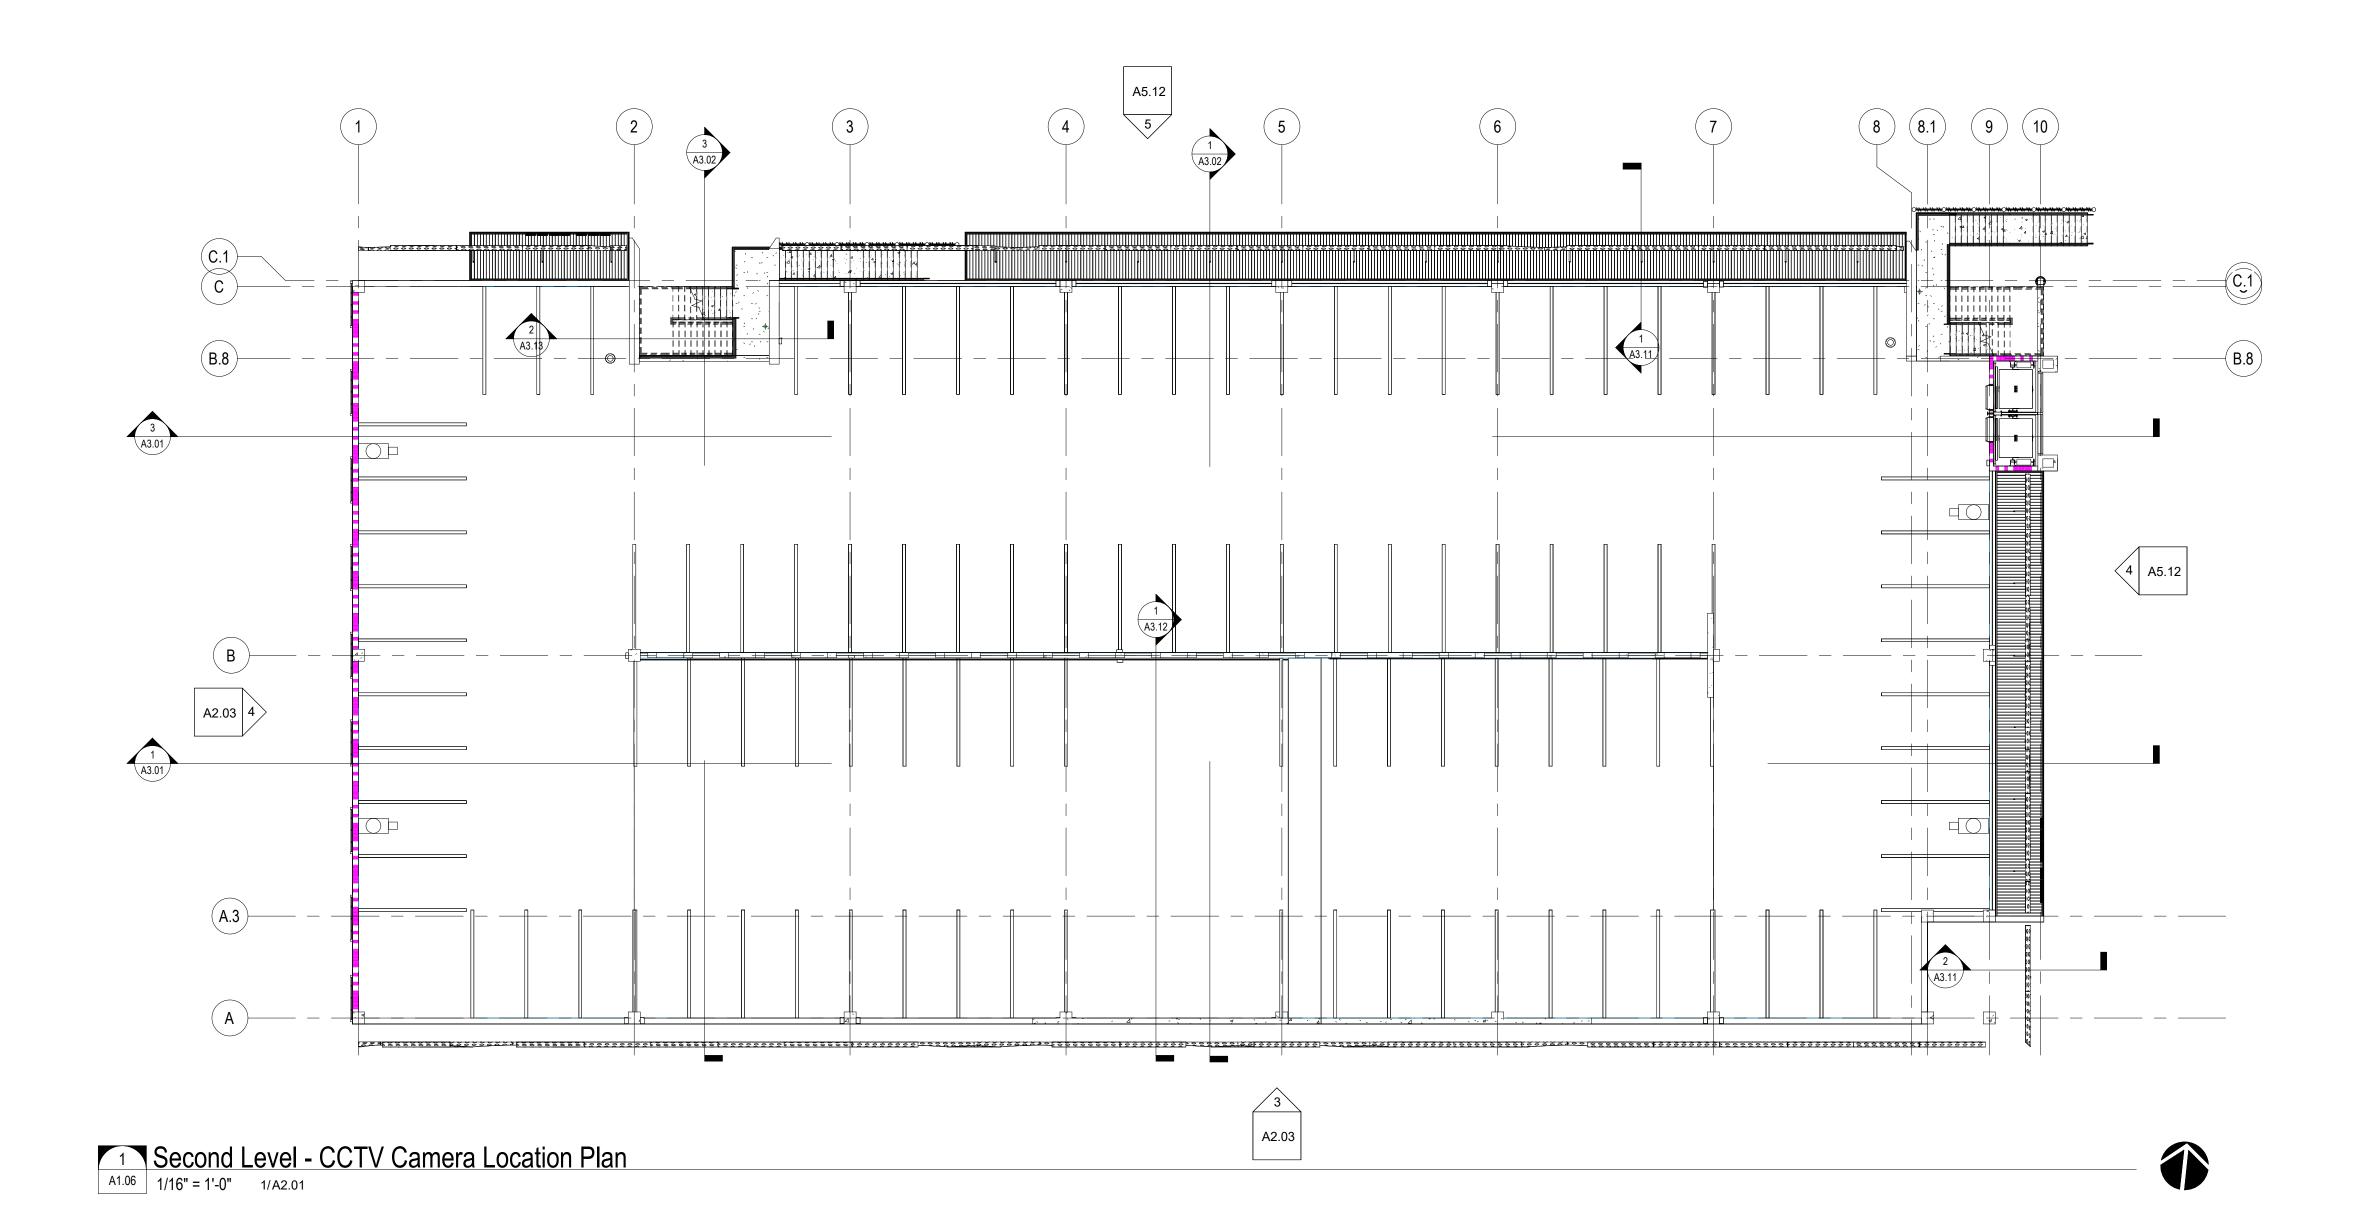

A R C H I T E C T S I N C License # AA C001863

1500 Jackson Street, Suite 200 Fort Myers, Florida 33901 Phone: 239-278-3838 Fax: 239-275-5356


949 Central Ave.
Naples, Florida 34102
Phone: 239-643-3103 Fax: 239-643-7435

Desired

1st Avenue S. Public Parking Garage

Owner:
City of Naples

Conquitant

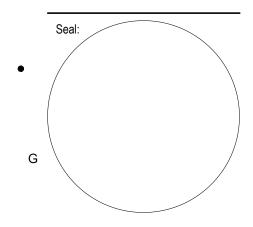

Project Phase: Design Development

Project #: 2204.01
Project Issued: June/2022
Sheet Issued: 01-12-2023

Е	No	Date	Revision
•			
D			
D			
•			
0			
С			

LEGEND

SYMBOL

GENERAL NOTES

DESCRIPTION

CCTV CAMERA

TO INSTALLATION. CAMERA FIELDS OF VIEW SHALL BE

LOCATION IS DETERMINED AND THE SYSTEM IS IN OPERATION, CONTRACTOR SHALL COORDINATE

CAMERA LOCATIONS ARE APPROXIMATE. THE CONTRACTOR SHALL COORDINATE THE EXACT LOCATION AND COVERAGE AREA OF EACH CAMERA WITH THE OWNER'S DESIGNATED REPRESENTATIVE PRIOR

COORDINATED WITH AND APPROVED BY THE OWNER WITH THE USE

LOCATIONS SHALL BE ABLE TO MOVE UP TO 30 FEET FROM LOCATION

SHOWN WITHOUT ADDITIONAL COST. PARTICULAR ATTENTION SHALL BE GIVEN TO COORDINATION OF CAMERA LOCATIONS RELATIVE TO ANY OBSTRUCTIONS, AND OTHER CAMERA VIEWS. AFTER FINAL

OF A HANDHELD VIEWFINDER (CHUGAI VM300 OR EQUIVALENT) TO

DETERMINE THE BEST LENS AND CAMERA ANGLE. FINAL CAMERA

WITH OWNER FOR EXACT CAMERA ANGLES AND LENS SETTINGS.

Copyright © 2022. BSSW Architects, Inc. reserves copyright and other rights restricting these documents to the original site or purpose for which they were prepared. Reproductions,


changes or assignments are prohibited.

Second Level - CCTV

Camera Location Plan

Sheet No.

Autodesk Docs://2204.01 - Naples Playhouse Parking Garage/2204.01 - 1st Avenue S. Public Parking Garage_R-22.rvt 1/12/2023 5:45:53 PM

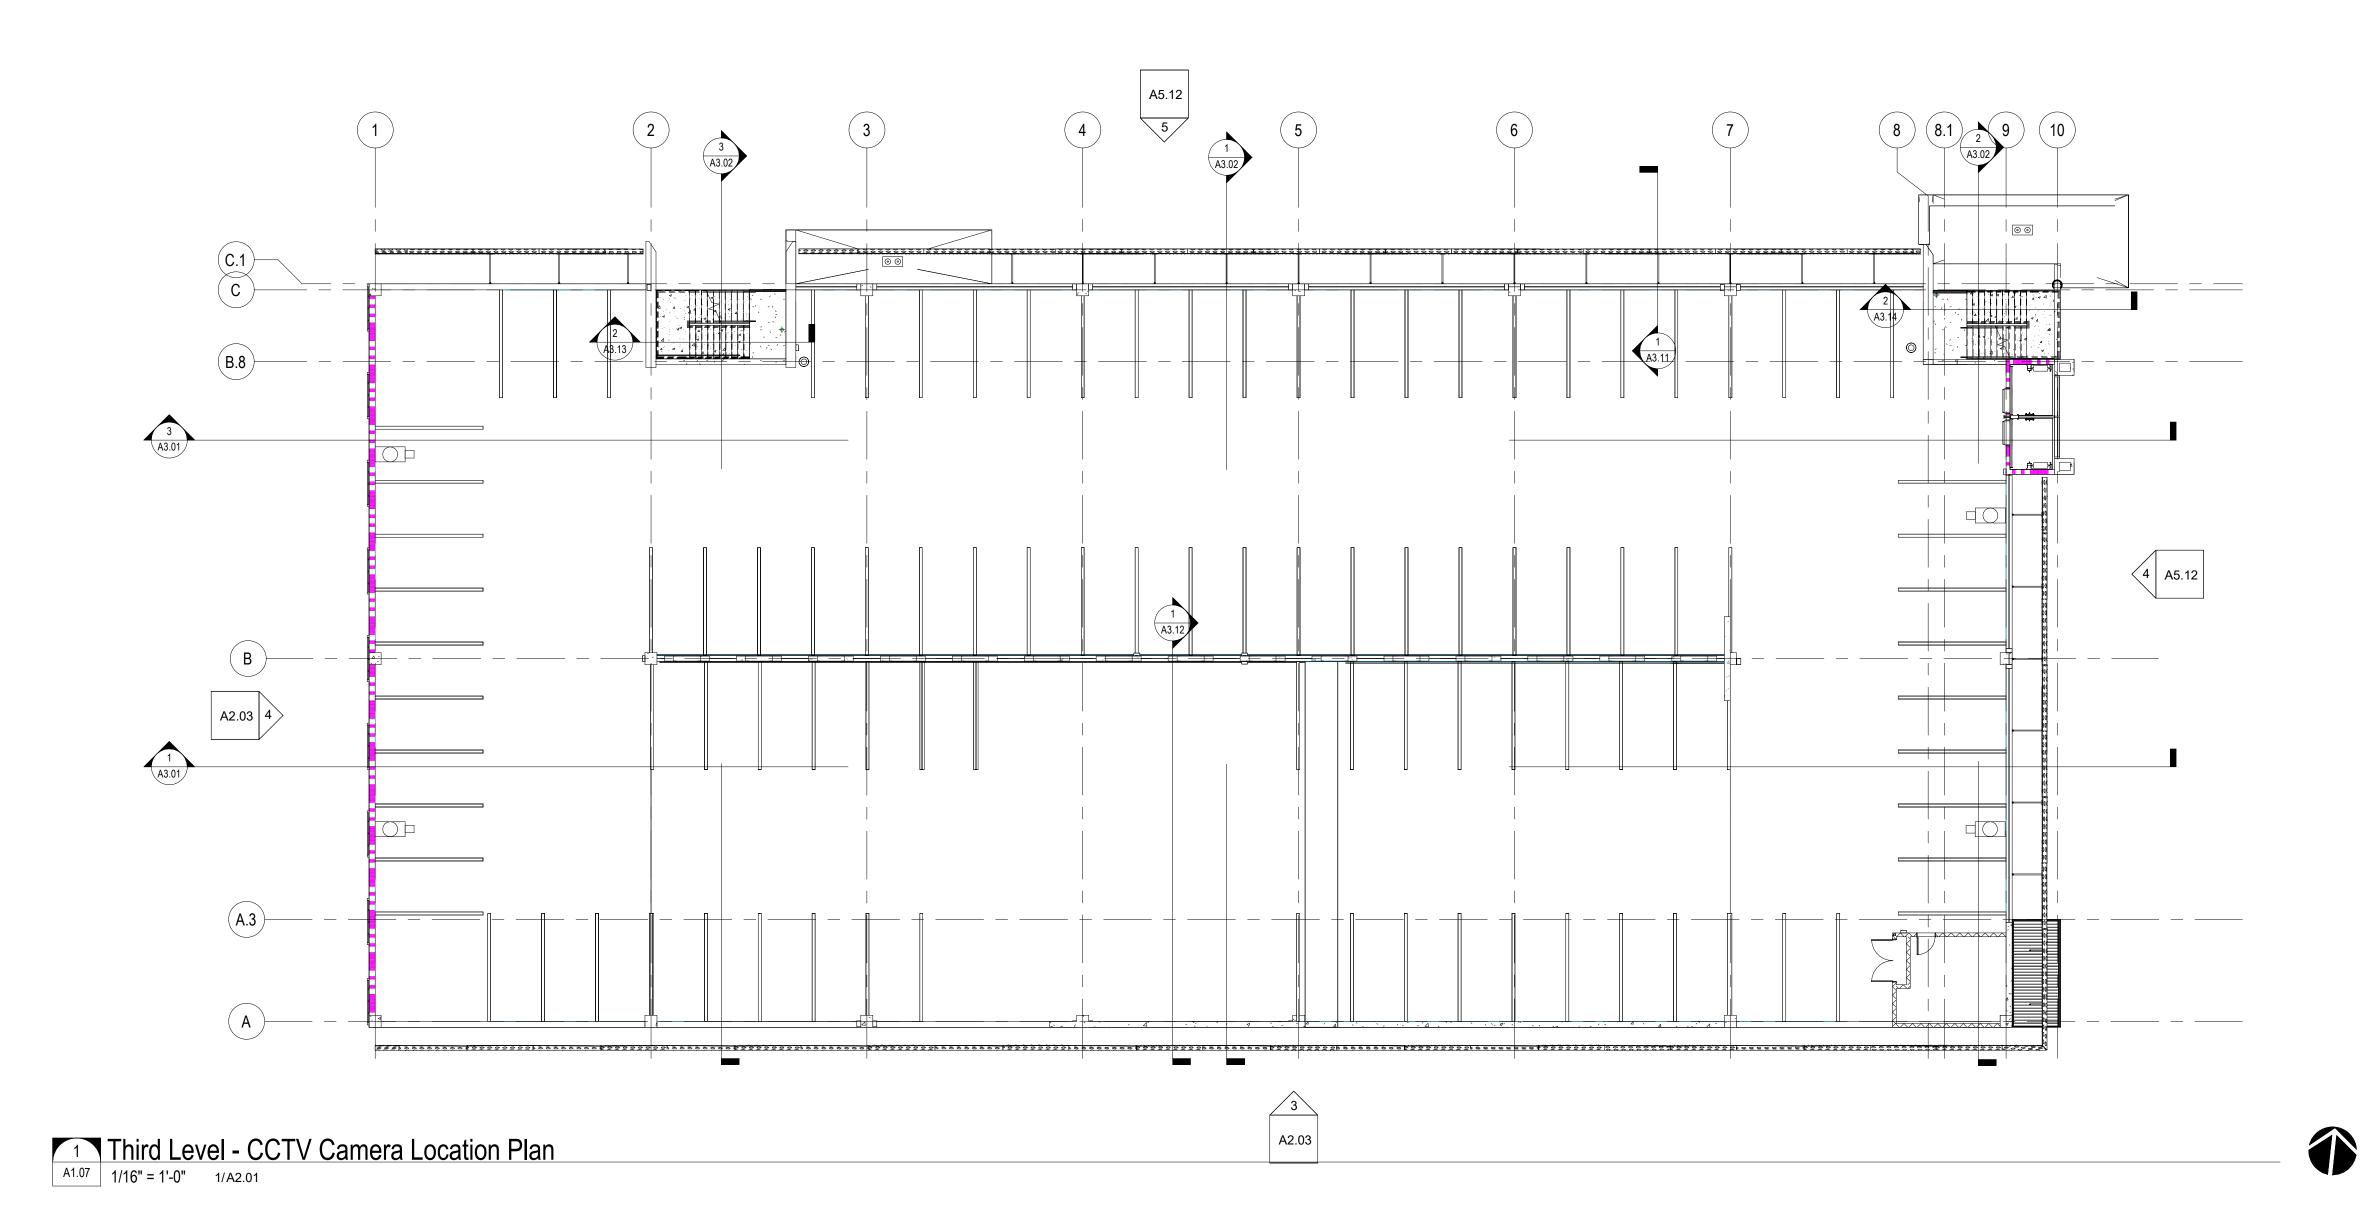




1500 Jackson Street, Suite 200 Fort Myers, Florida 33901 Phone: 239-278-3838 Fax: 239-275-5356 949 Central Ave.
Naples, Florida 34102
Phone: 239-643-3103 Fax: 239-643-7435

1st Avenue S. **Public Parking** Garage

Owner:
City of Naples

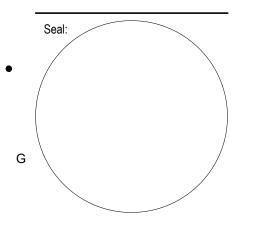

Design Development

Project #: 2204.01 Project Issued: June/2022 Sheet Issued: 01-12-2023

	No	Date	Revision
)			
D			
D			
_			
С			

Copyright © 2022. BSSW Architects, Inc. reserves copyright and other rights restricting these documents to the original site or purpose for which they were prepared. Reproductions, changes or assignments are

Sheet Title: Third Level - CCTV

Camera Location Plan


A Sheet No.

LEGEND

DESCRIPTION CCTV CAMERA

GENERAL NOTES

CAMERA LOCATIONS ARE APPROXIMATE. THE CONTRACTOR SHALL COORDINATE THE EXACT LOCATION AND COVERAGE AREA OF EACH CAMERA WITH THE OWNER'S DESIGNATED REPRESENTATIVE PRIOR TO INSTALLATION. CAMERA FIELDS OF VIEW SHALL BE COORDINATED WITH AND APPROVED BY THE OWNER WITH THE USE OF A HANDHELD VIEWFINDER (CHUGAI VM300 OR EQUIVALENT) TO DETERMINE THE BEST LENS AND CAMERA ANGLE. FINAL CAMÉRA LOCATIONS SHALL BE ABLE TO MOVE UP TO 30 FEET FROM LOCATION SHOWN WITHOUT ADDITIONAL COST. PARTICULAR ATTENTION SHALL BE GIVEN TO COORDINATION OF CAMERA LOCATIONS RELATIVE TO ANY OBSTRUCTIONS, AND OTHER CAMERA VIEWS. AFTER FINAL LOCATION IS DETERMINED AND THE SYSTEM IS IN OPERATION, CONTRACTOR SHALL COORDINATE WITH OWNER FOR EXACT CAMERA ANGLES AND LENS SETTINGS.

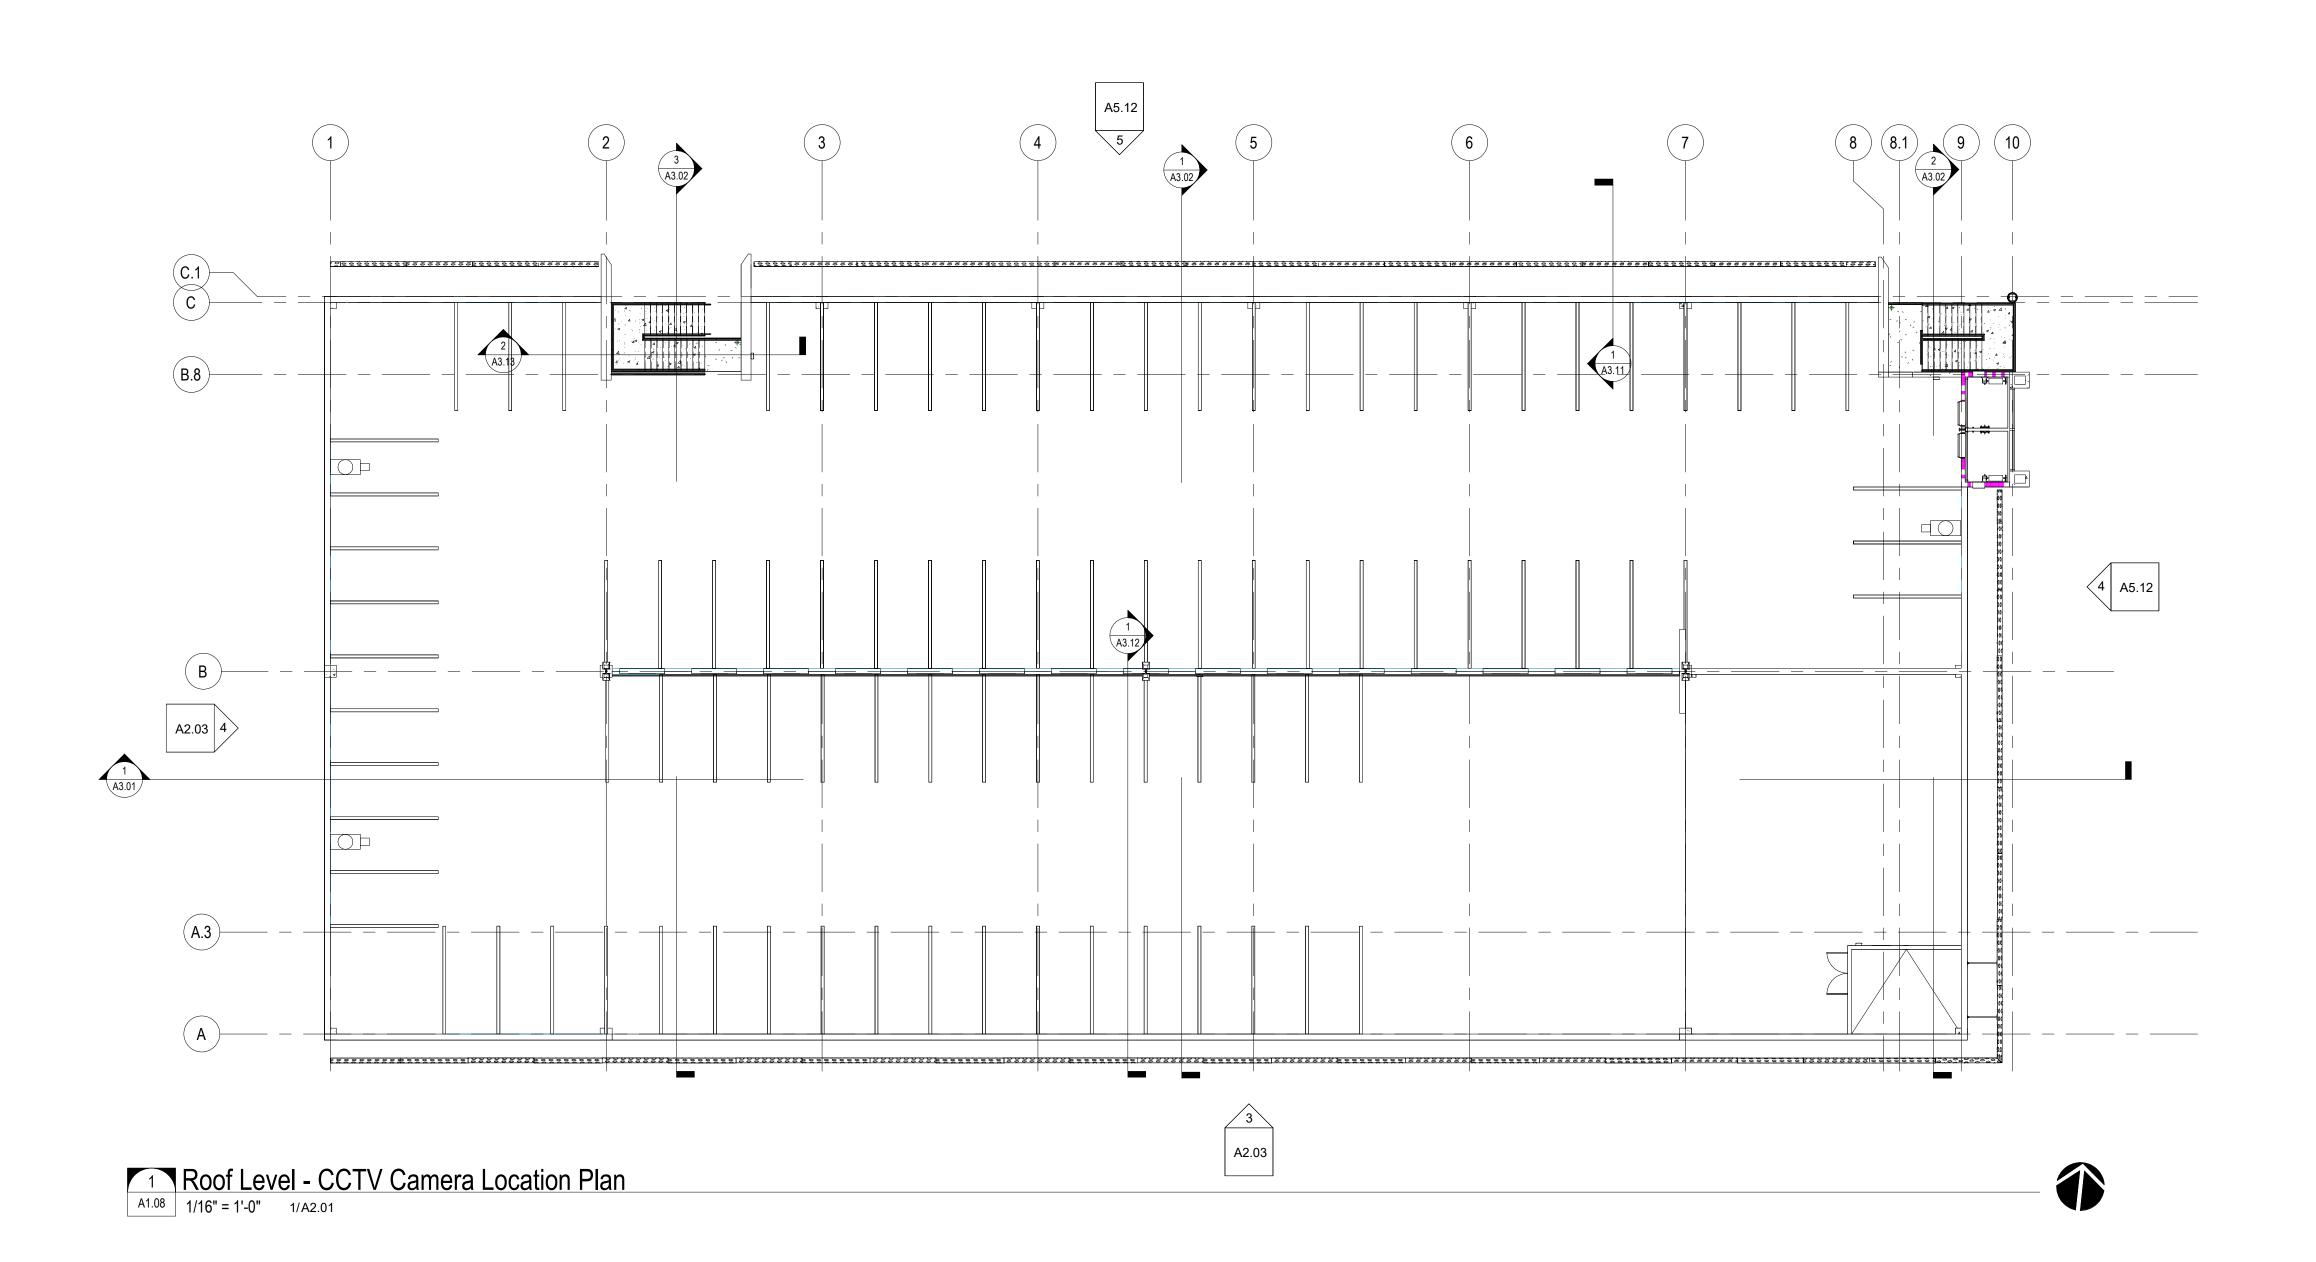

BSSV

1500 Jackson Street, Suite 200 Fort Myers, Florida 33901 Phone: 239-278-3838 Fax: 239-275-5356


License # AA C001863

949 Central Ave.
Naples, Florida 34102
Phone: 239-643-3103 Fax: 239-643-7435

1st Avenue S. Public Parking Garage

Owner:
City of Naples

Consultant:

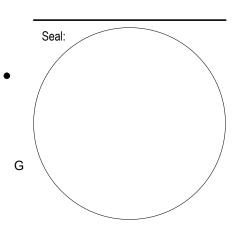

Design Development

Project #: 2204.01
Project Issued: June/2022
Sheet Issued: 01-12-2023

Е	No	Date	Revision
•			
D			
•			
С			
Ü			

Copyright © 2022. BSSW Architects, Inc. reserves copyright and other rights restricting these documents to the original site or purpose for which they were prepared. Reproductions, changes or assignments are

LEGEND

GENERAL NOTES

DESCRIPTION

CCTV CAMERA

TO INSTALLATION. CAMERA FIELDS OF VIEW SHALL BE

LOCATION IS DETERMINED AND THE SYSTEM IS IN OPERATION, CONTRACTOR SHALL COORDINATE

CAMERA LOCATIONS ARE APPROXIMATE. THE CONTRACTOR SHALL

COORDINATE THE EXACT LOCATION AND COVERAGE AREA OF EACH CAMERA WITH THE OWNER'S DESIGNATED REPRESENTATIVE PRIOR

COORDINATED WITH AND APPROVED BY THE OWNER WITH THE USE OF A HANDHELD VIEWFINDER (CHUGAI VM300 OR EQUIVALENT) TO DETERMINE THE BEST LENS AND CAMERA ANGLE. FINAL CAMERA LOCATIONS SHALL BE ABLE TO MOVE UP TO 30 FEET FROM LOCATION SHOWN WITHOUT ADDITIONAL COST. PARTICULAR ATTENTION SHALL BE GIVEN TO COORDINATION OF CAMERA LOCATIONS RELATIVE TO

ANY OBSTRUCTIONS, AND OTHER CAMERA VIEWS. AFTER FINAL

WITH OWNER FOR EXACT CAMERA ANGLES AND LENS SETTINGS.

Autodesk Docs://2204.01 - Naples Playhouse Parking Garage/2204.01 - 1st Avenue S. Public Parking Garage_R-22.rvt 1/12/2023 5:45:57 PM


prohibited.


Sheet Title:

Roof Level - CCTV

Camera Location Plan

A Sheet No.

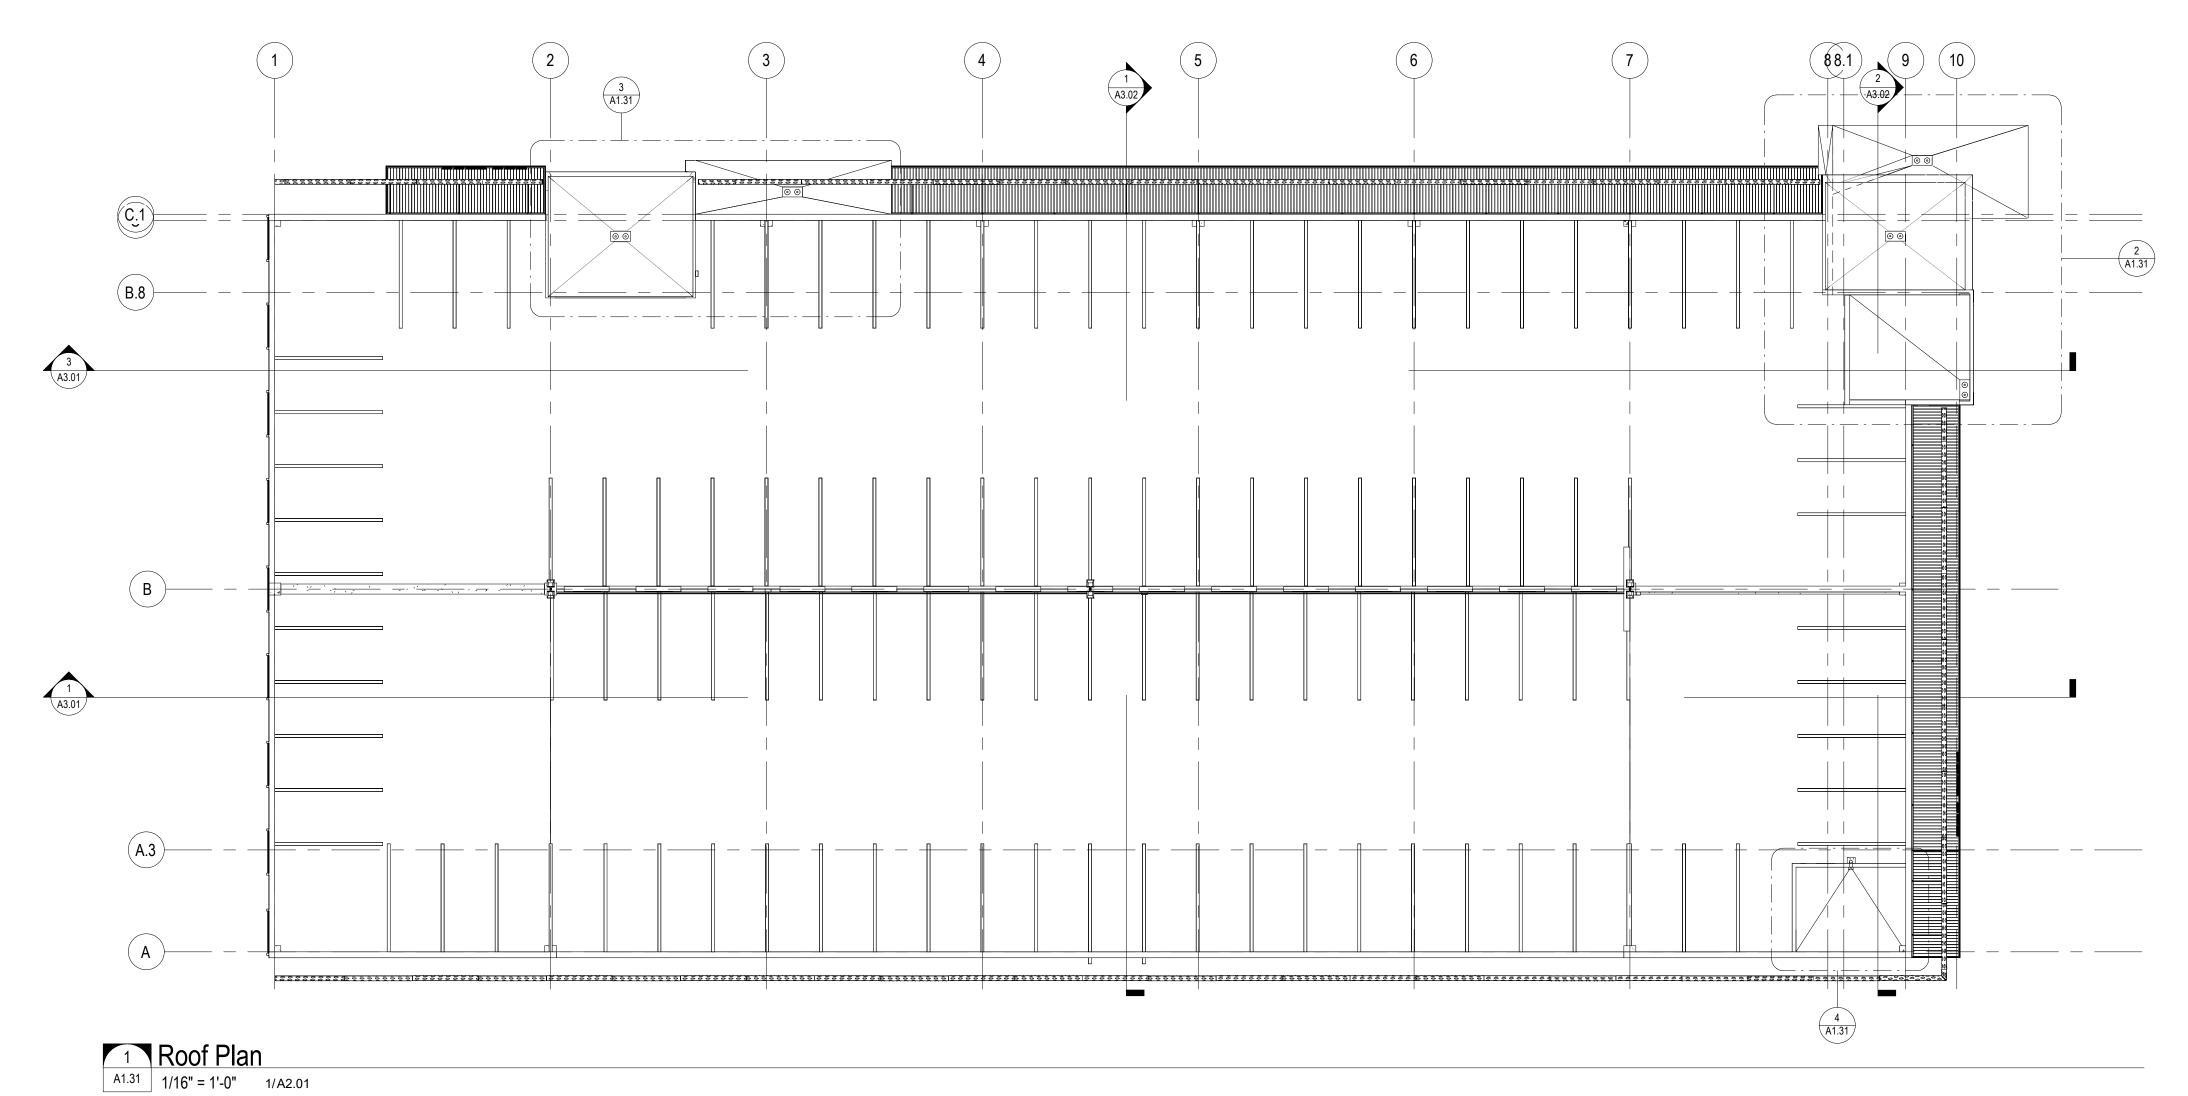

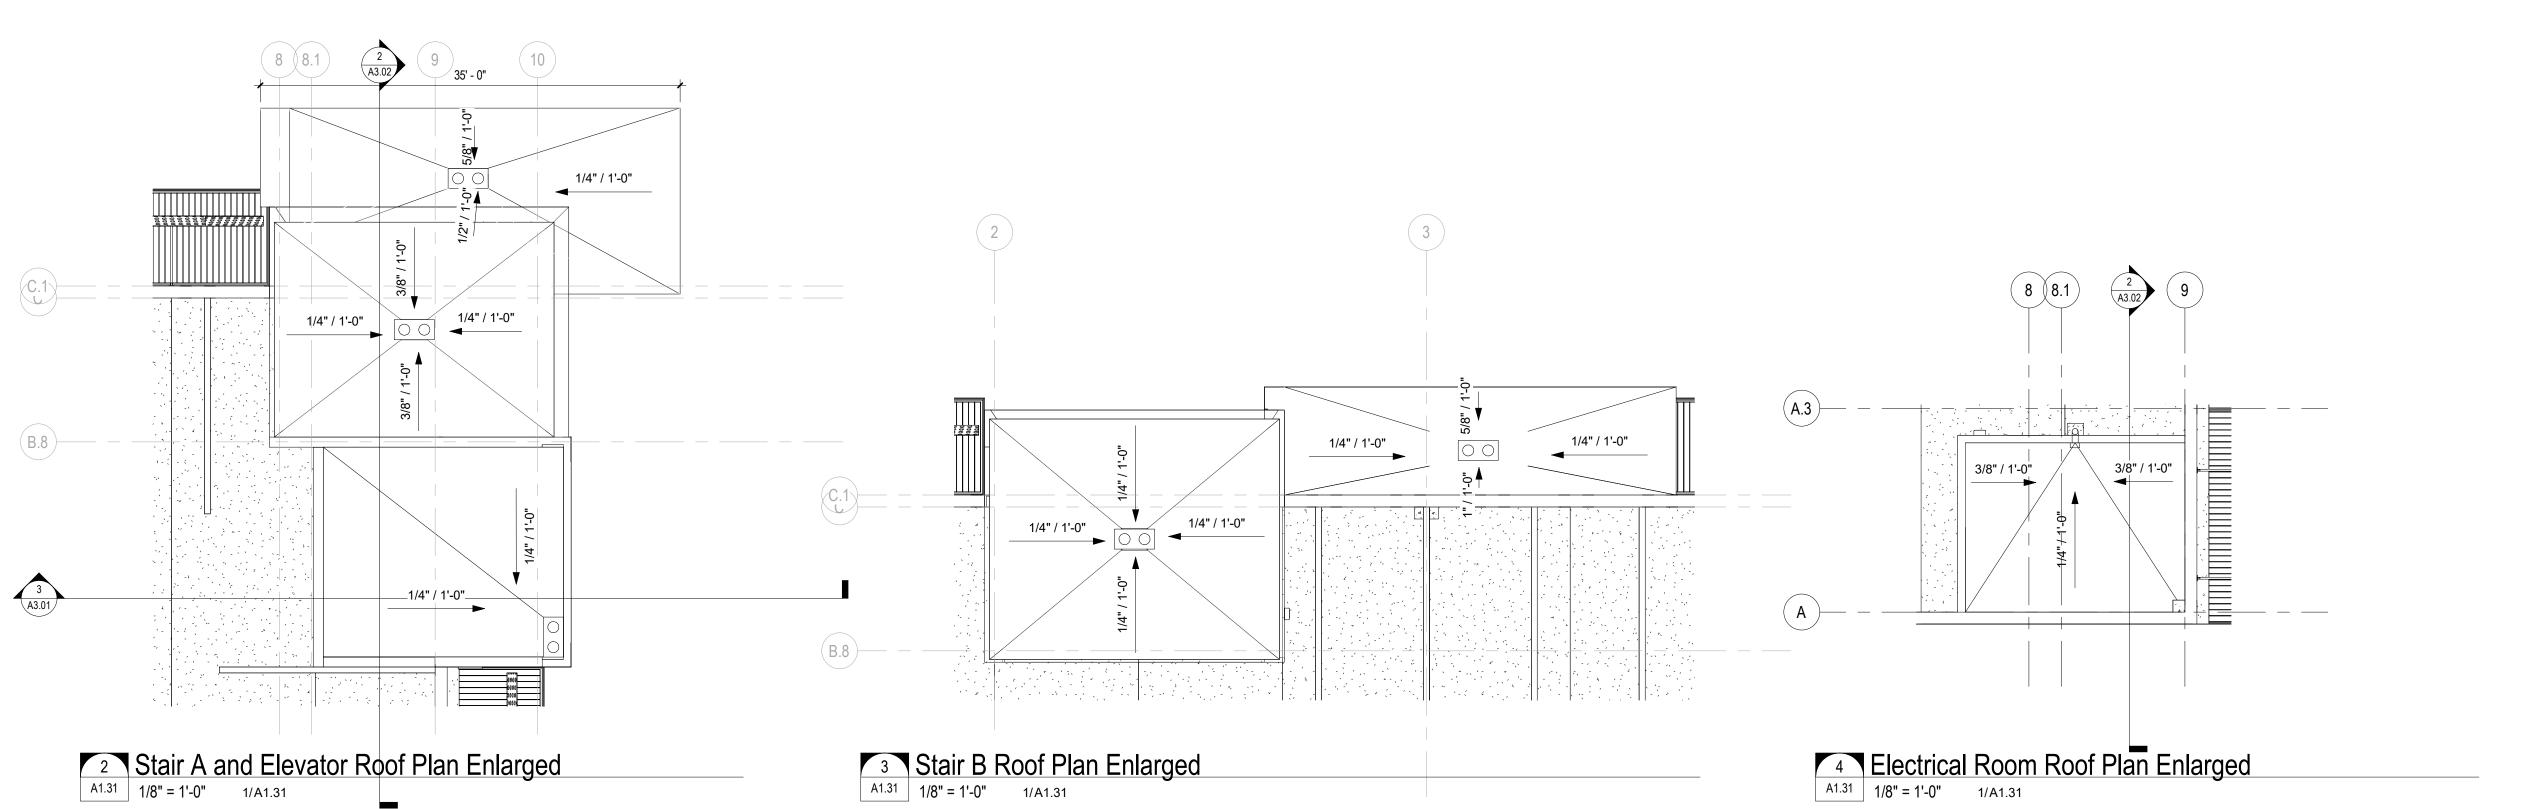




949 Central Ave.
Naples, Florida 34102
Phone: 239-643-3103 Fax: 239-643-7435

1st Avenue S. Public Parking Garage

Owner:
City of Naples

Consultant

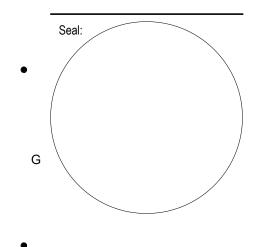

Project Phase: Design Development

Project #: 2204.01
Project Issued: June/2022
Sheet Issued: 01-05-2023


Е	No	Date	Revision
_			
•			
D			
С			
•			


Copyright © 2022. BSSW Architects, Inc. reserves copyright and other rights restricting these documents to the original site or purpose for which they were prepared. Reproductions, changes or assignments are


Sheet Title:
Roof Plan

Autodesk Docs://2204.01 - Naples Playhouse Parking Garage/2204.01 - 1st Avenue S. Public Parking Garage_R-22.rvt 1/12/2023 5:46:01 PM


A Sheet No.

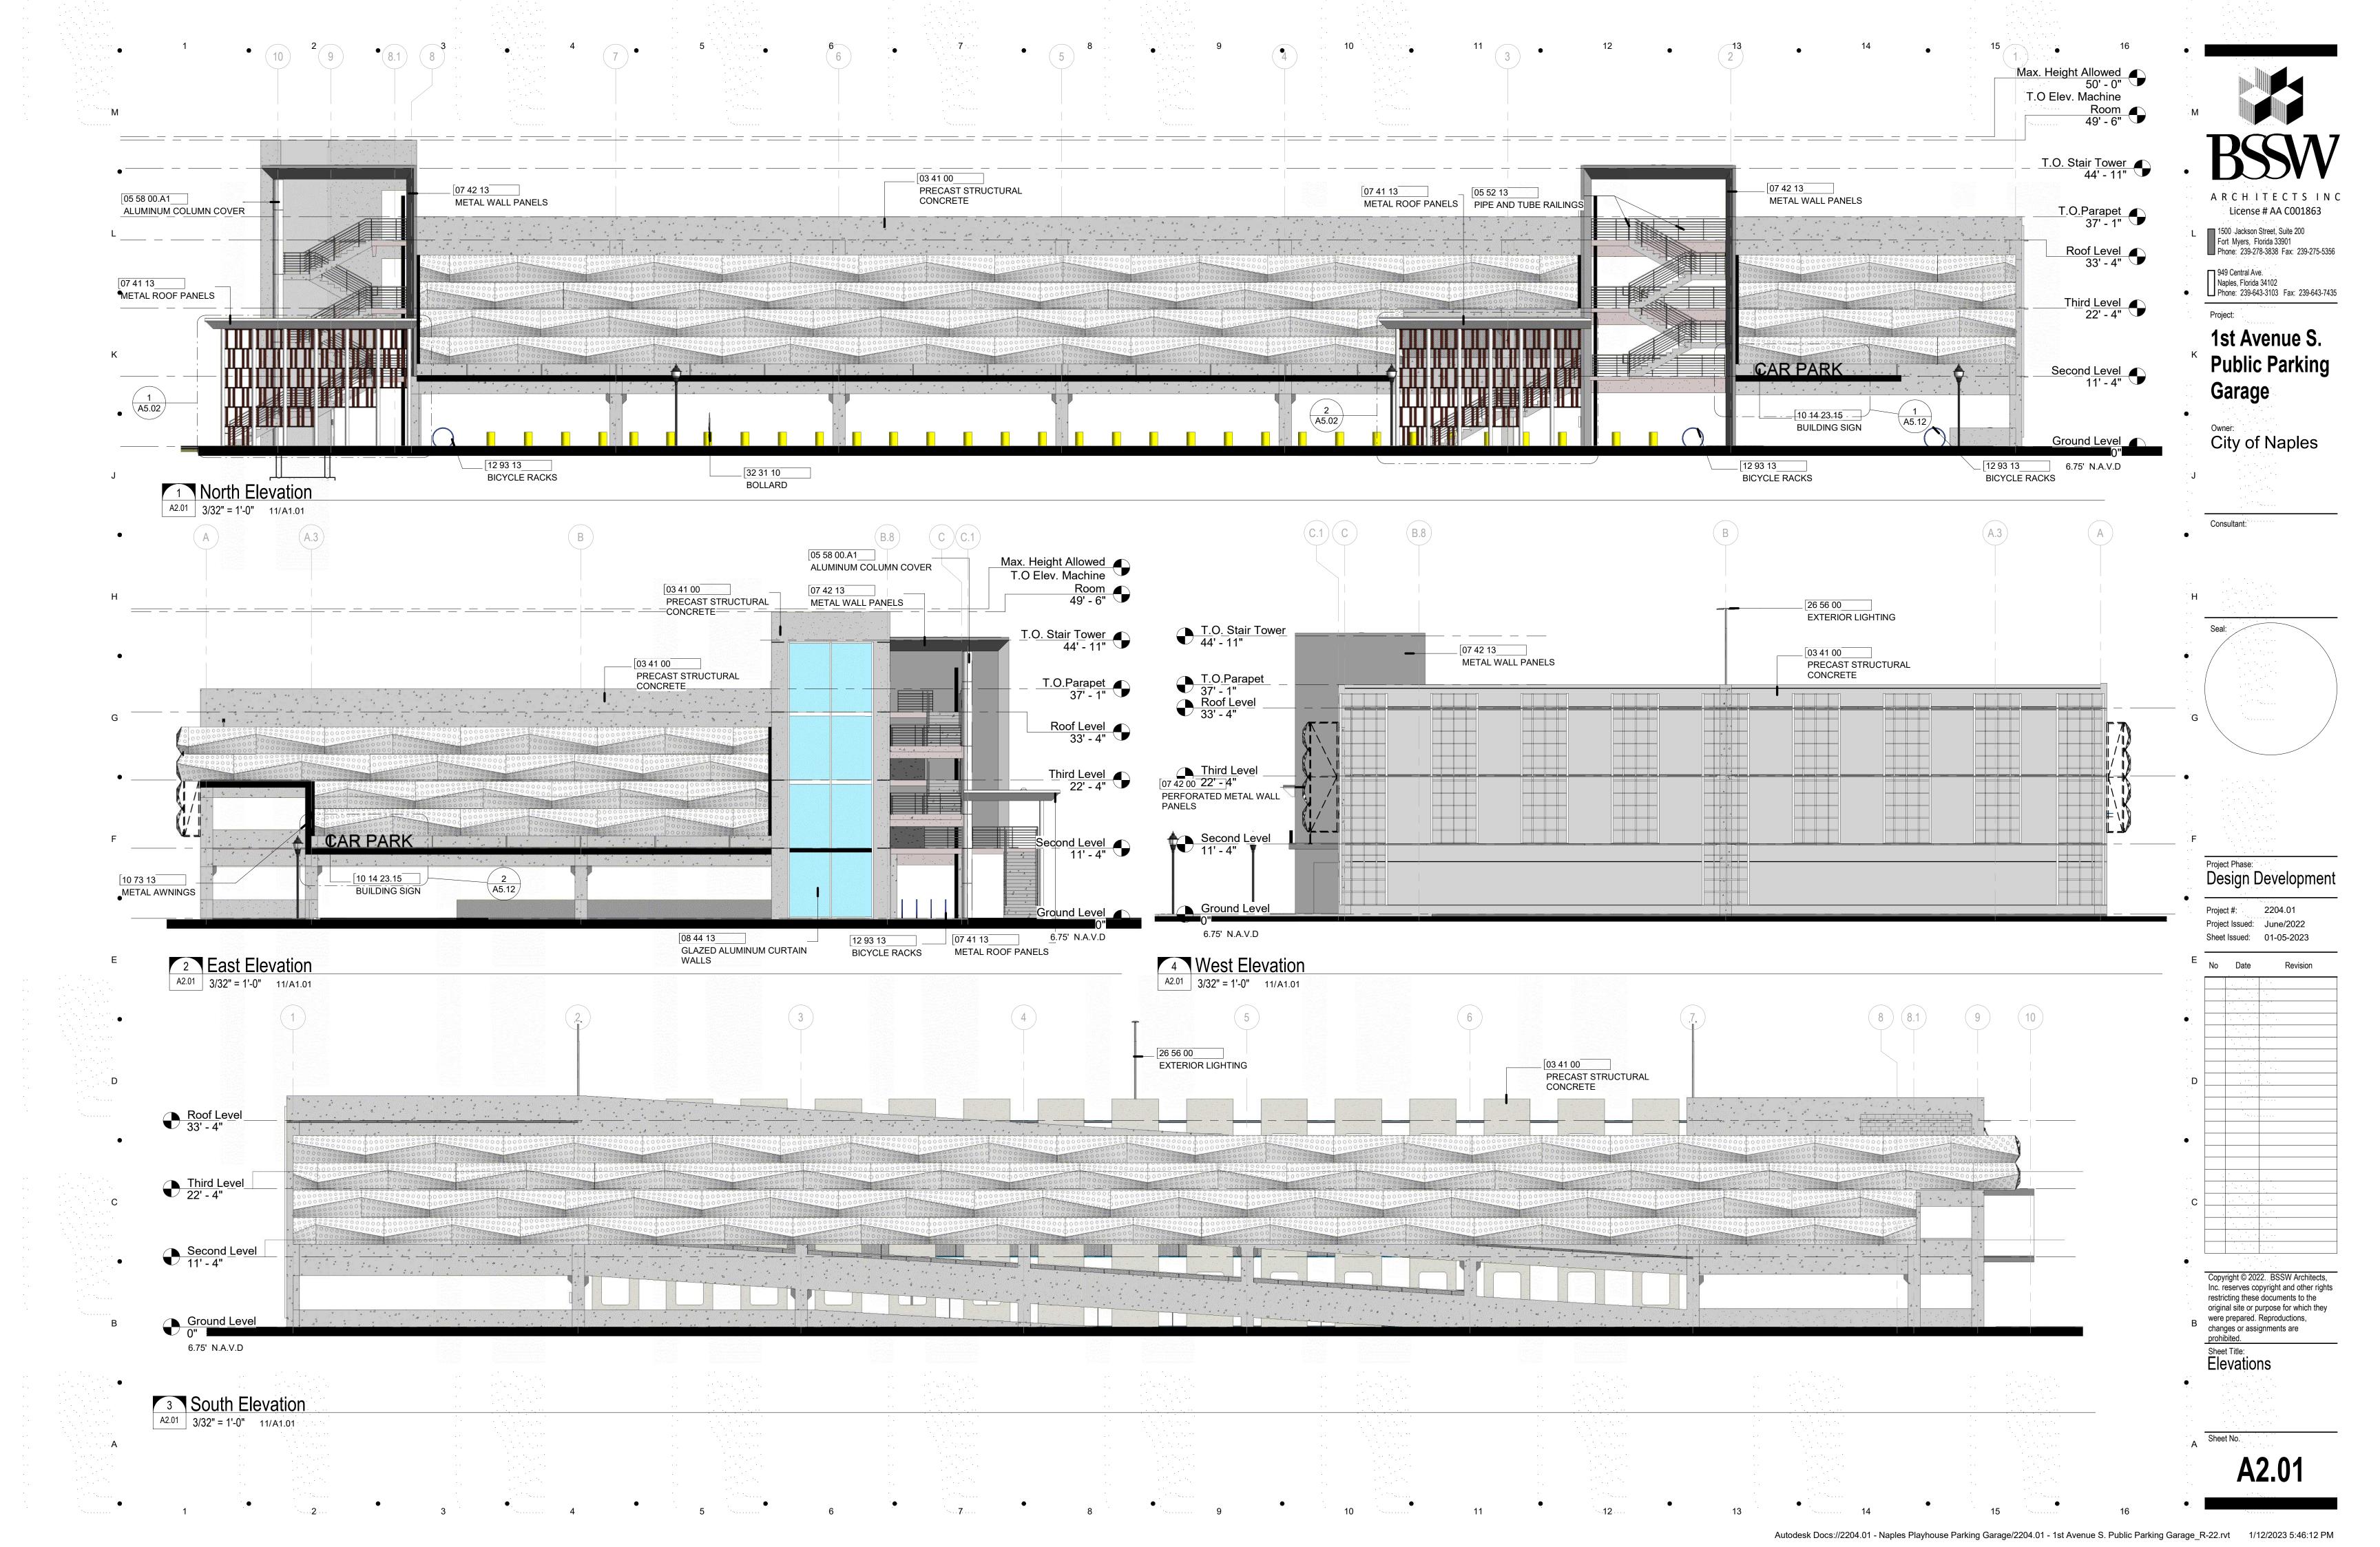

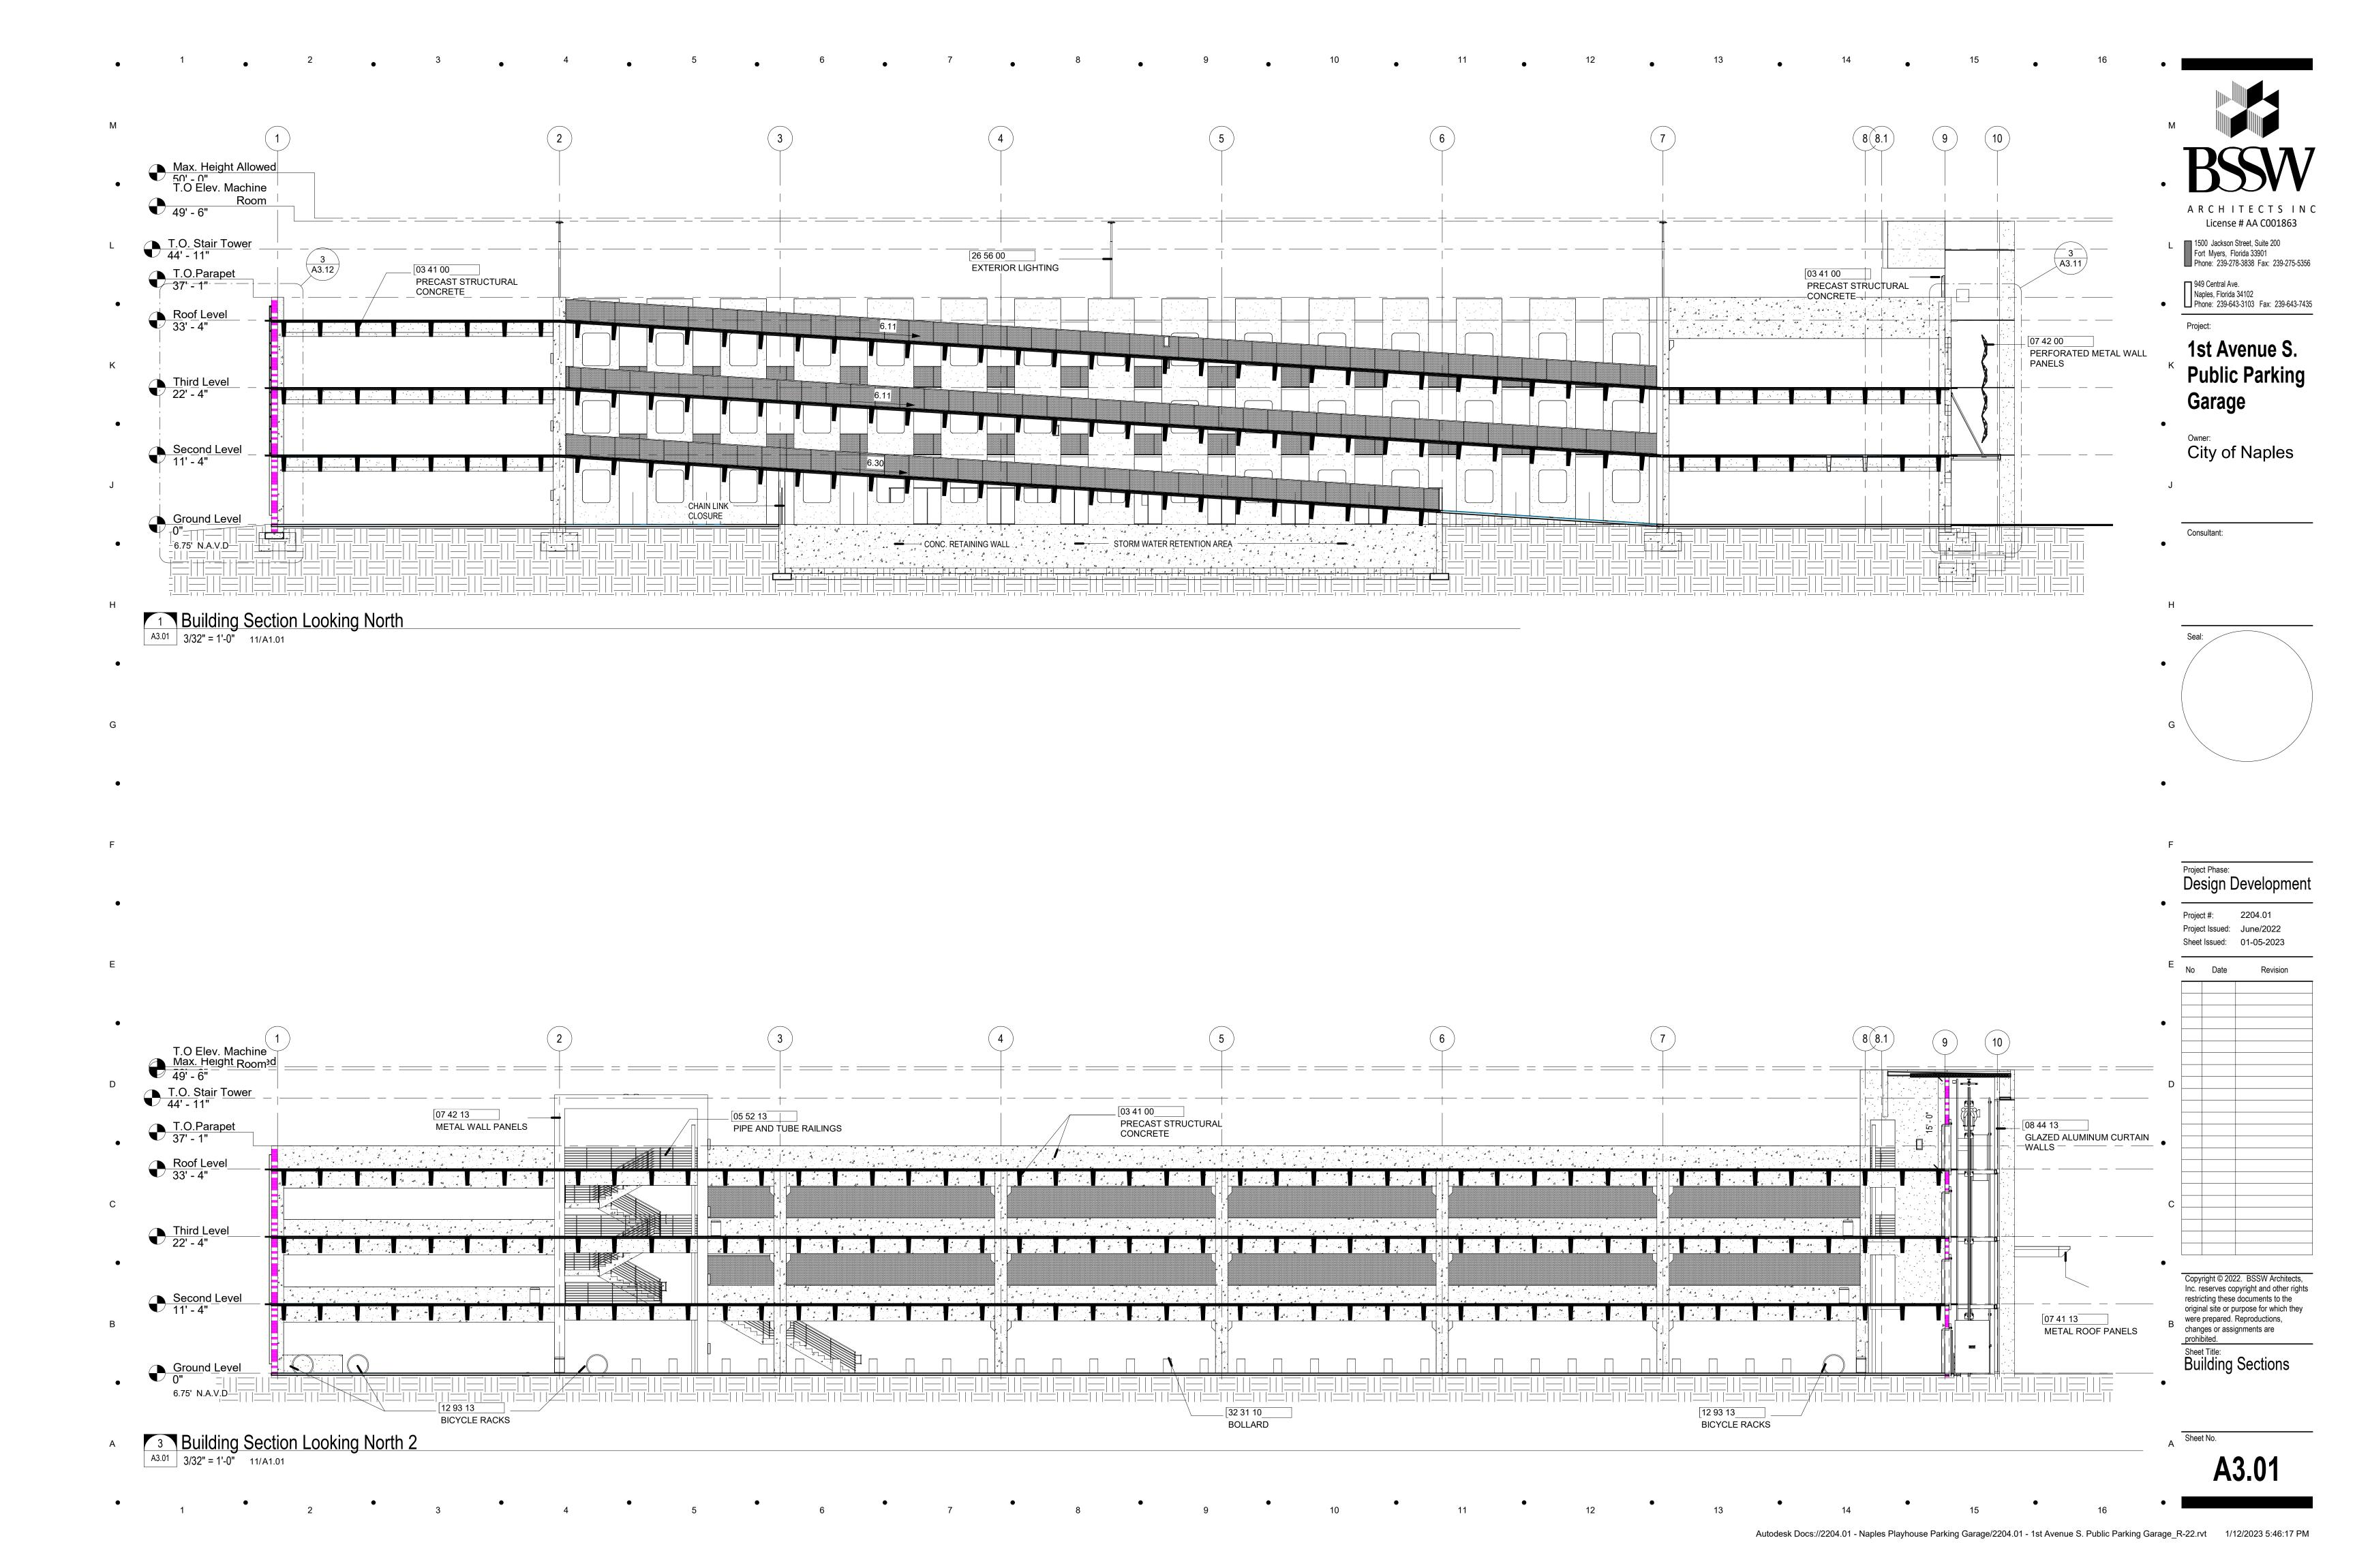


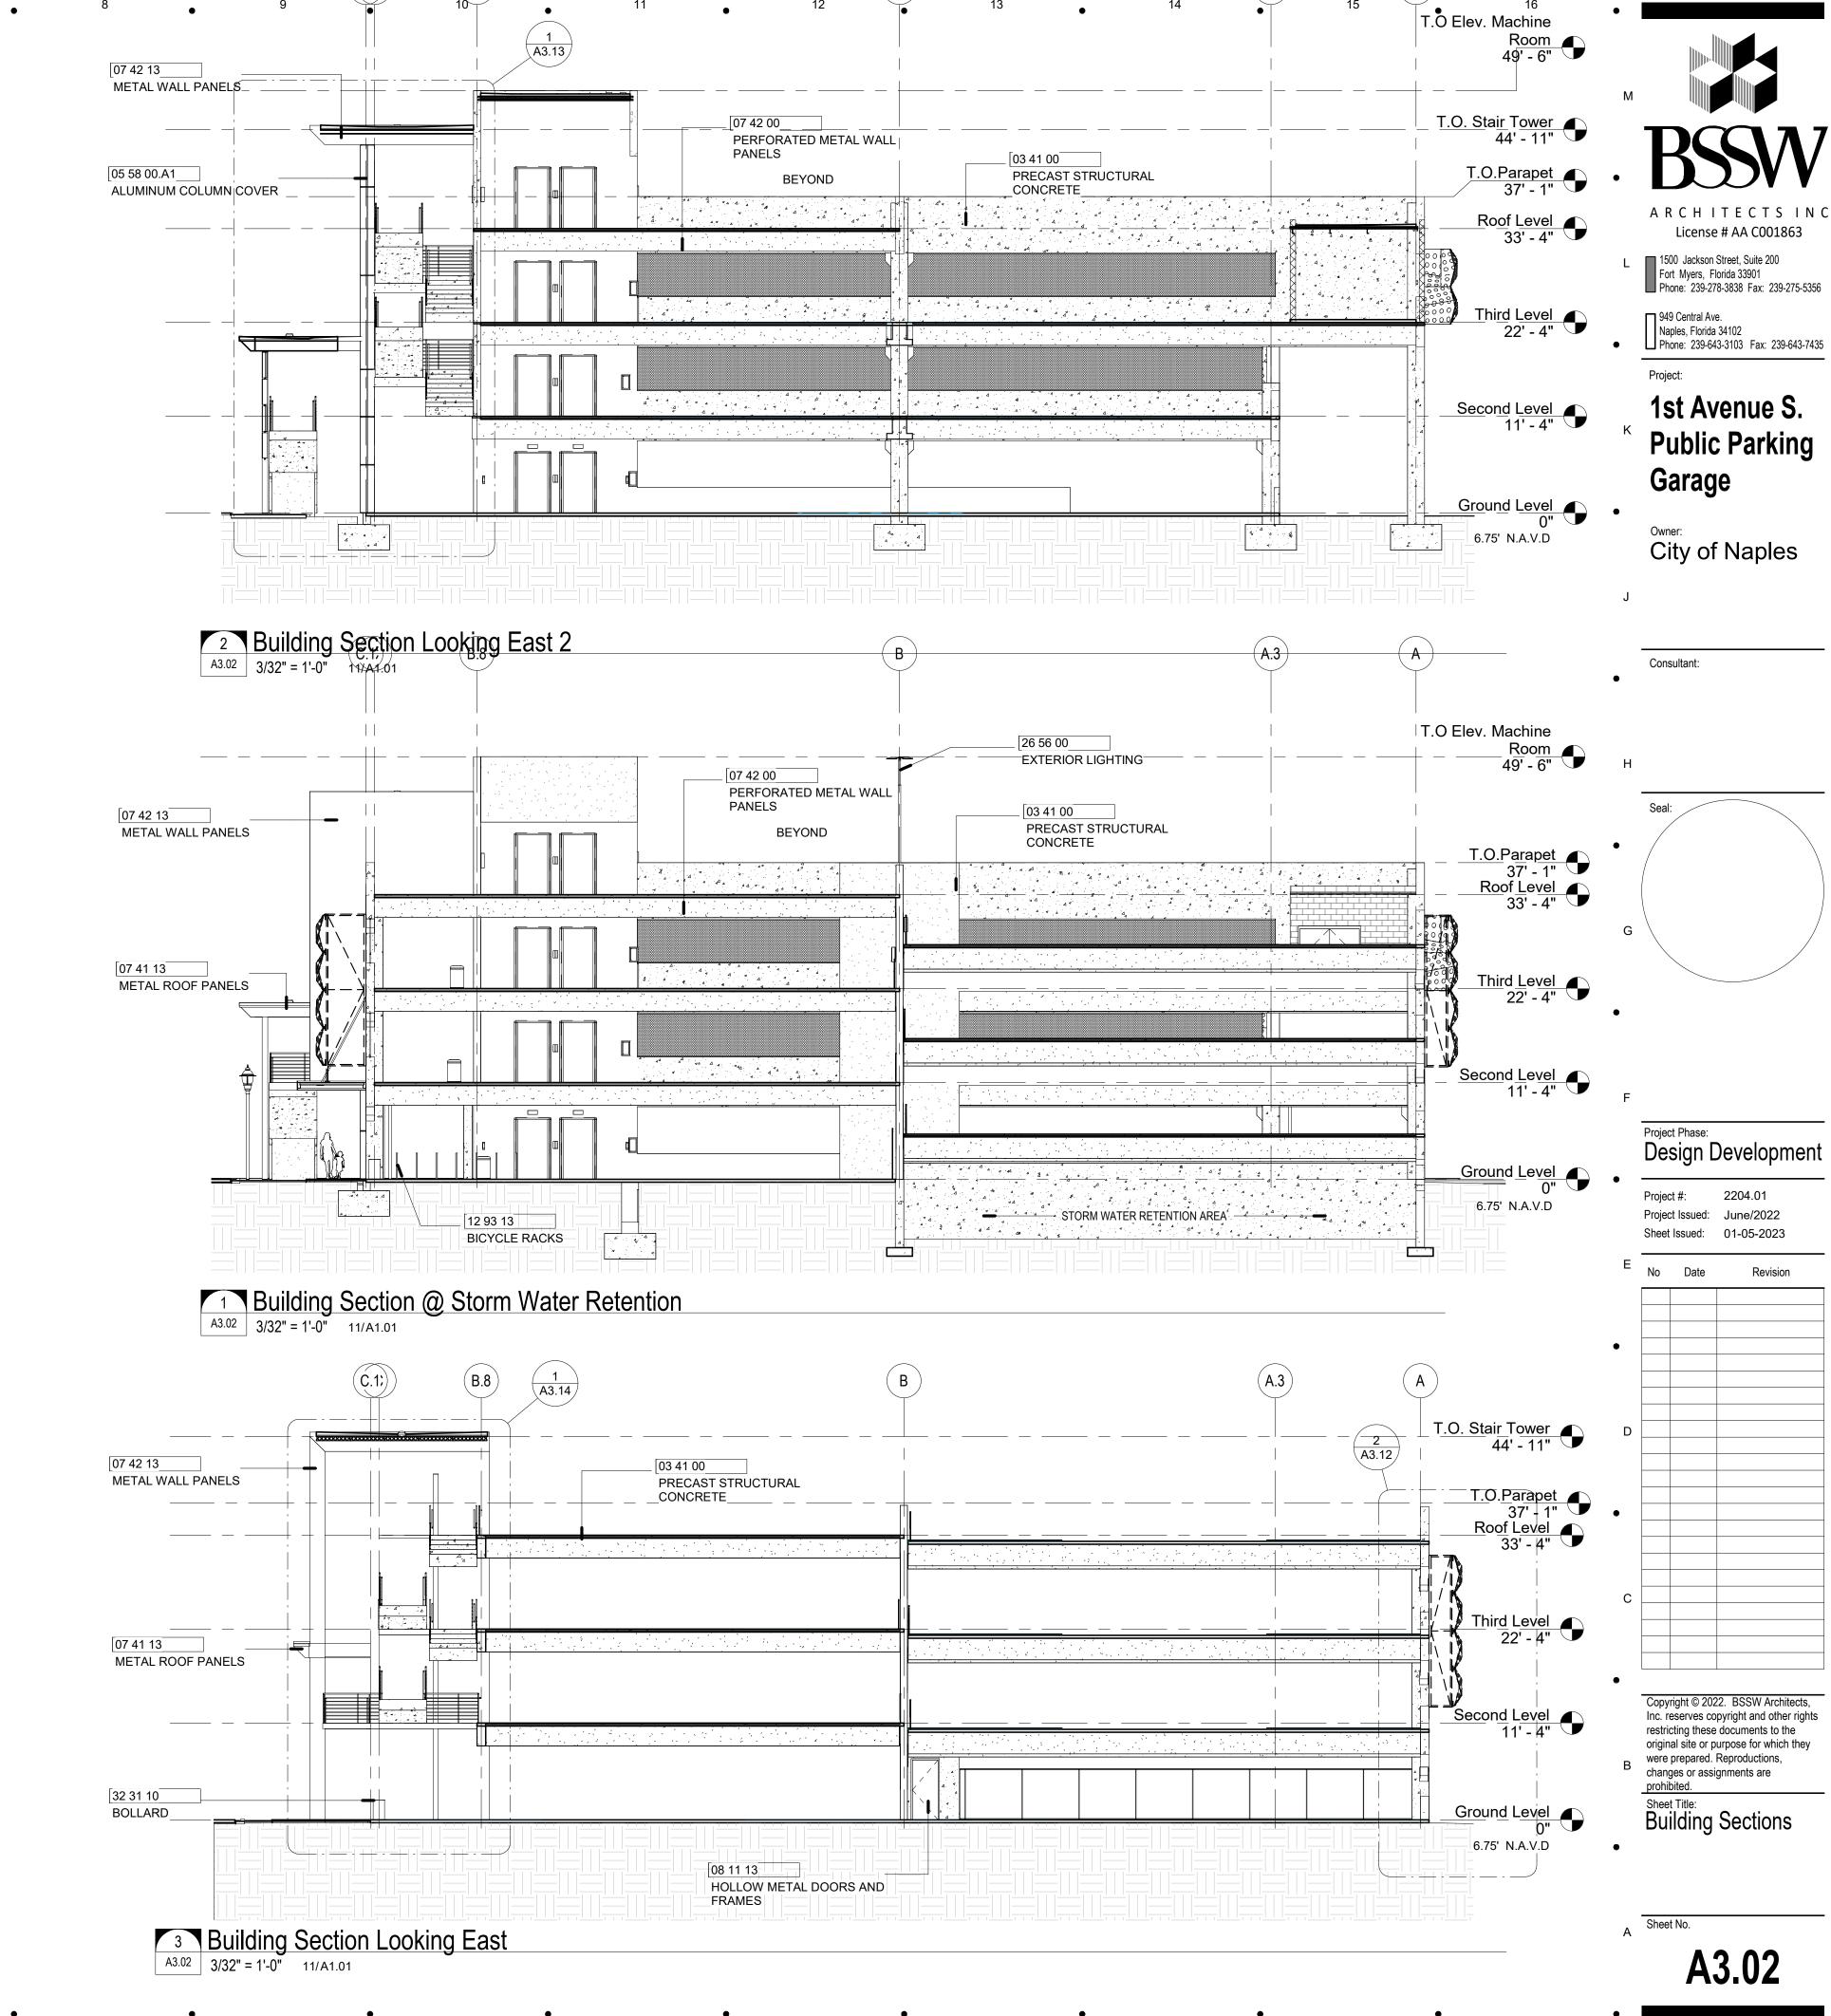


Autodesk Docs://2204.01 - Naples Playhouse Parking Garage/2204.01 - 1st Avenue S. Public Parking Garage_R-22.rvt 1/12/2023 5:46:22 PM

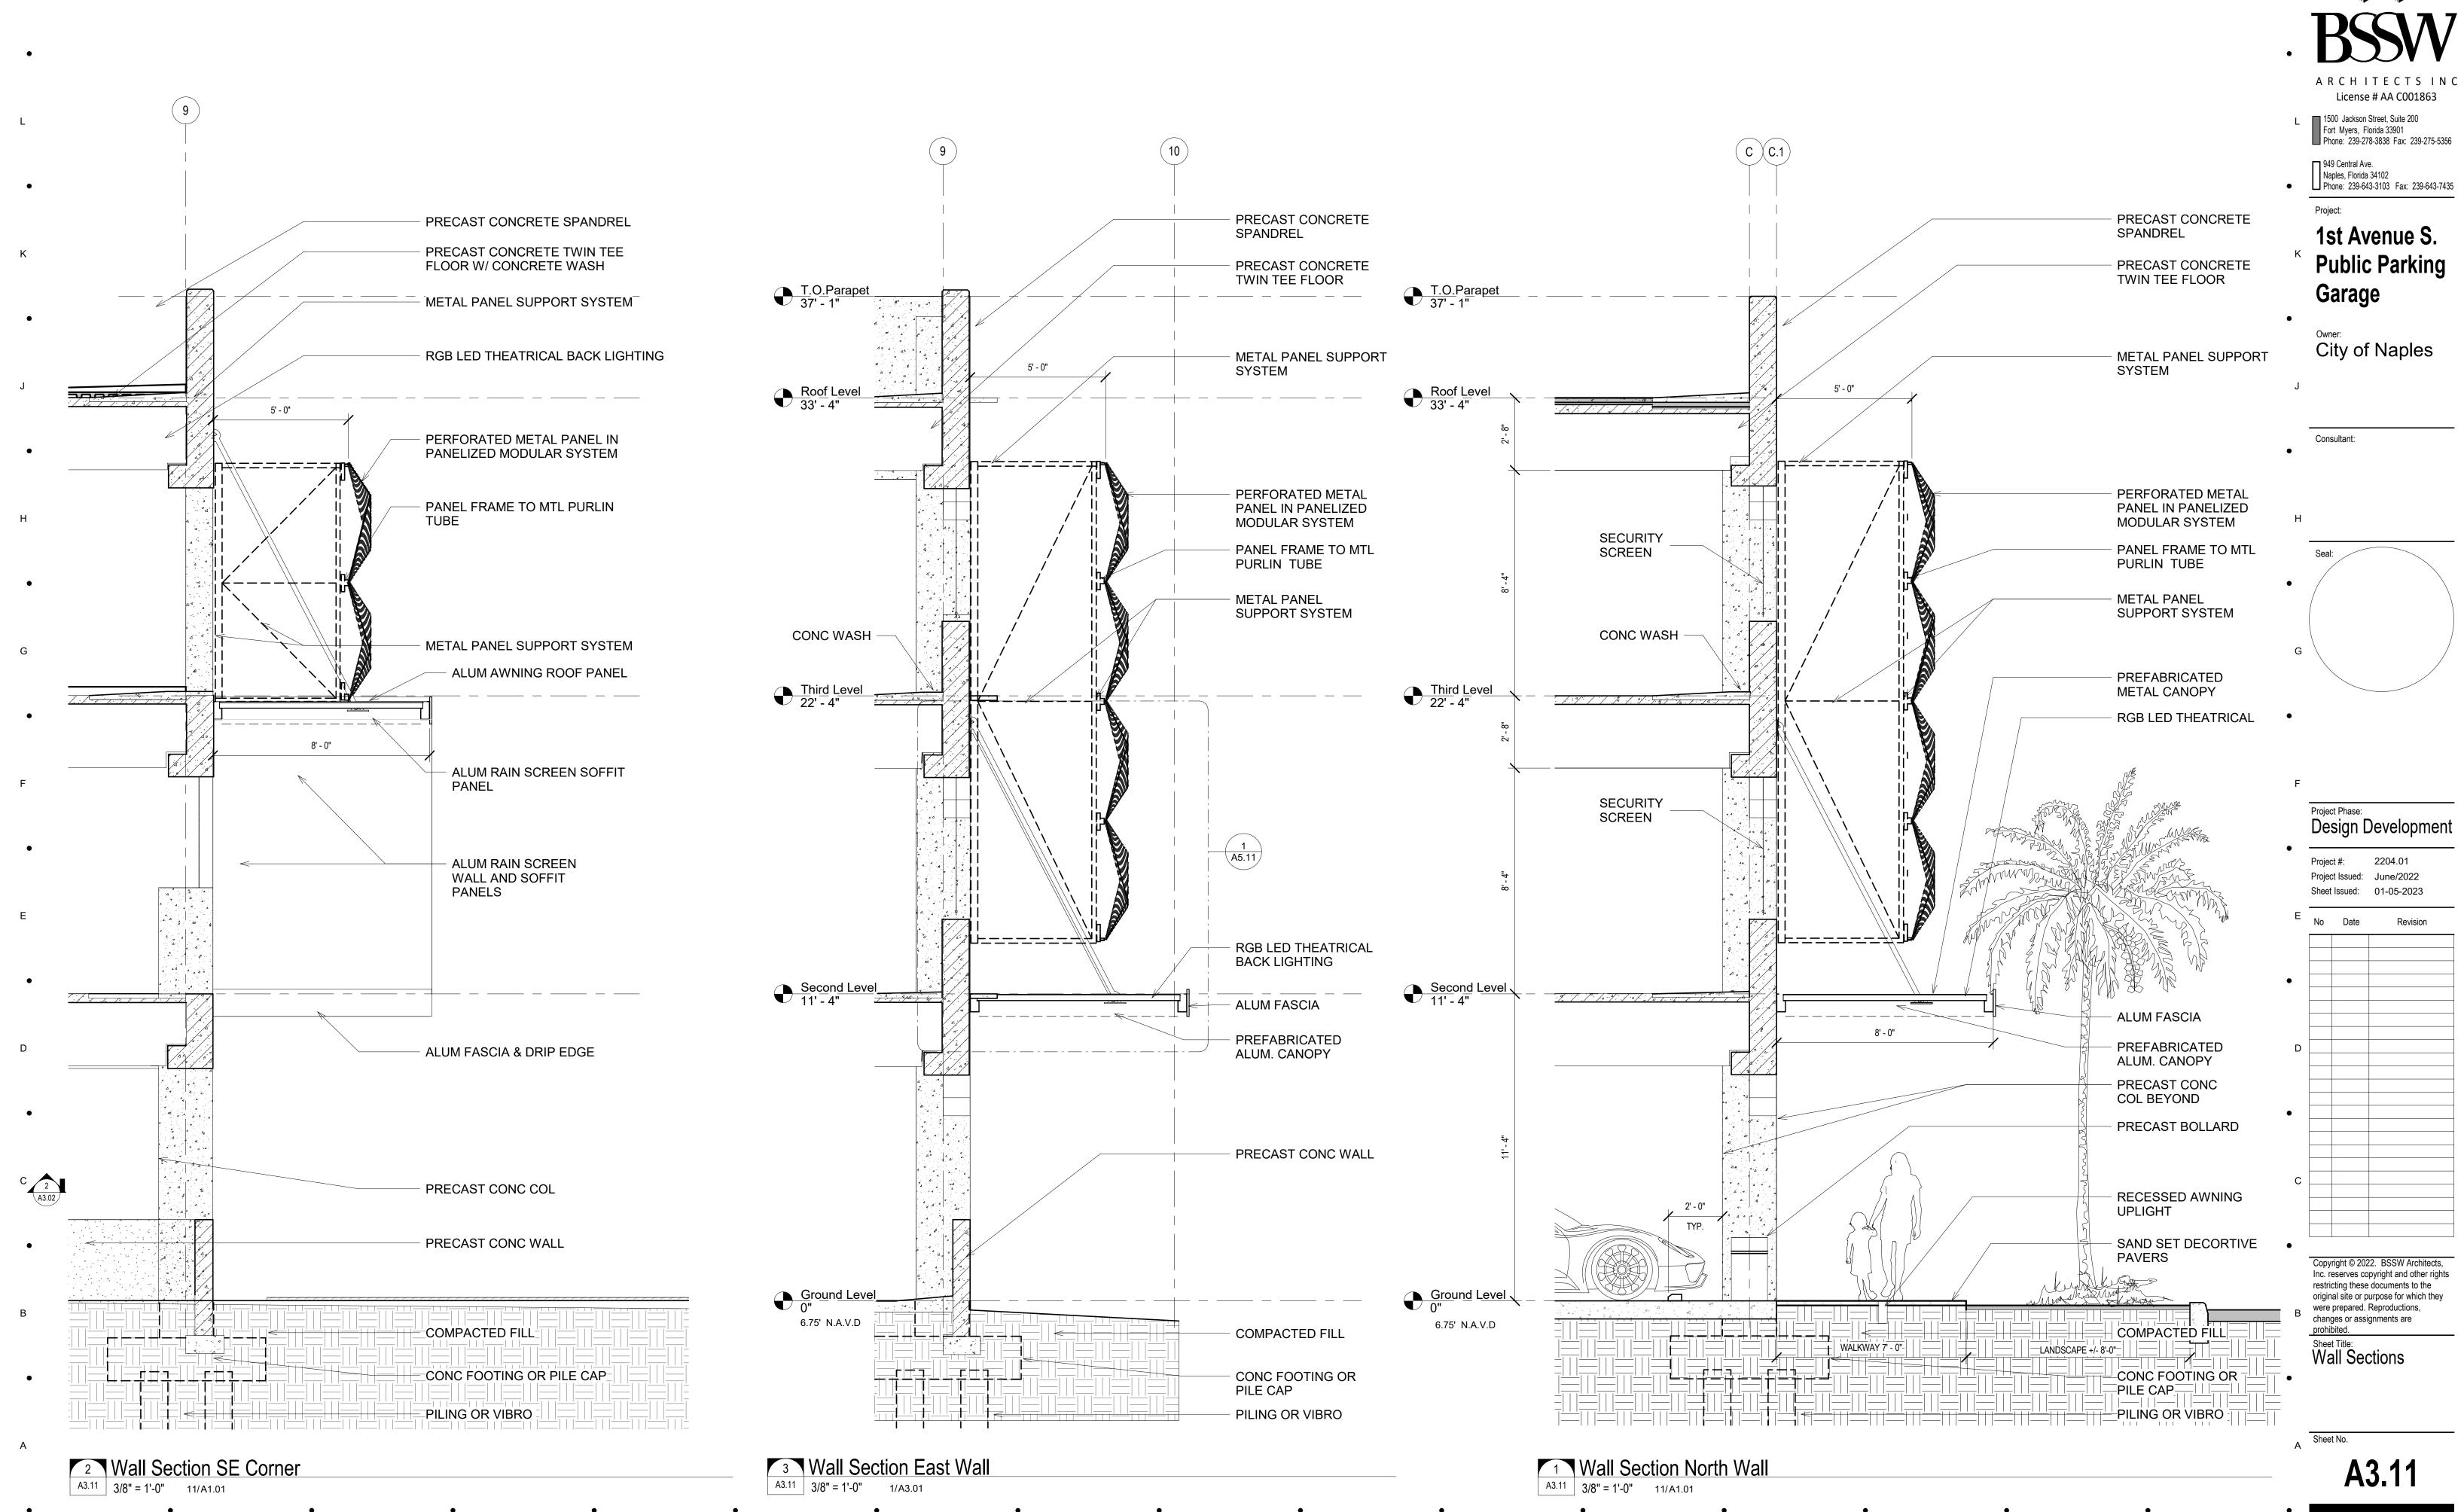

Autodesk Docs://2204.01 - Naples Playhouse Parking Garage/2204.01 - 1st Avenue S. Public Parking Garage_R-22.rvt 1/12/2023 5:46:30 PM

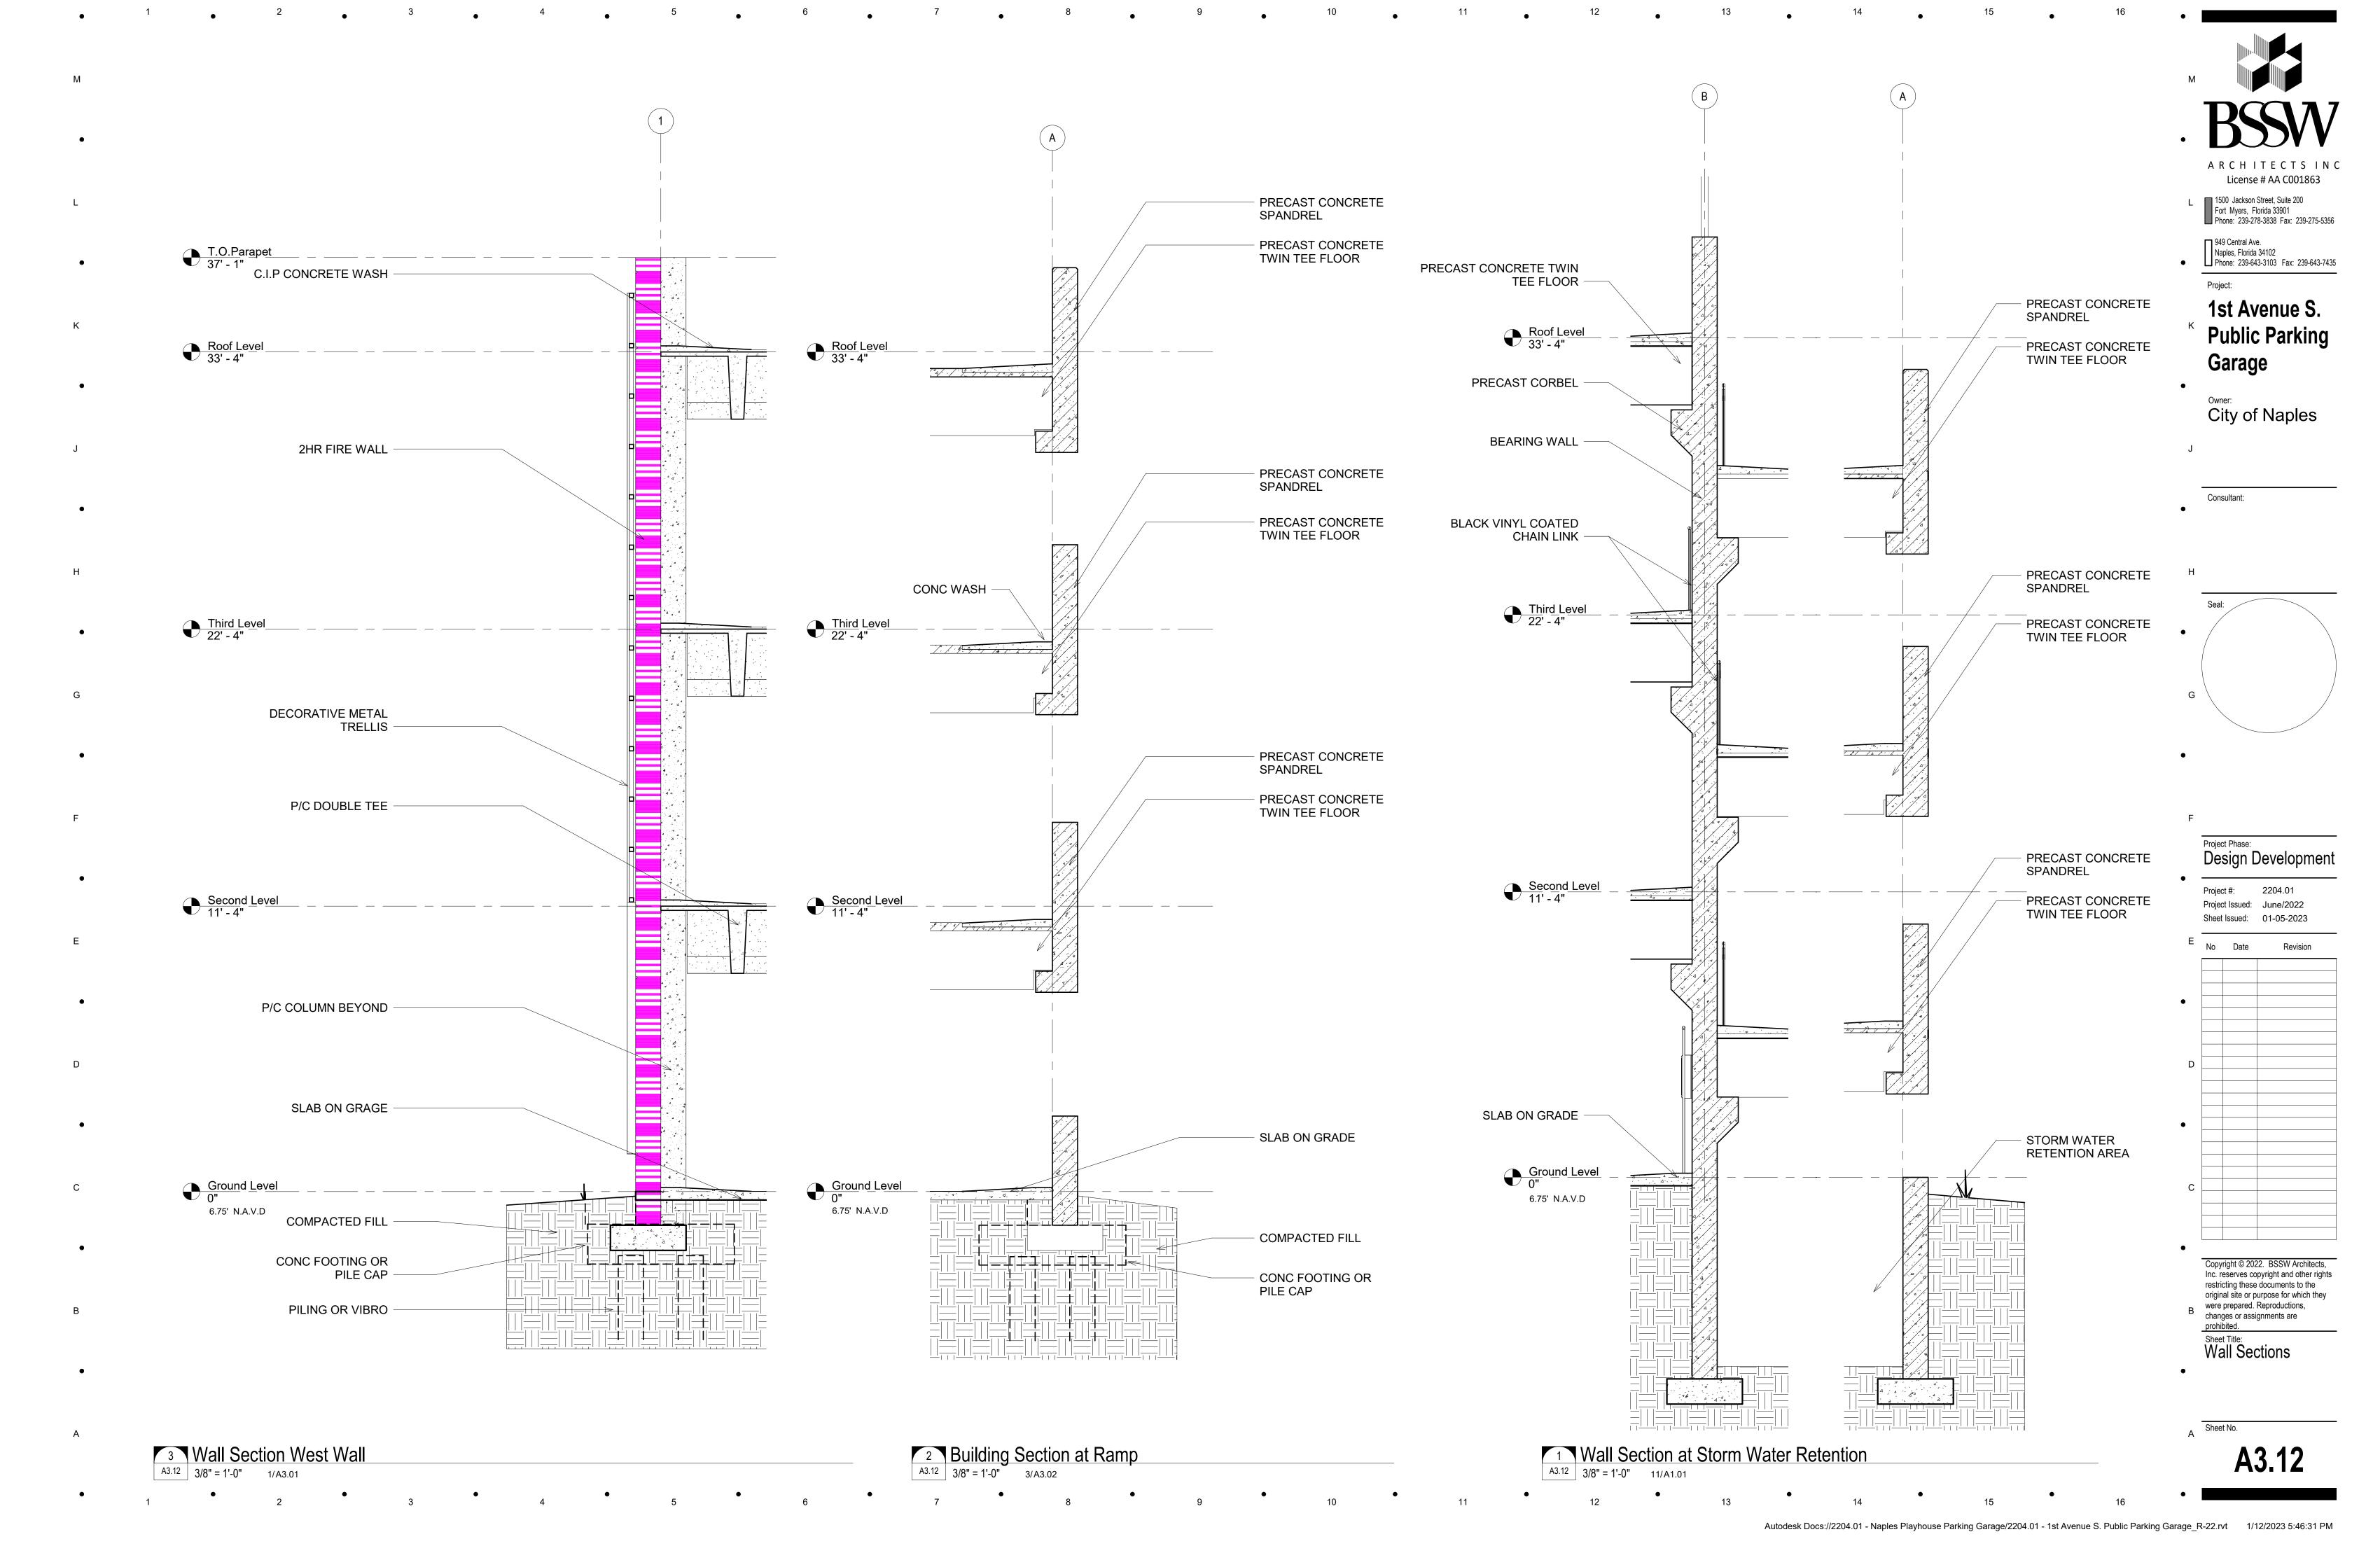

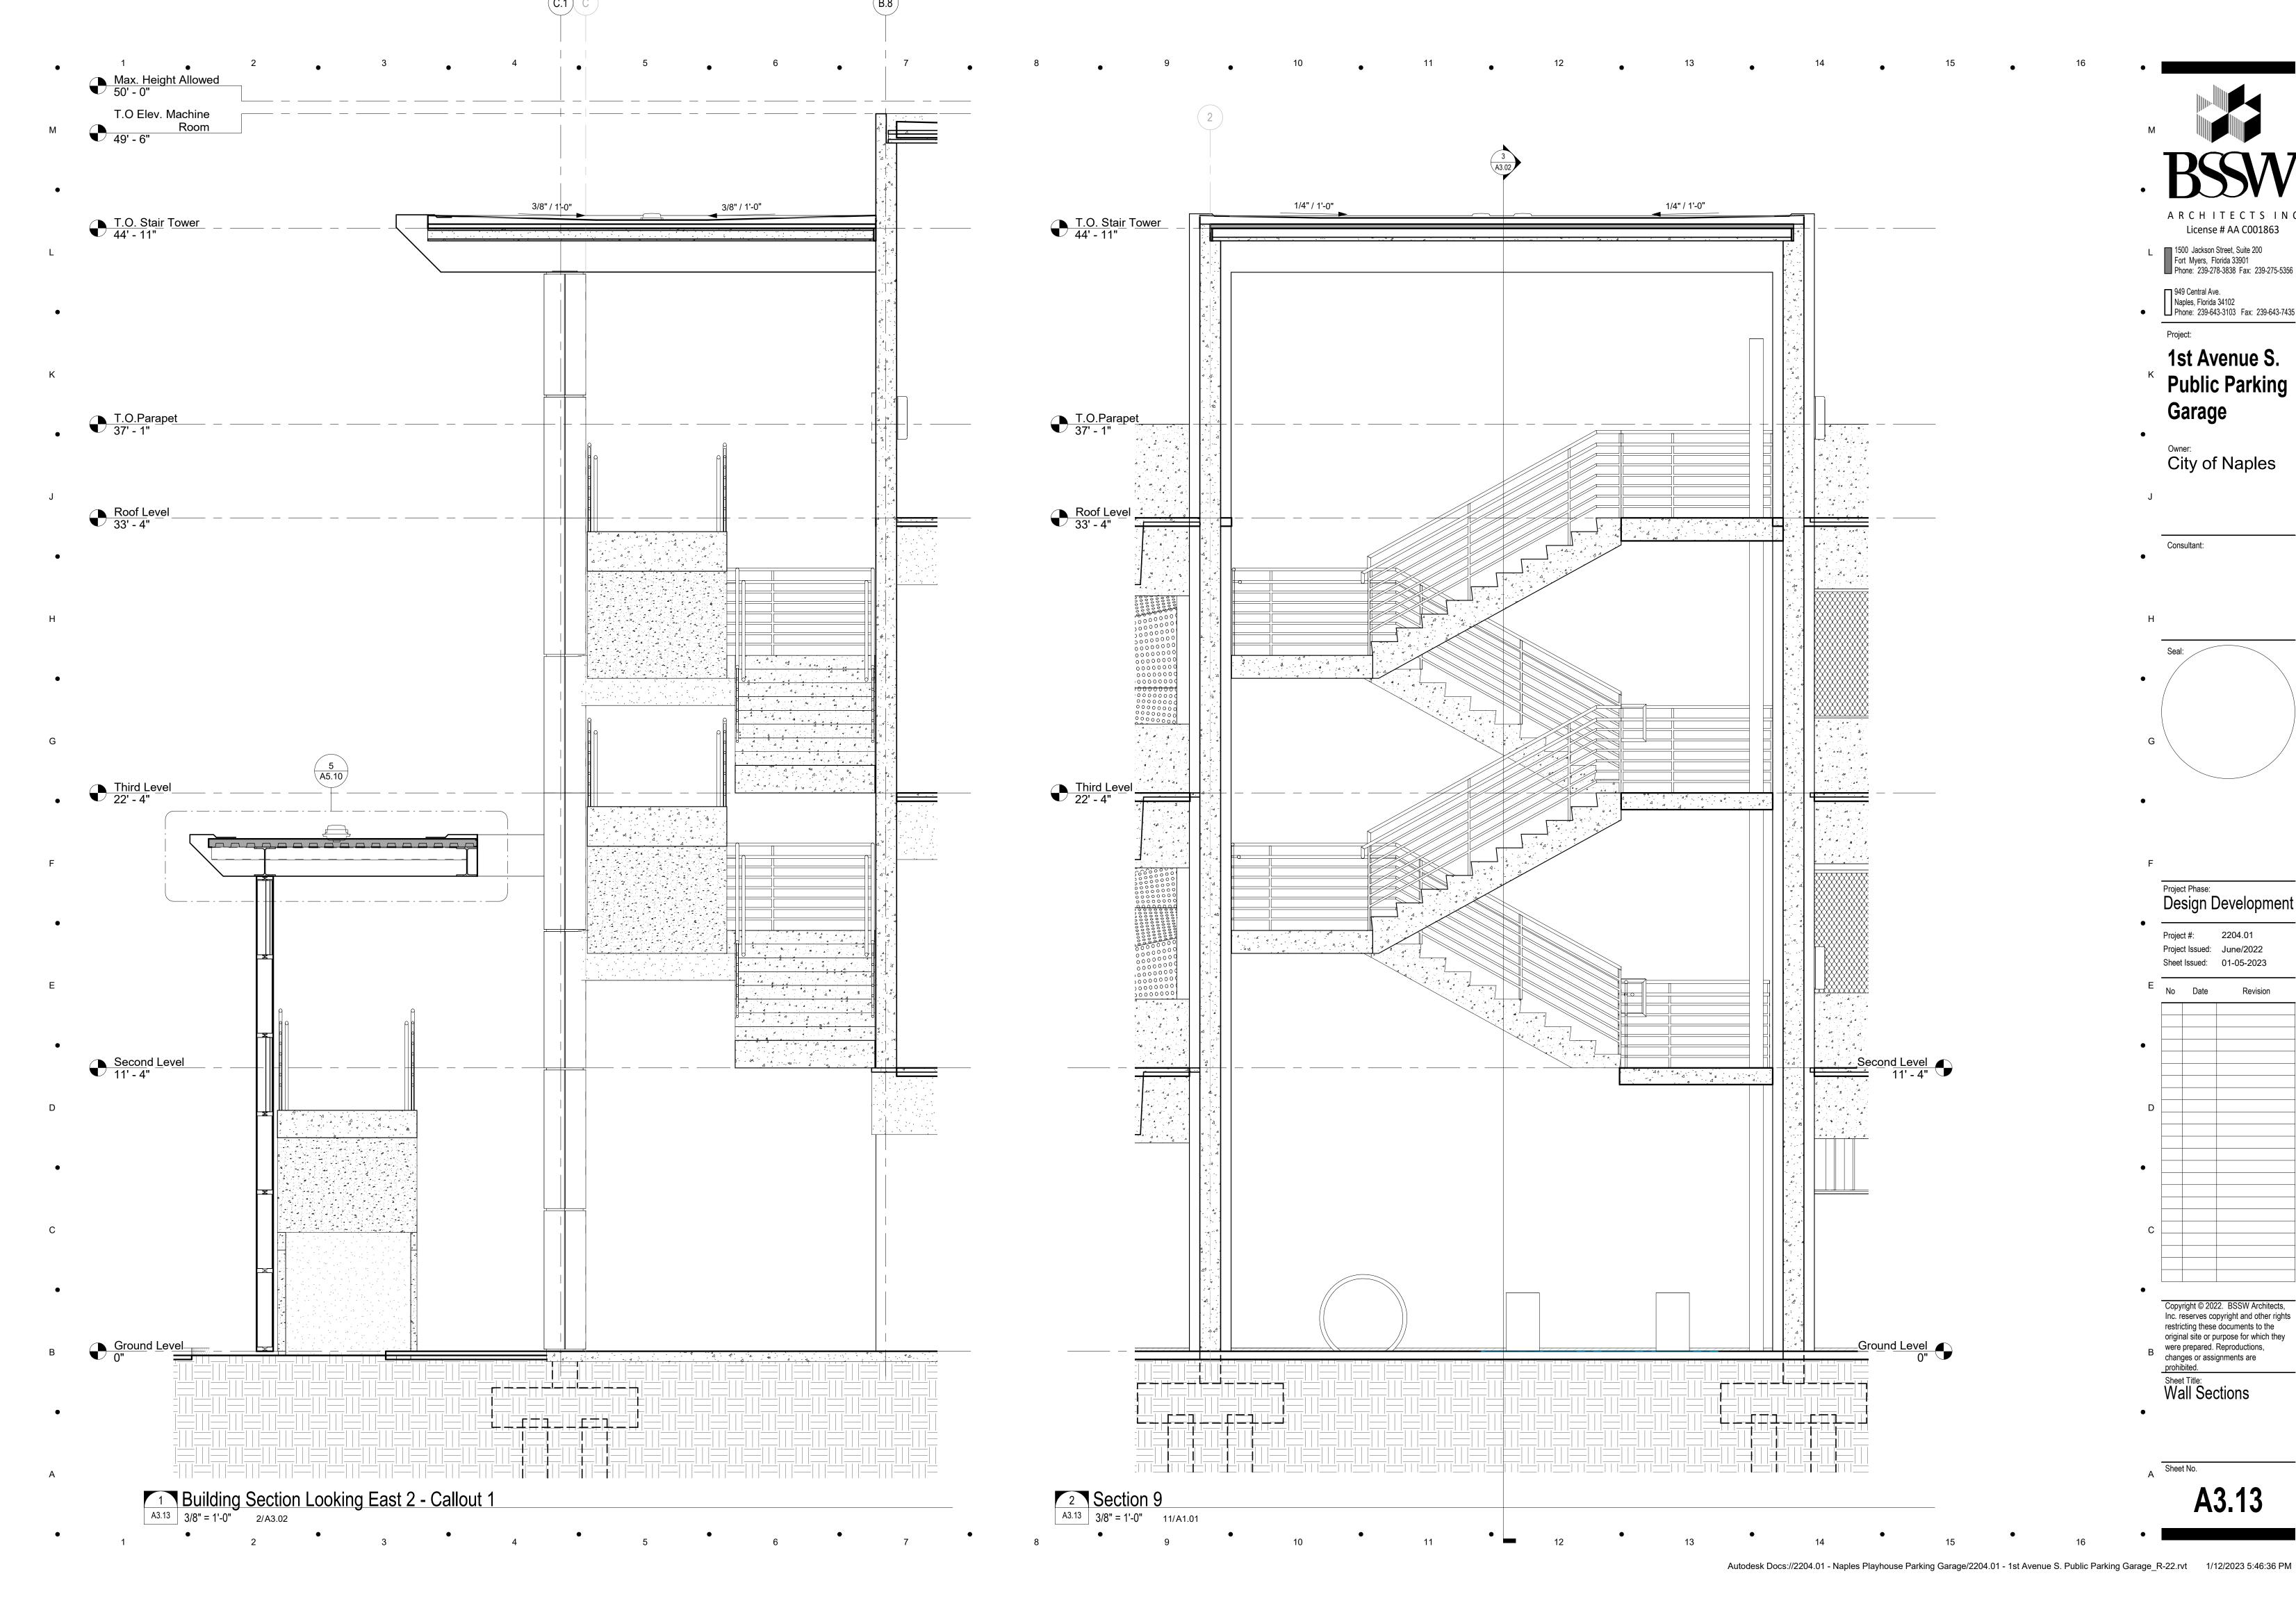




ARCHITECTS INC License # AA C001863

1500 Jackson Street, Suite 200 Fort Myers, Florida 33901 Phone: 239-278-3838 Fax: 239-275-5356

949 Central Ave.
Naples, Florida 34102
Phone: 239-643-3103 Fax: 239-643-7435

1st Avenue S. **Public Parking** Garage

Owner:
City of Naples

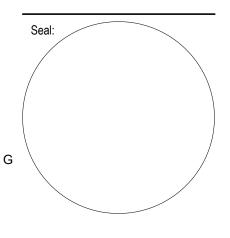

Project Phase:
Design Development


Project Issued: June/2022 Sheet Issued: 01-05-2023


Copyright © 2022. BSSW Architects, Inc. reserves copyright and other rights restricting these documents to the original site or purpose for which they were prepared. Reproductions, changes or assignments are prohibited.

Sheet Title:
Wall Sections

A Sheet No.

A3.13

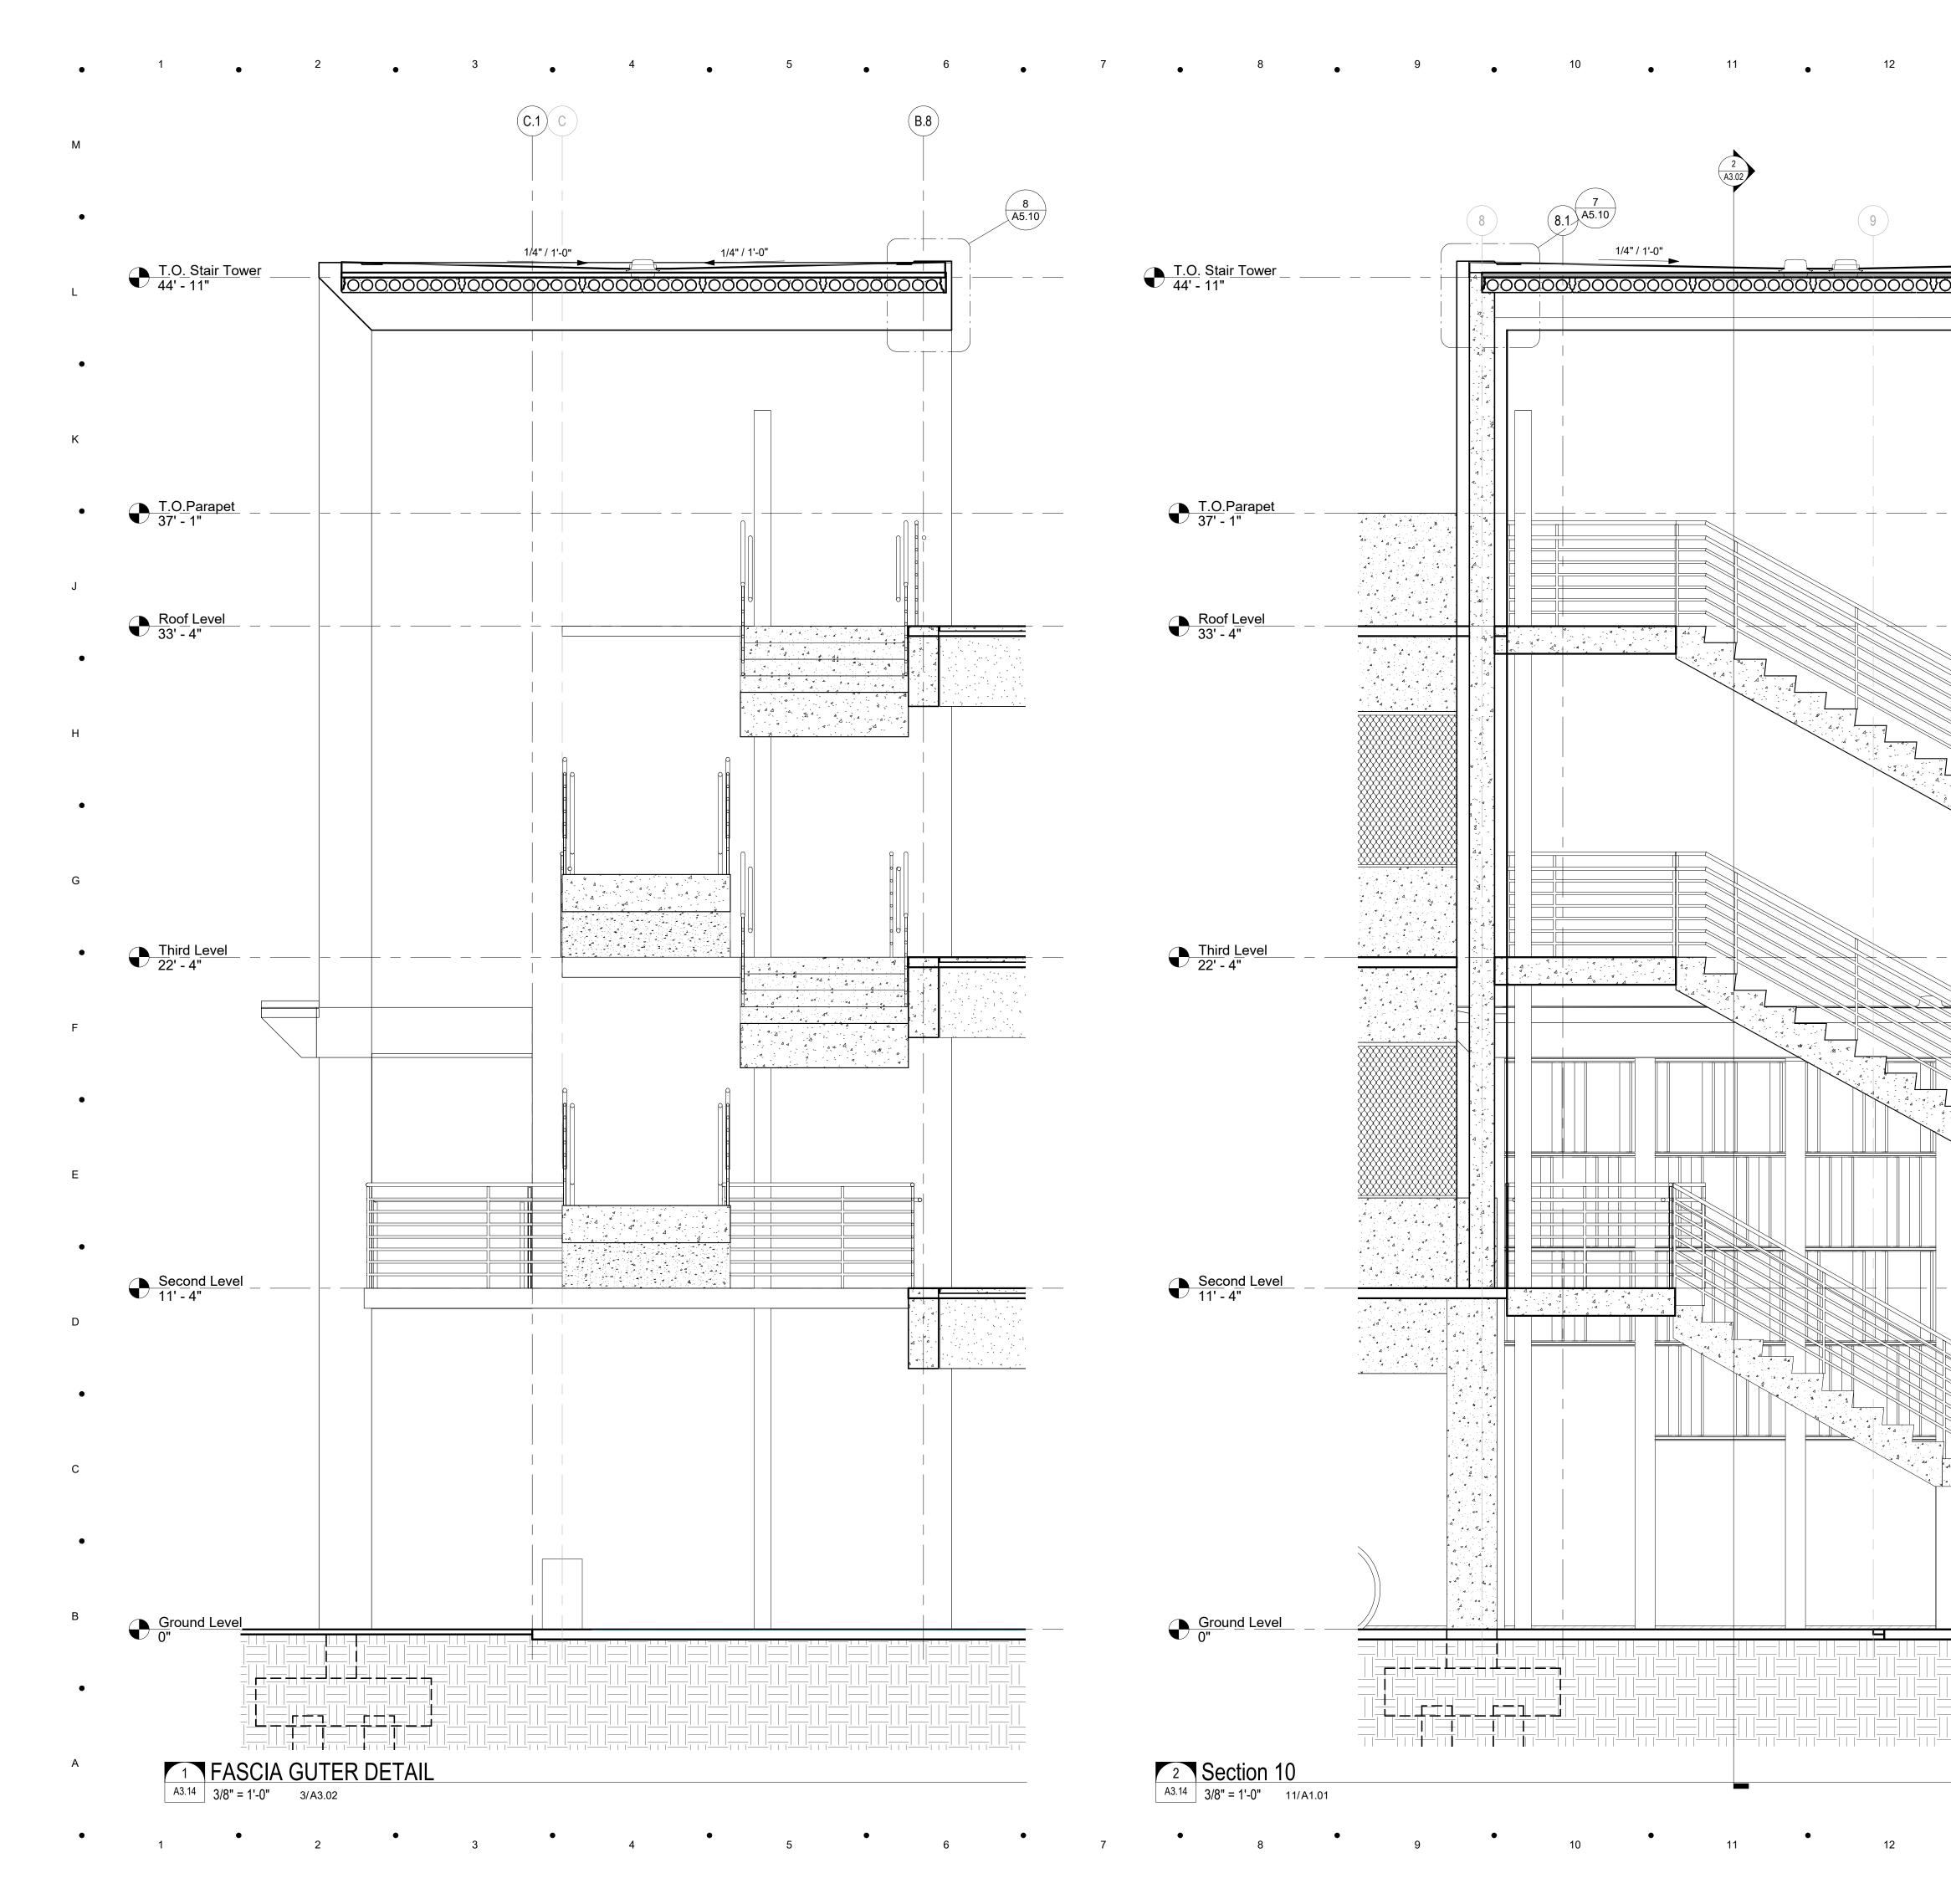

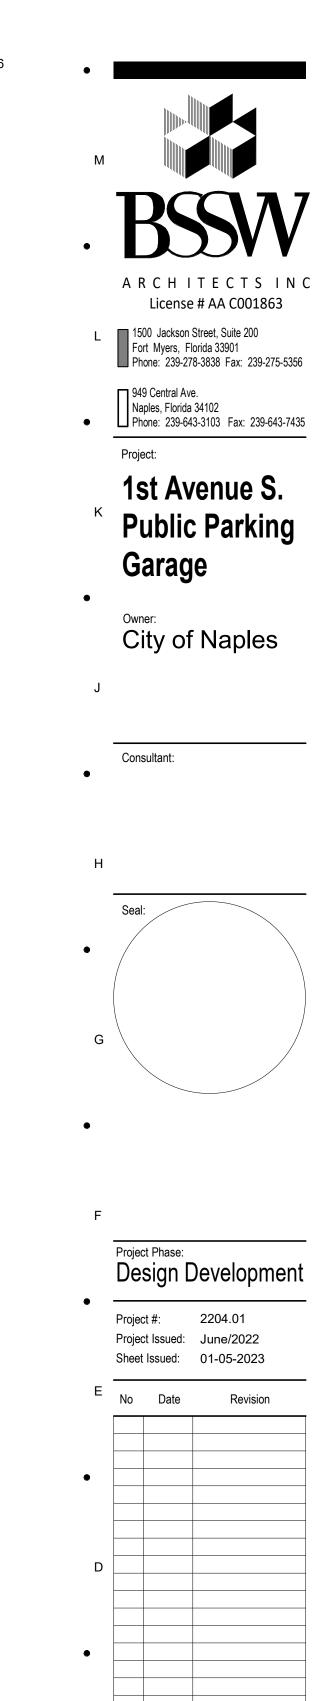

- 6" HOLLOW CORE SLABS W/ 2" C.I.P TOPPING. SEE STRUCTURAL.

- METAL CLADDING BY OTHERS

PRECAST BEAM SEE STRUCT.

- 1'-8" DIA. ALUMN. COLUMN COVER


Project Issued: June/2022

Copyright © 2022. BSSW Architects, Inc. reserves copyright and other rights restricting these documents to the original site or purpose for which they were prepared. Reproductions, changes or assignments are prohibited.

Sheet Title:
Wall Sections

Autodesk Docs://2204.01 - Naples Playhouse Parking Garage/2204.01 - 1st Avenue S. Public Parking Garage_R-22.rvt 1/12/2023 5:46:41 PM

A Sheet No.

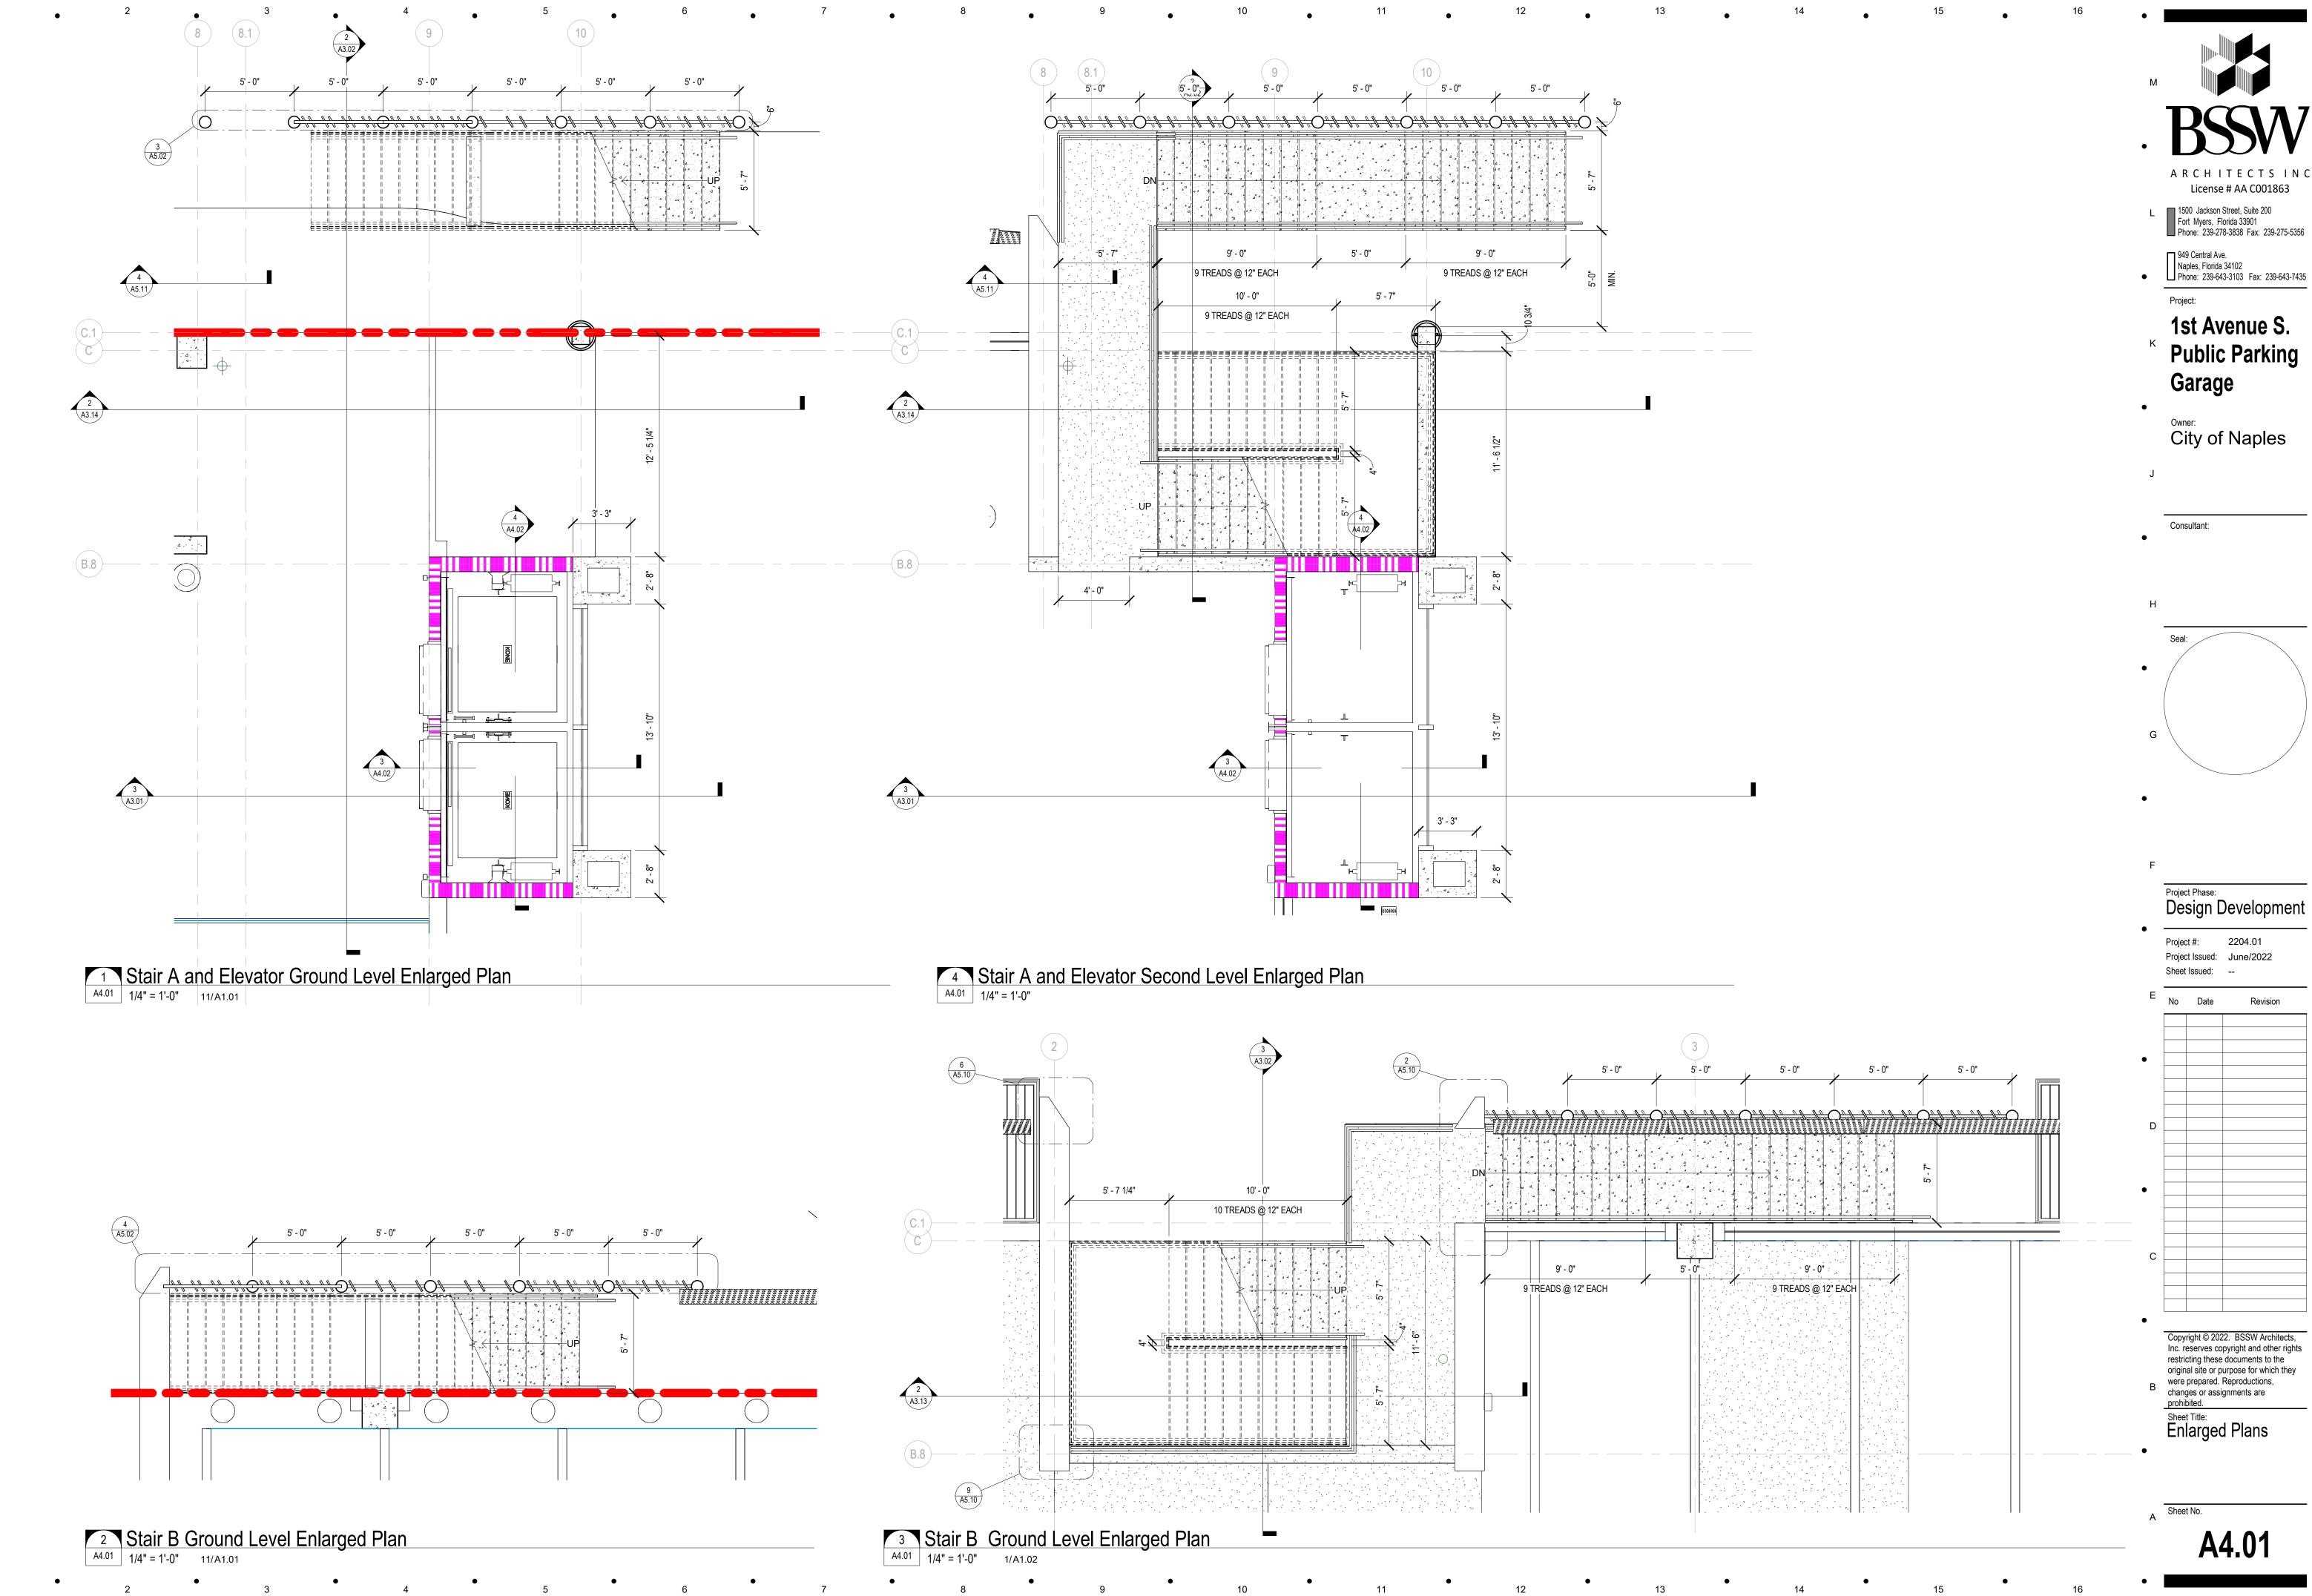



1st Avenue S. **Public Parking**


Design Development

restricting these documents to the original site or purpose for which they

Autodesk Docs://2204.01 - Naples Playhouse Parking Garage/2204.01 - 1st Avenue S. Public Parking Garage_R-22.rvt 1/12/2023 5:46:43 PM

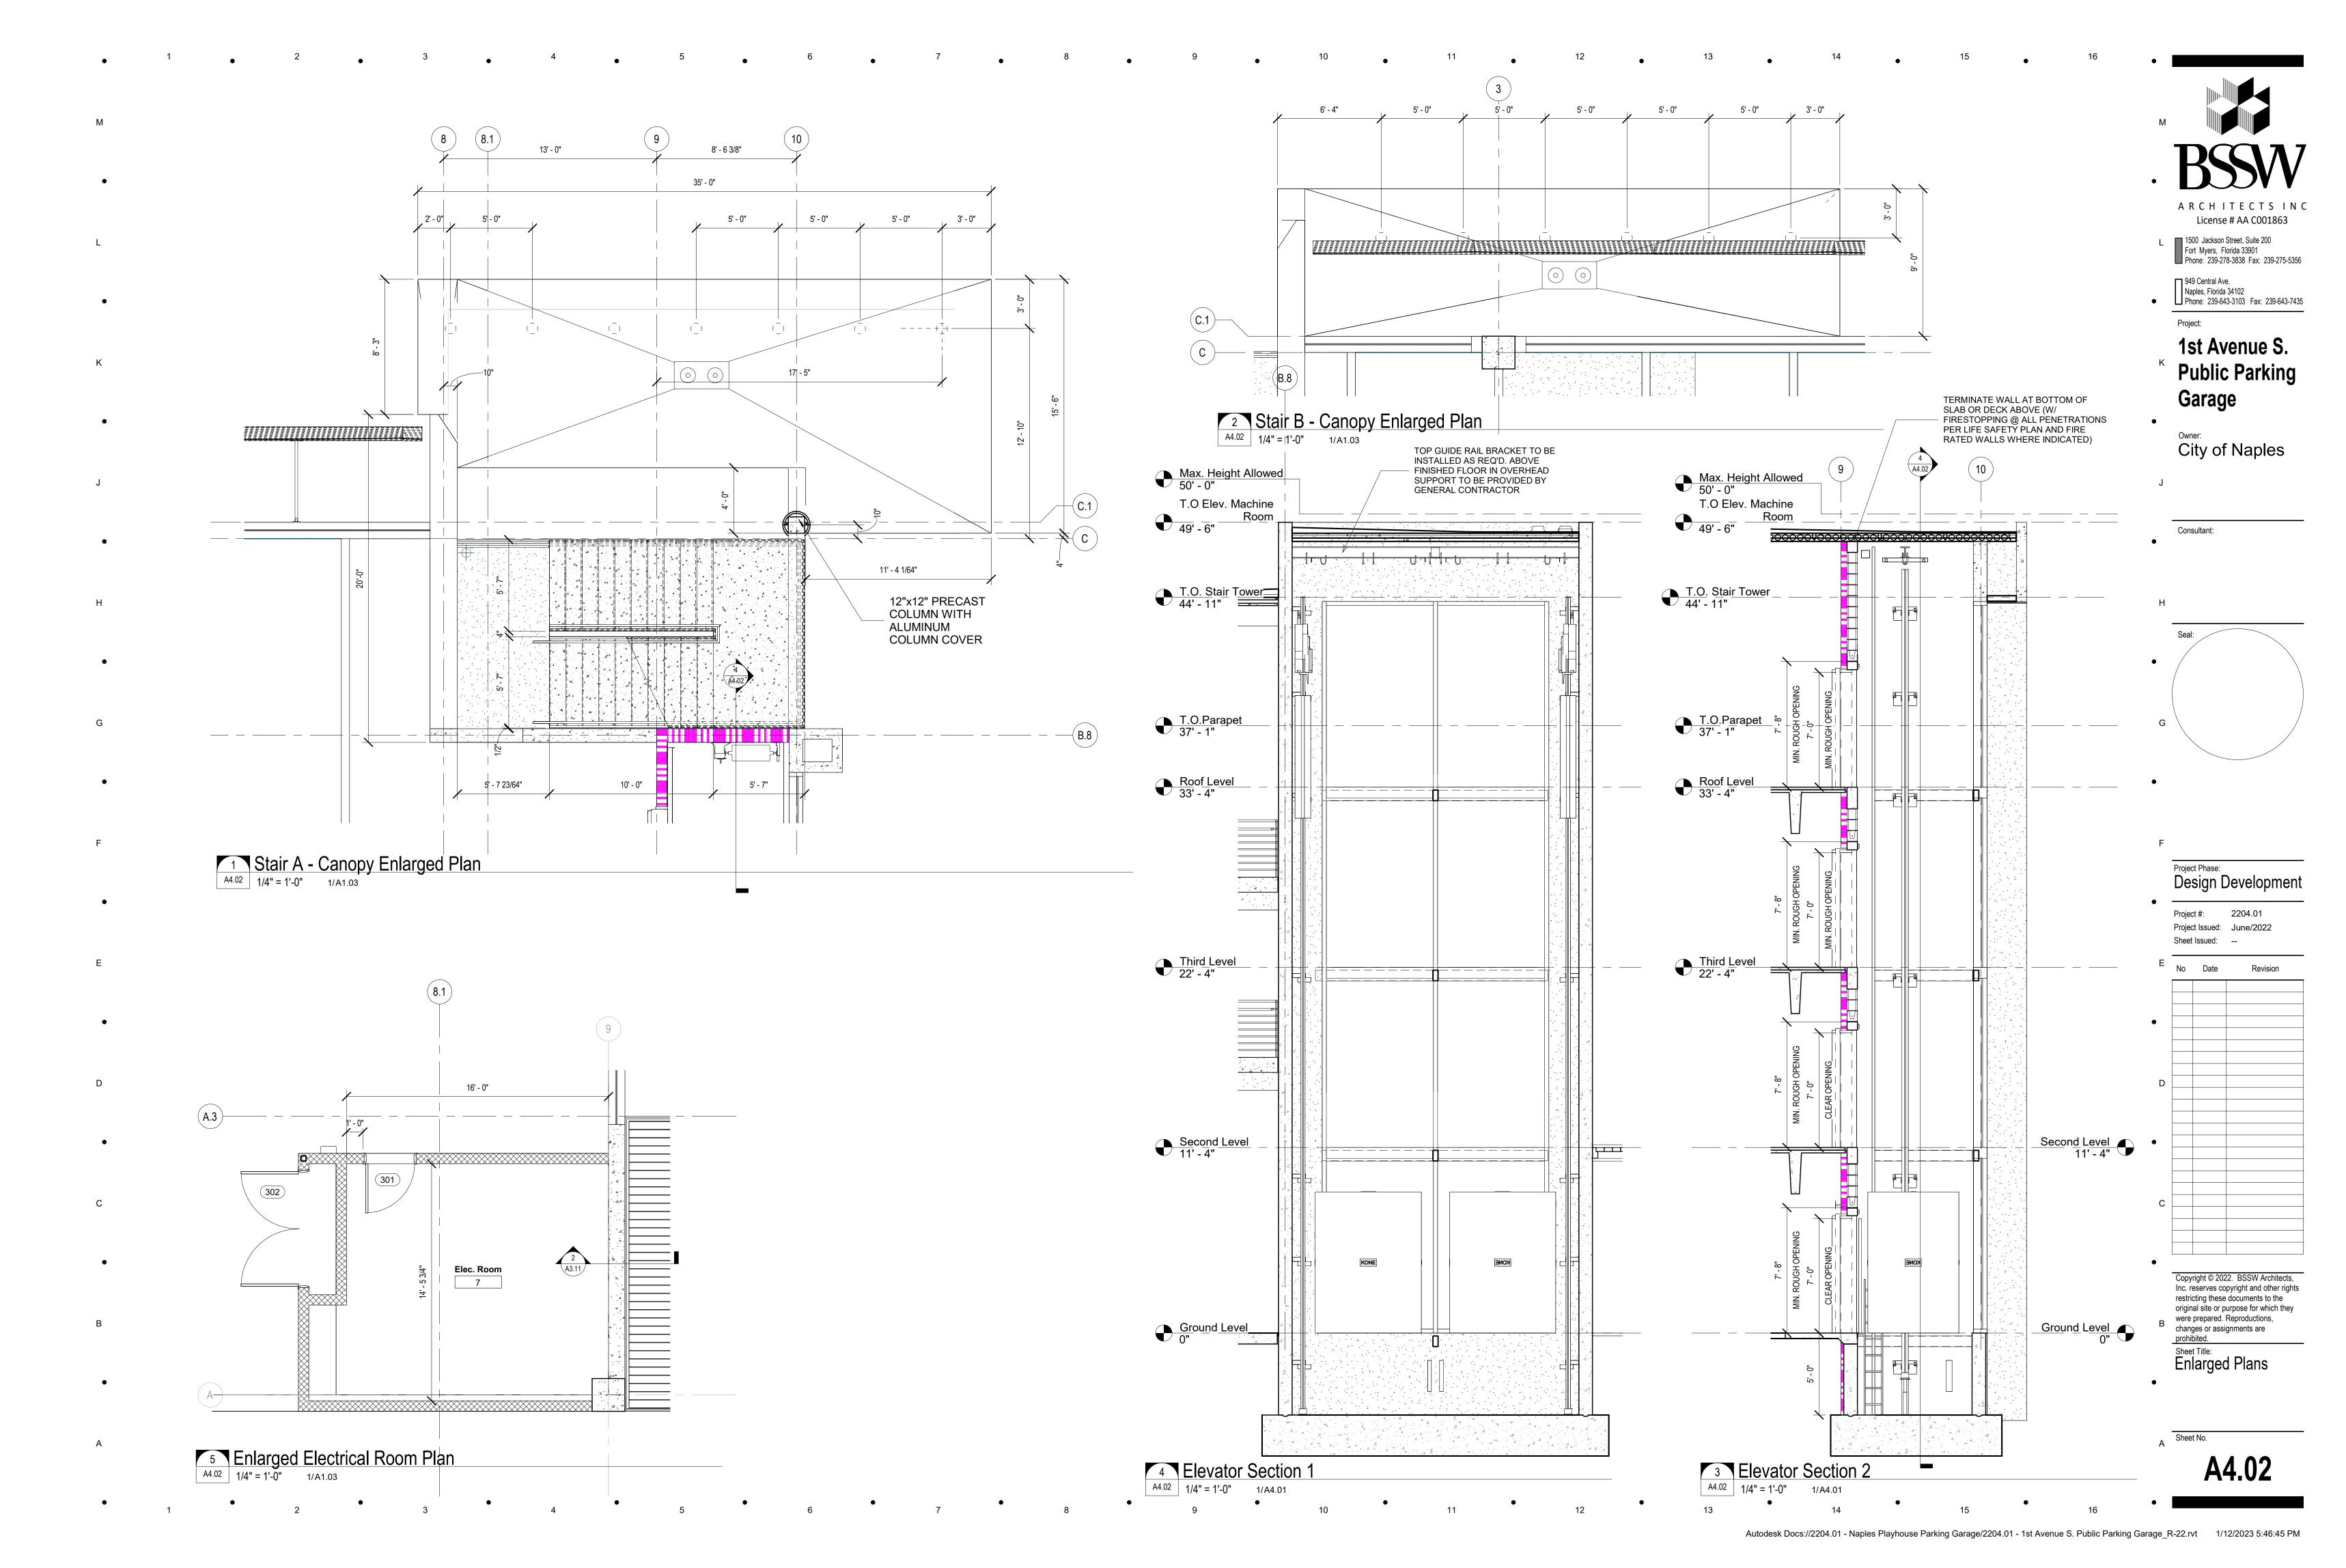

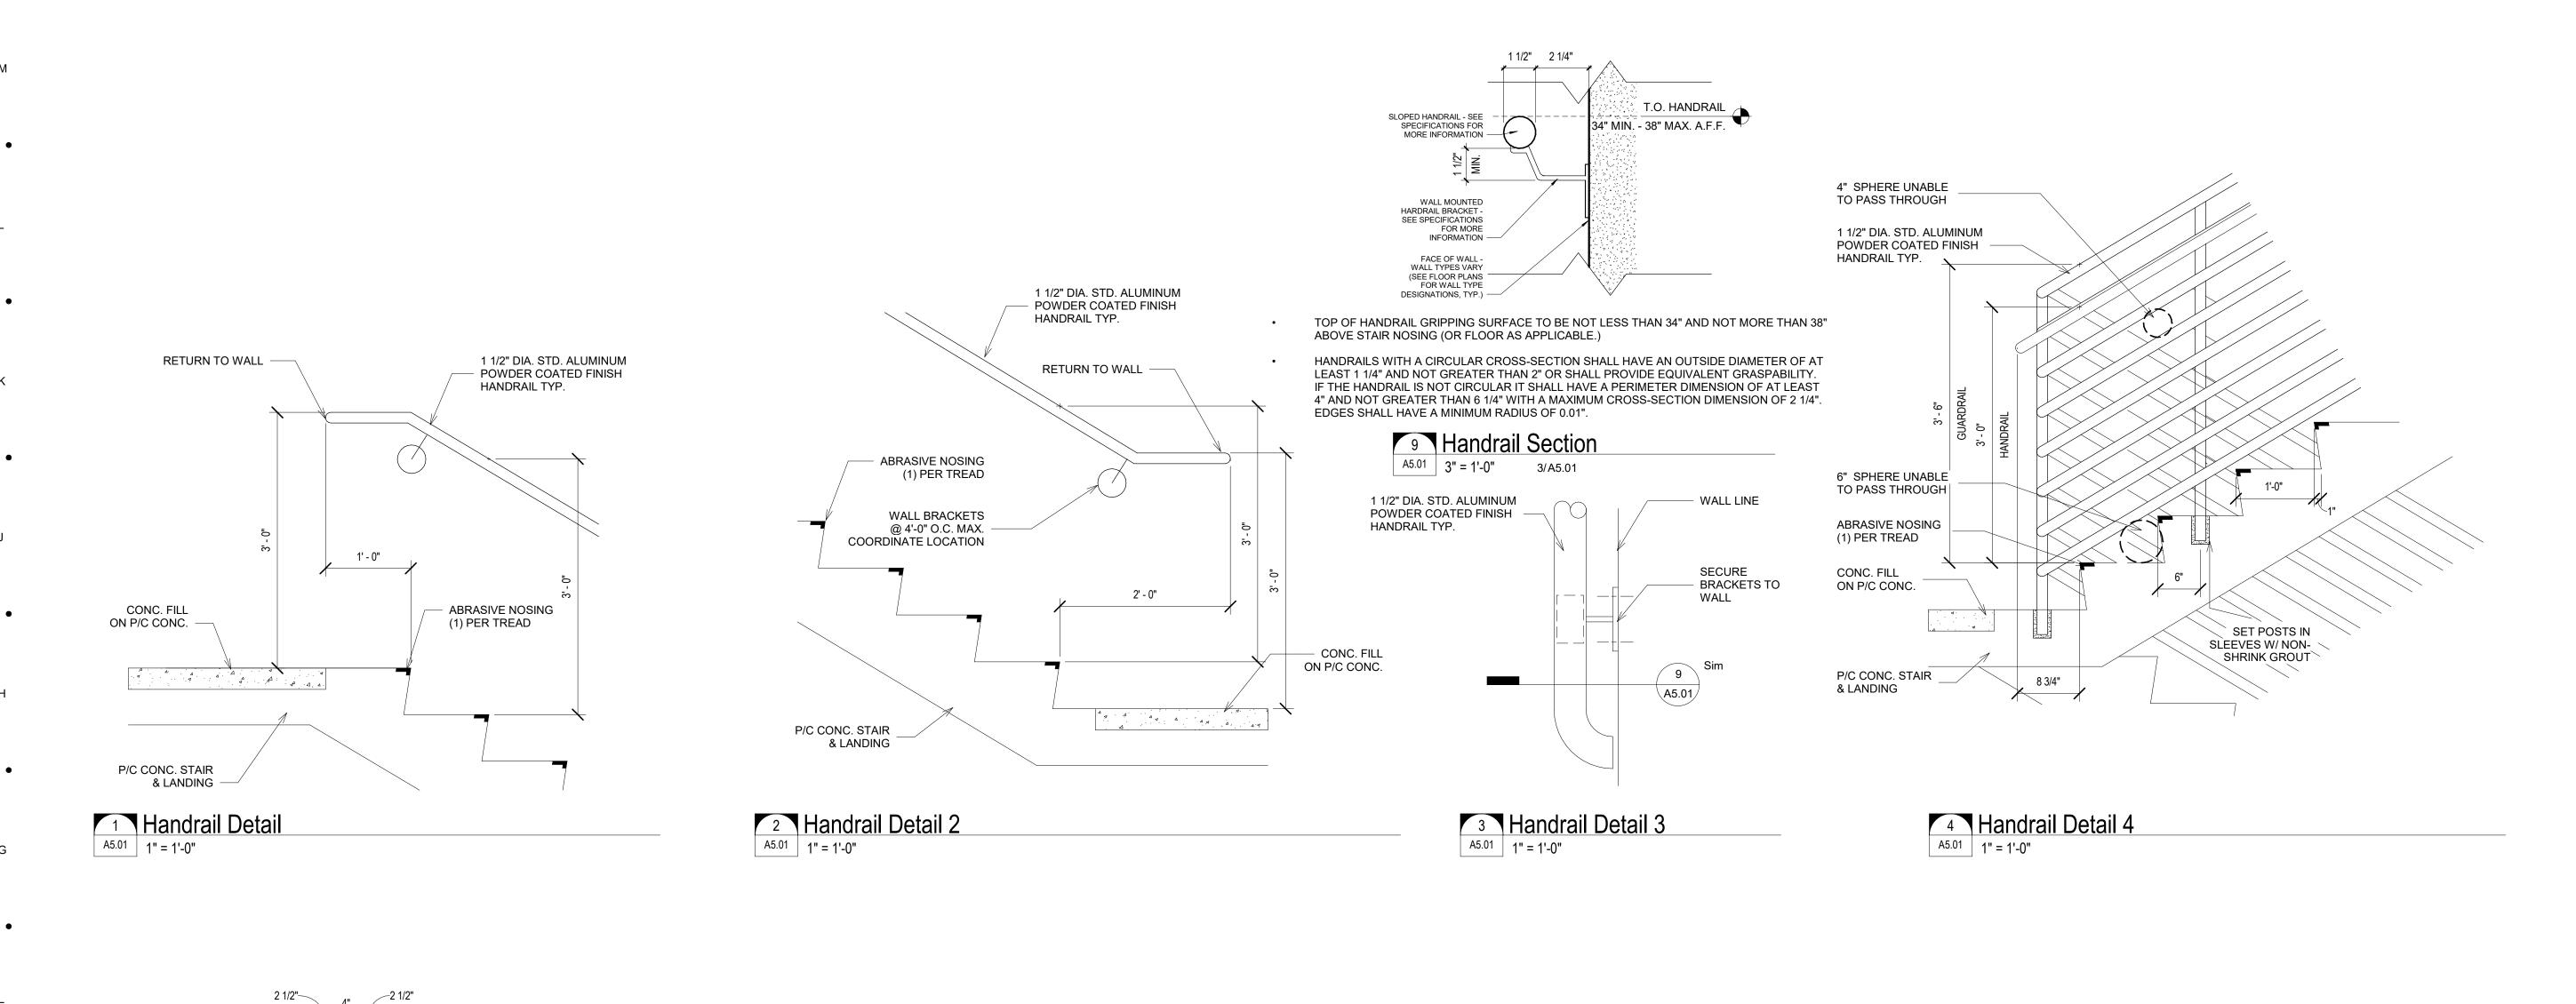

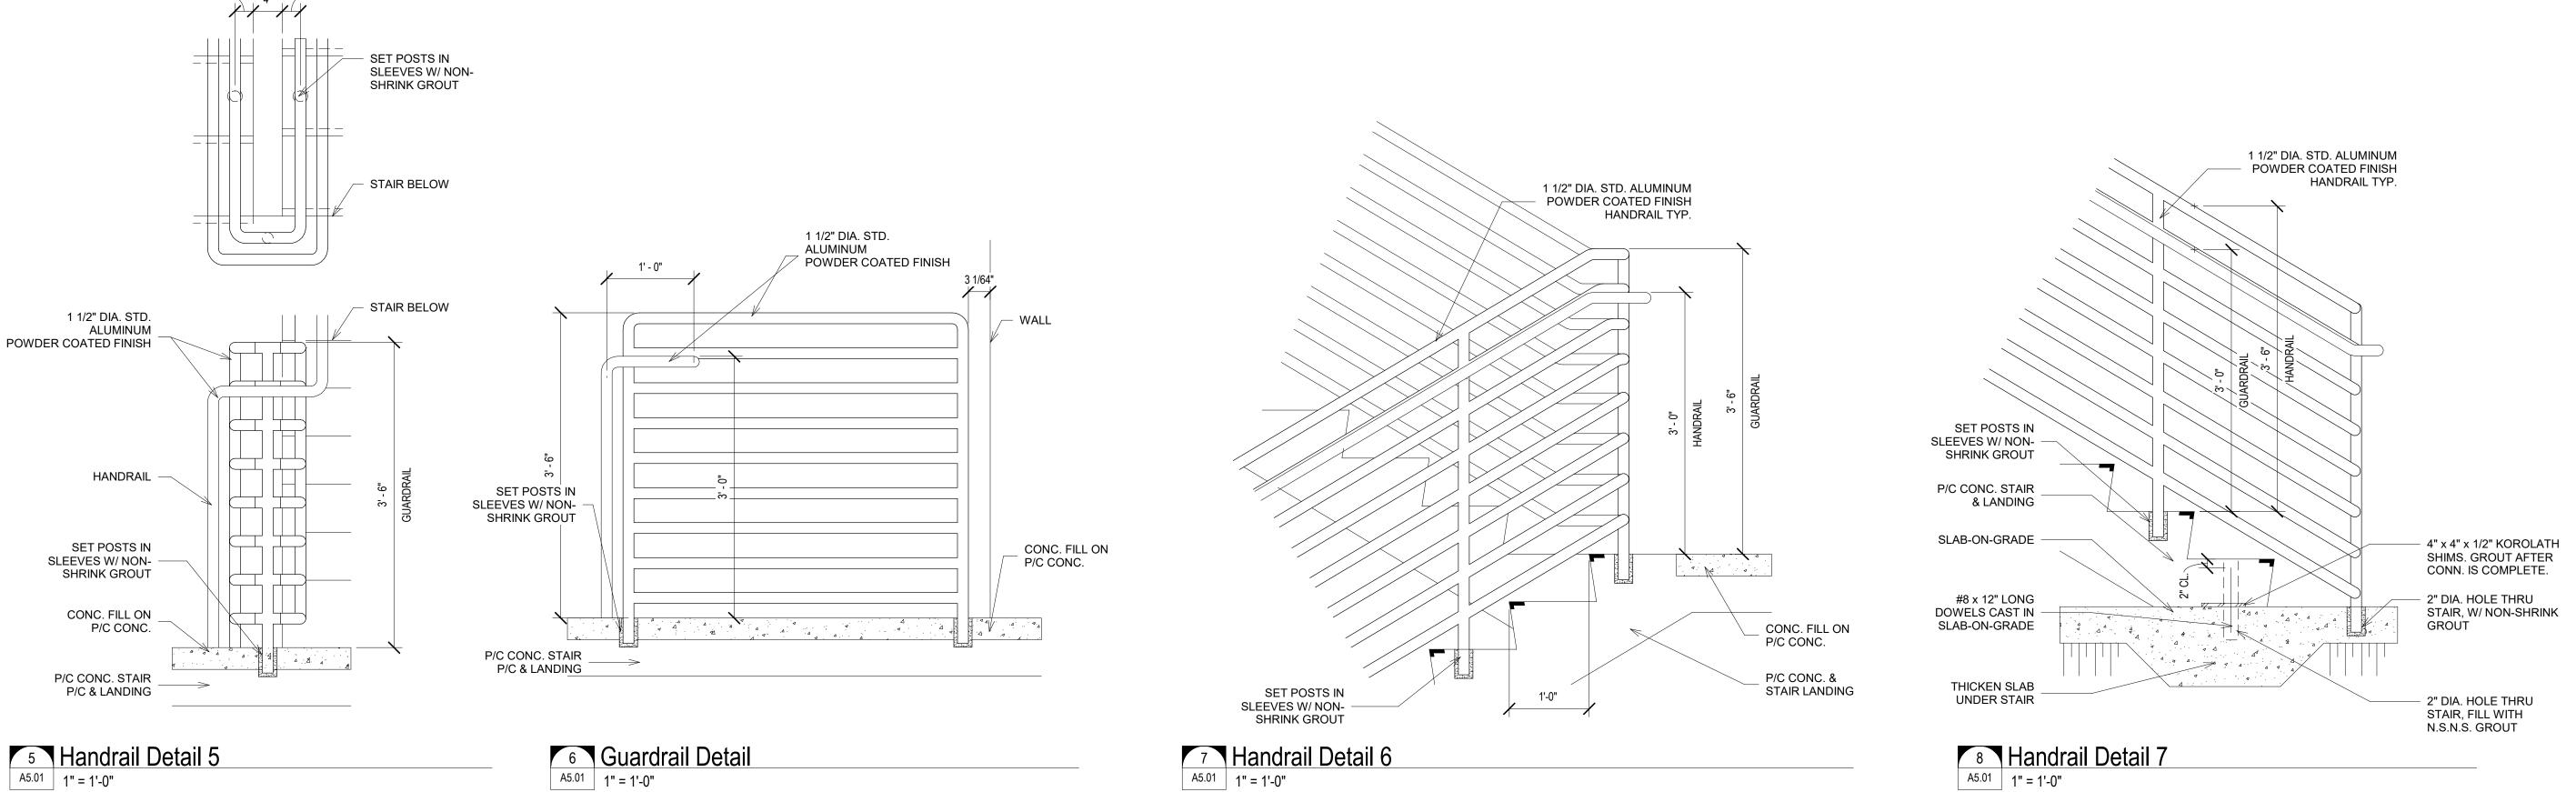

BSSVV

ARCHITECTS INC
License # AA C001863

L | 1500 Jackson Street, Suite 200 Fort Myers, Florida 33901 Phone: 239-278-3838 Fax: 239-275-5356

949 Central Ave.
Naples, Florida 34102
Phone: 239-643-3103 Fax: 239-643-7435

- · ·

1st Avenue S. Public Parking Garage

Owner:
City of Naples

Consultant:

Seal:

Project Phase:
Design Development

Project #: 2204.01
Project Issued: June/2022
Sheet Issued: --

No Date Revision

Copyright © 2022. BSSW Architects, Inc. reserves copyright and other rights restricting these documents to the original site or purpose for which they were prepared. Reproductions,


changes or assignments are prohibited.

Sheet Title:
Typ. Stair Railing Details


Sheet No.

Autodesk Docs://2204.01 - Naples Playhouse Parking Garage/2204.01 - 1st Avenue S. Public Parking Garage_R-22.rvt 1/12/2023 5:46:47 PM

A5.01

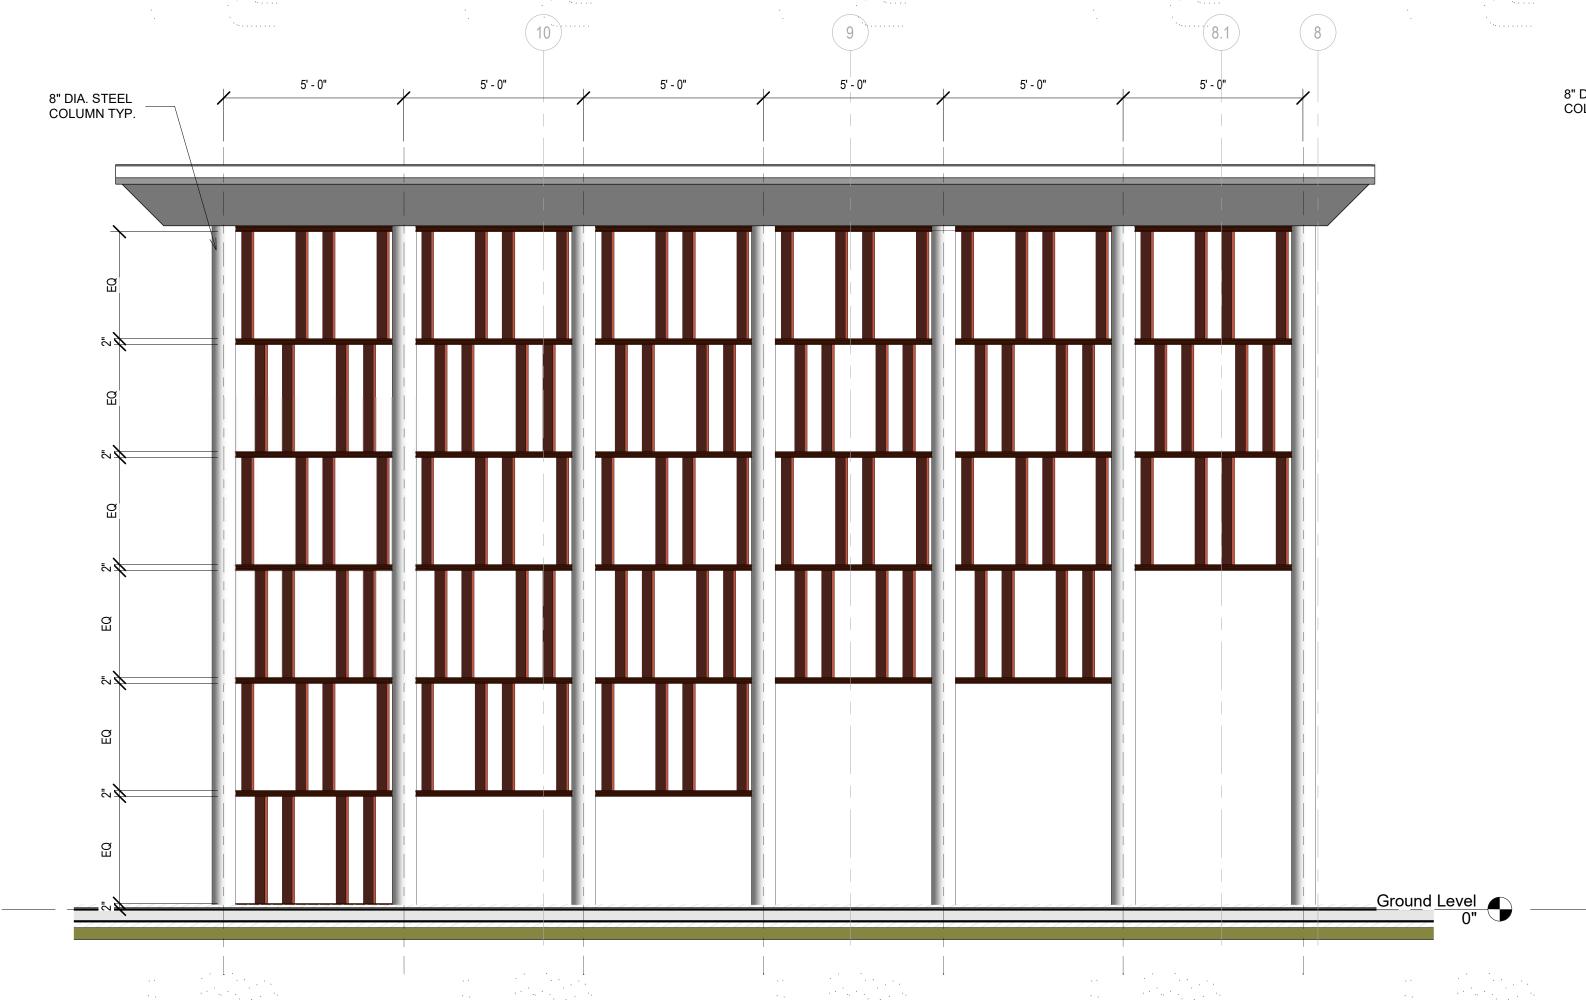


Sunshade Elevation Stair A A5.02 3/8" = 1'-0" 1/A2.01

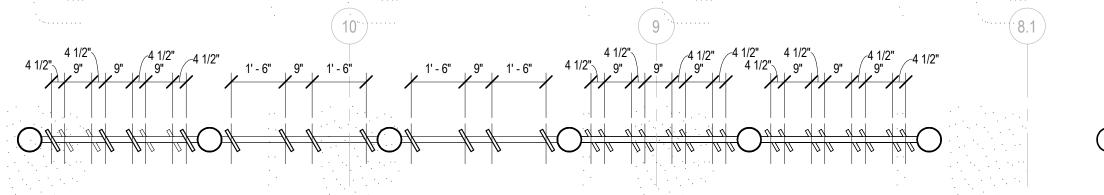


3 Sunshade Floor Plan Stair A A5.02 3/8" = 1'-0" 1/A4.01

Е

D D

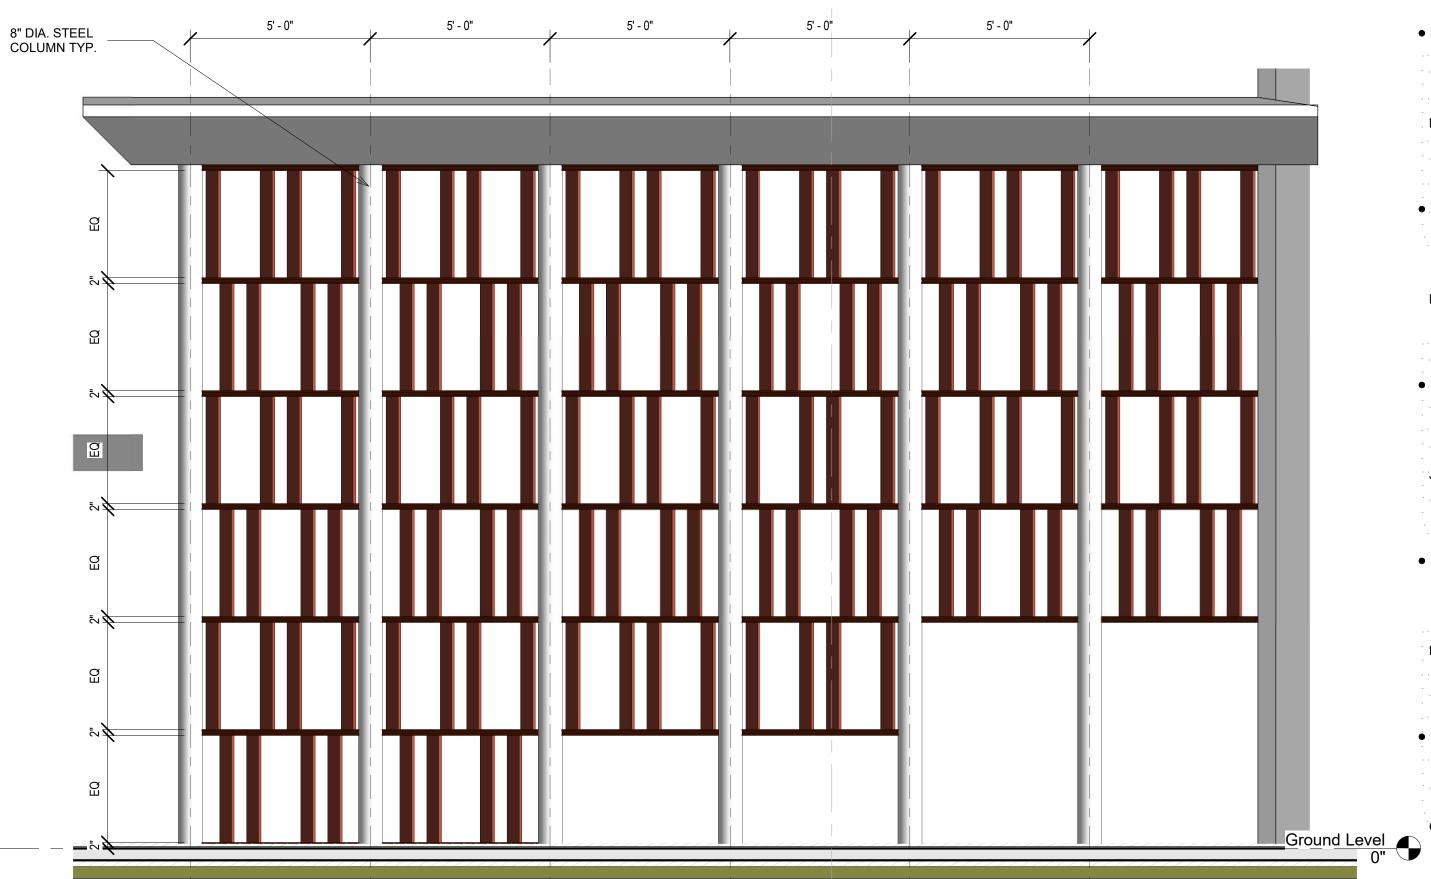

Sunshade Elevation Stair B

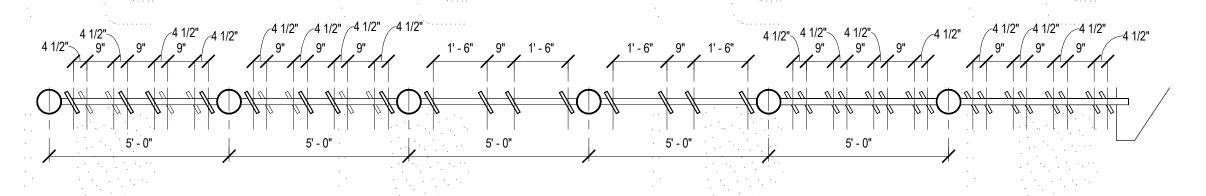

...12....

4 Sunshade Floor Plan Stair B A5.02 3/8" = 1'-0" 2/A4.01

Project Phase: Design Development

License # AA C001863

Phone: 239-278-3838 Fax: 239-275-5356

1500 Jackson Street, Suite 200 Fort Myers, Florida 33901

949 Central Ave.
Naples, Florida 34102
Phone: 239-643-3103 Fax: 239-643-7435

1st Avenue S.

City of Naples

Garage

Consultant:

Public Parking

Project #: 2204.01 Project Issued: June/2022

Sheet Issued:


No Date


Copyright © 2022. BSSW Architects, Inc. reserves copyright and other rights restricting these documents to the original site or purpose for which they were prepared. Reproductions, changes or assignments are

Autodesk Docs://2204.01 - Naples Playhouse Parking Garage/2204.01 - 1st Avenue S. Public Parking Garage_R-22.rvt 1/12/2023 5:46:49 PM

Sunshade Elevation &

A Sheet No.

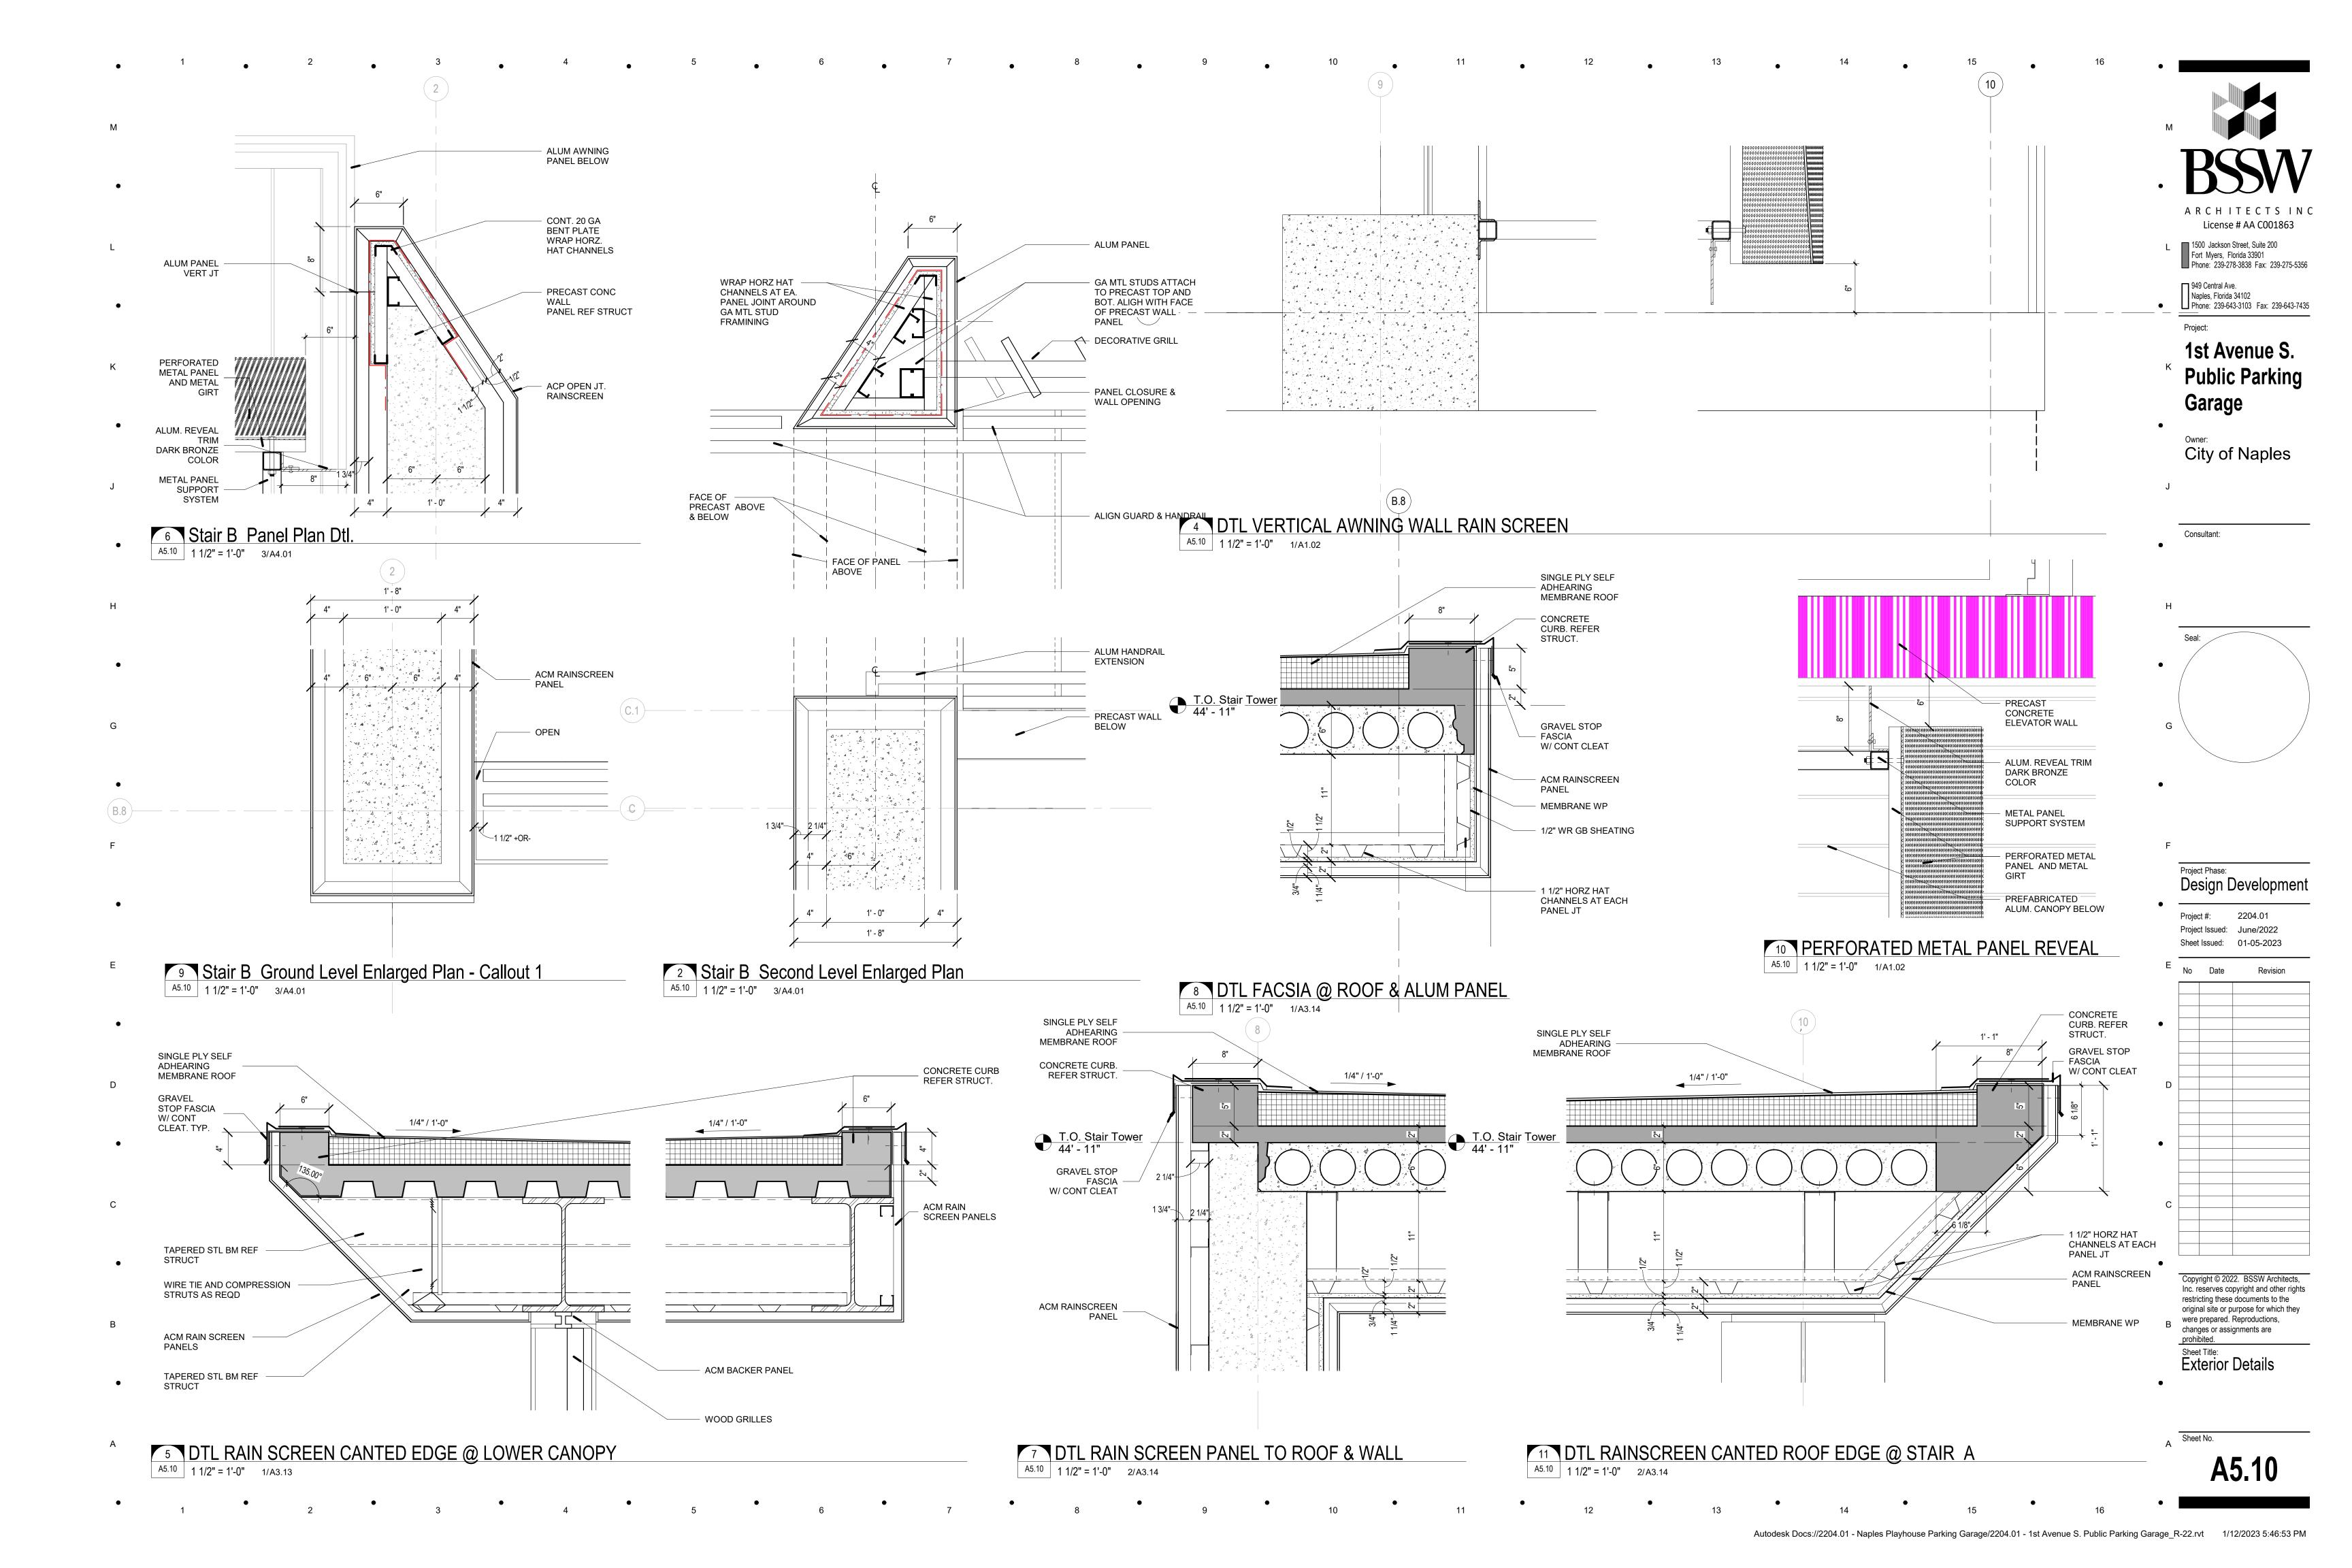

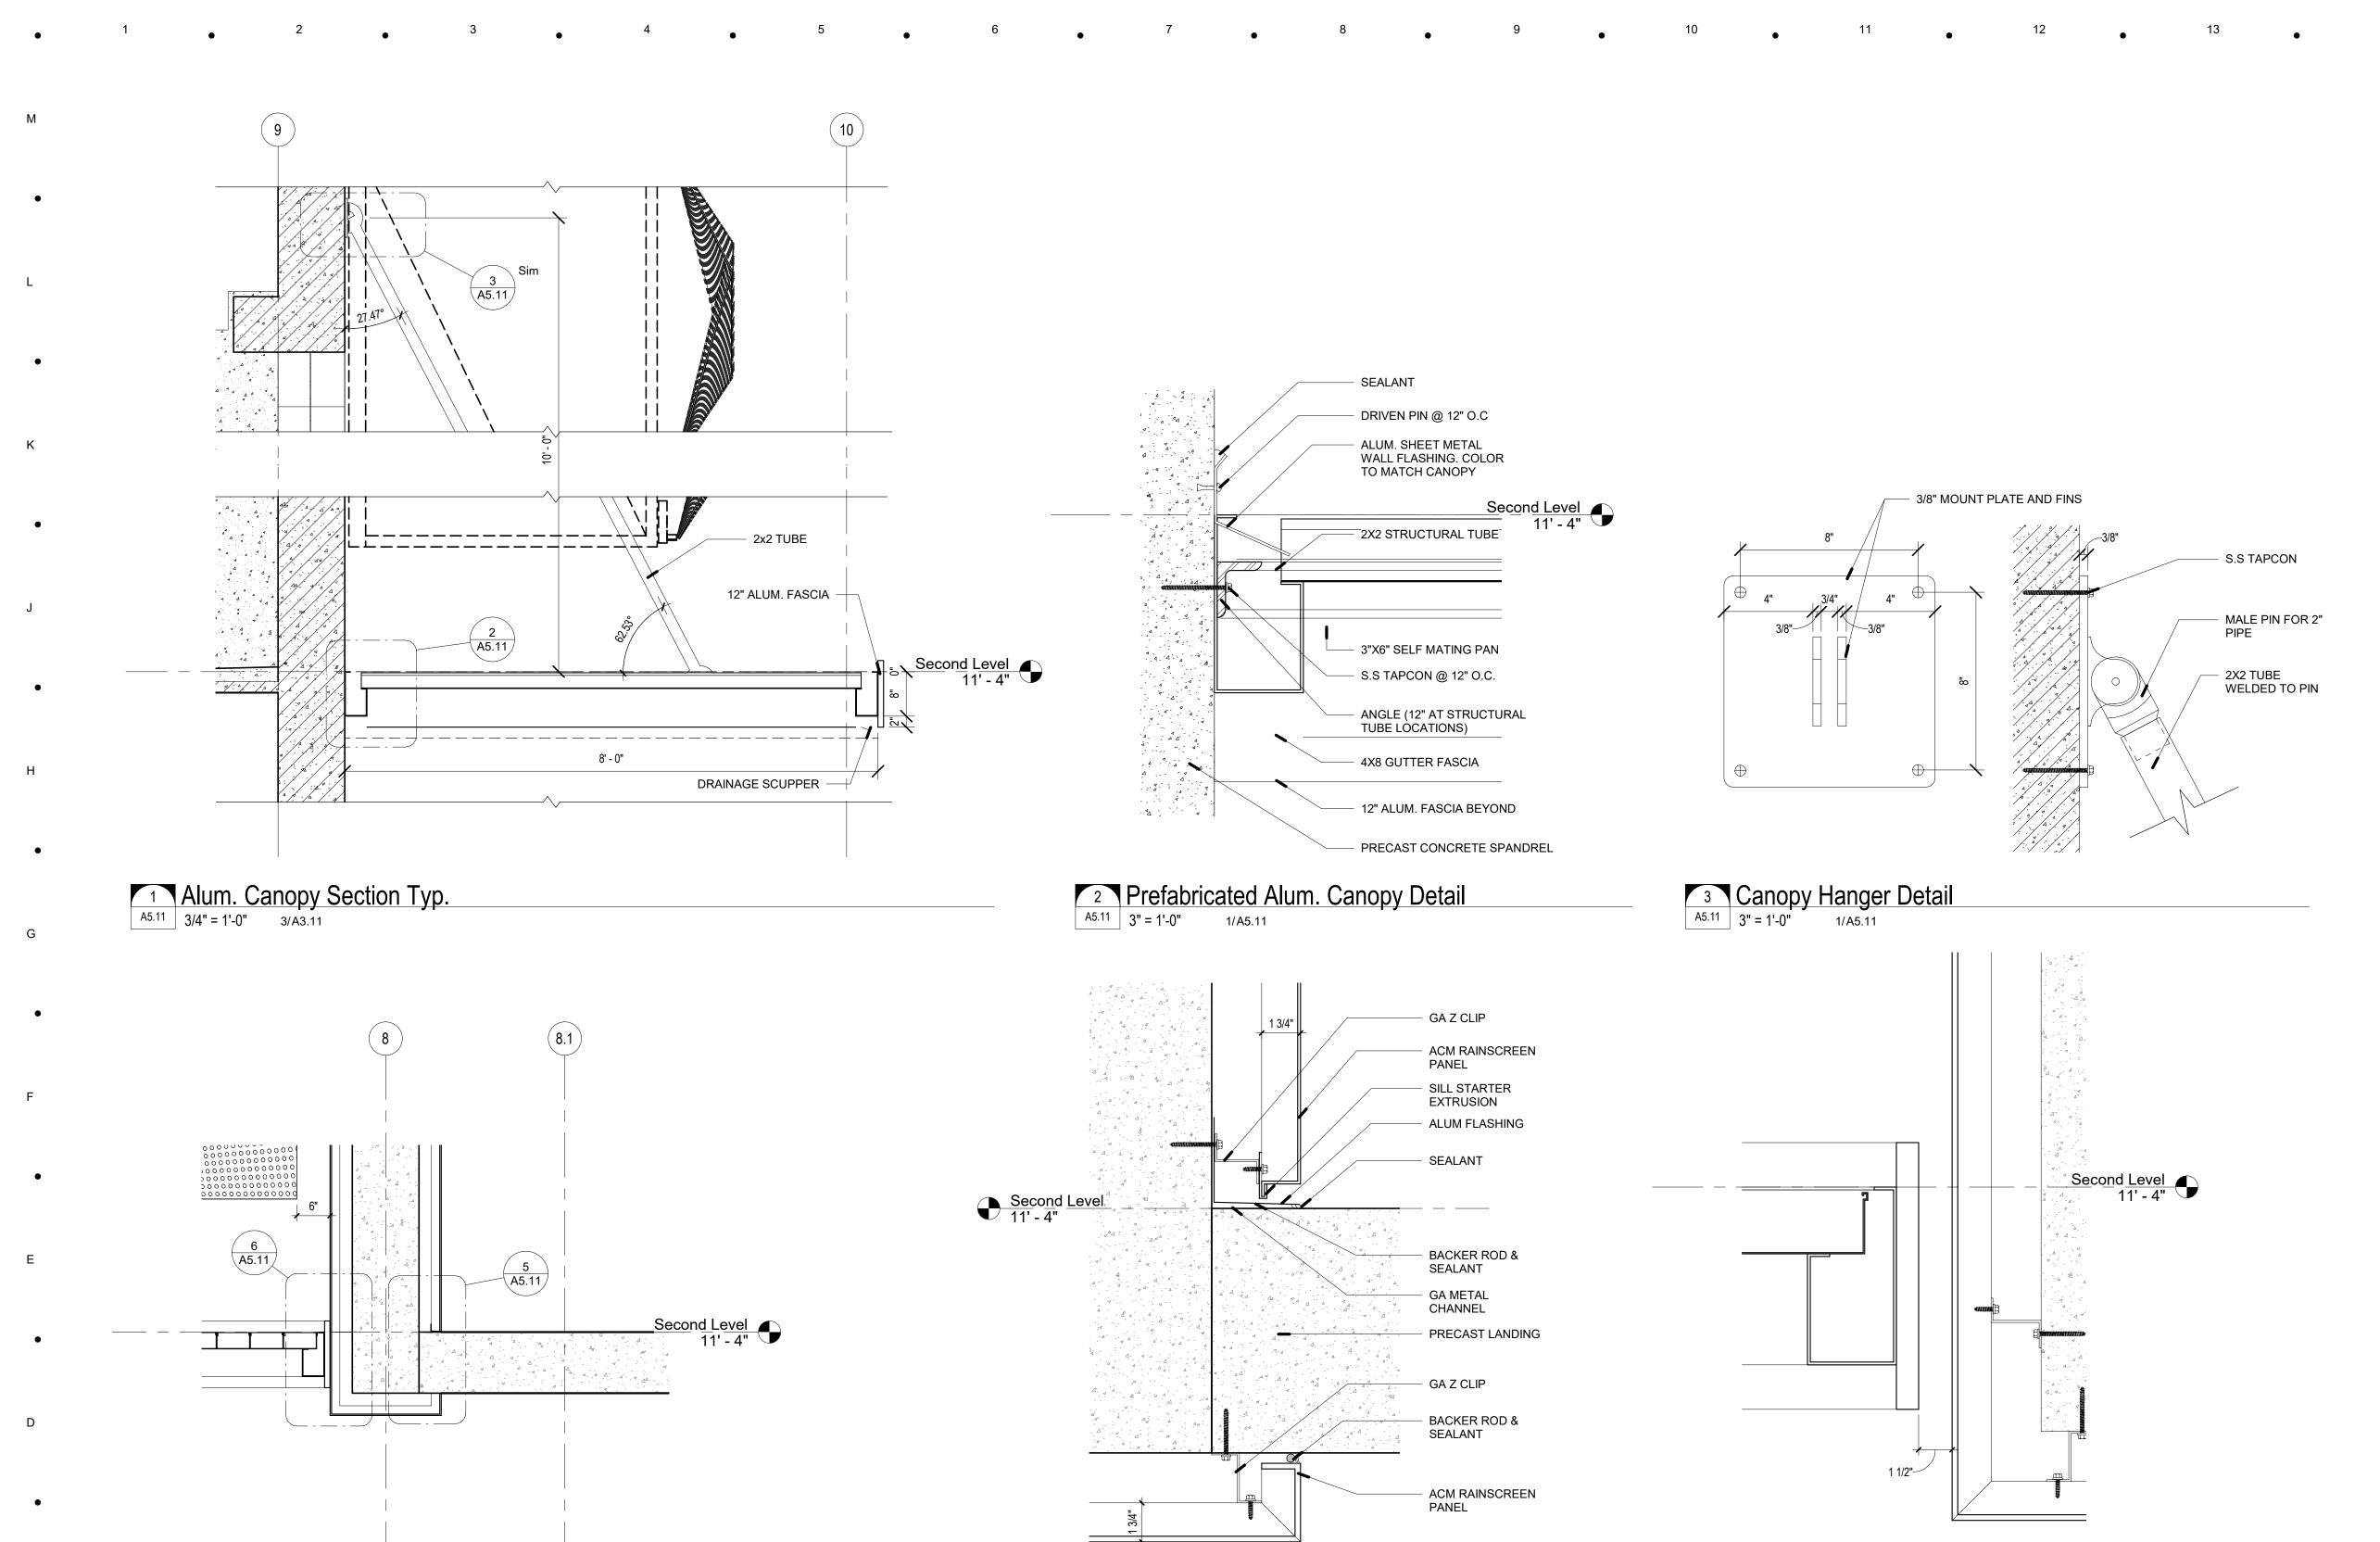

5 ACM Panels Termination Detail 1

A5.11 3" = 1'-0" 4/A5.11

6 ACM Panels Termination Detail 2

4/A5.11

A5.11 3" = 1'-0"

4 Section @ Stair A Landing

A5.11 3/4" = 1'-0" 1/A4.01

A R C H I T E C T S I N C License # AA C001863

1500 Jackson Street, Suite 200 Fort Myers, Florida 33901 Phone: 239-278-3838 Fax: 239-275-5356

949 Central Ave.
Naples, Florida 34102
Phone: 239-643-3103 Fax: 239-643-7435

1st Avenue S. **Public Parking** Garage

City of Naples

Consultant:

Project Phase: Design Development

Project #: 2204.01 Project Issued: June/2022 Sheet Issued: 01-05-2023

E	No	Date	Revision
D			
С			


Copyright © 2022. BSSW Architects, Inc. reserves copyright and other rights restricting these documents to the original site or purpose for which they were prepared. Reproductions, changes or assignments are

Sheet Title: Exterior Details

A Sheet No.

Autodesk Docs://2204.01 - Naples Playhouse Parking Garage/2204.01 - 1st Avenue S. Public Parking Garage_R-22.rvt 1/12/2023 5:47:03 PM

A5.11

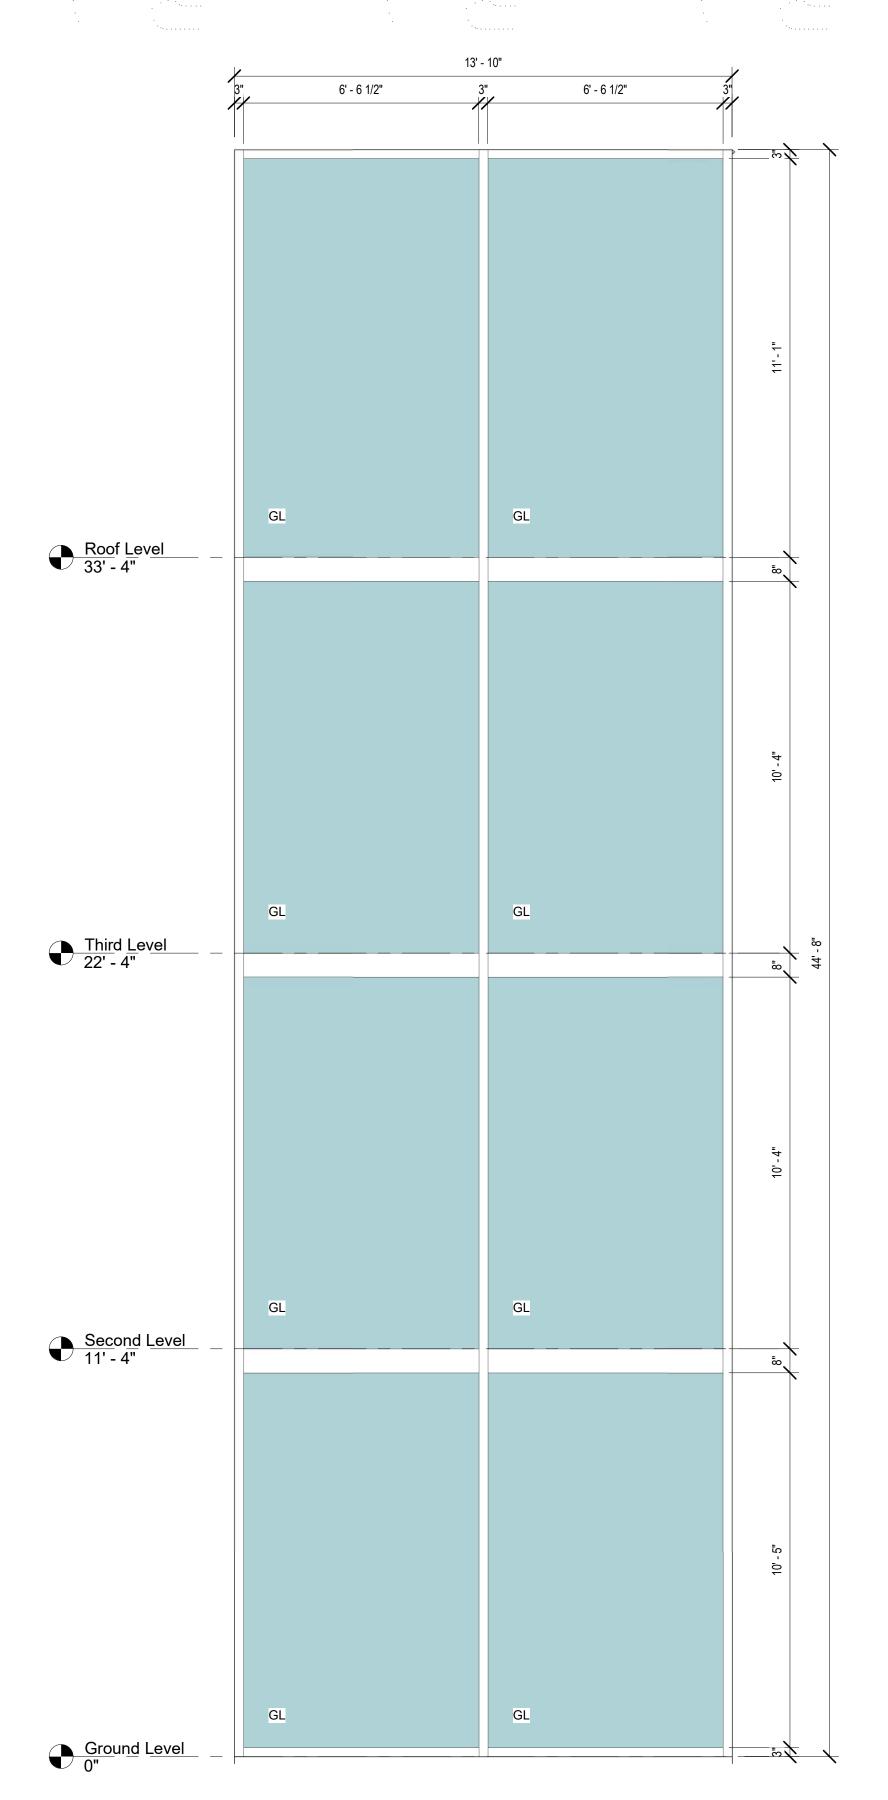


Ε

• . D

[.].....В

CURTAIN WALL ELEVATION

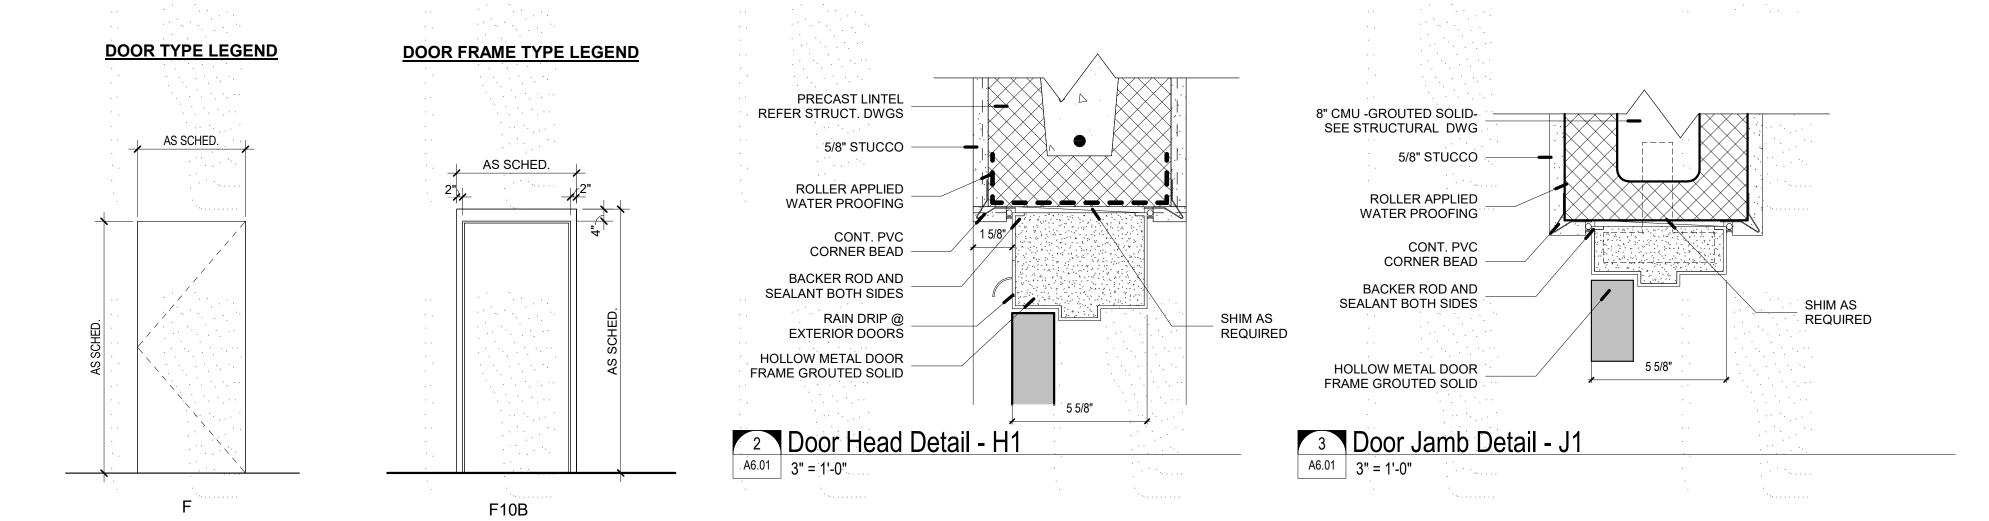

			DOORS A	AND FRAMES SCHEDULE		
	ROOM	DOOR PANEL	DOOF	R FRAME	FIRE DETAILS	
MARK	FROM TO	PNL# MAT'L FINISH WIDTH HEIGHT	TYPE MAT'L FINISH TYPE WIDTH		RATING (MIN.) HEAD JAMB SILL	NOTES Appear In Schedule
Third Level						
301	Elec. Room	SGL WD 3' - 0" 7' - 0"	F HM F10B 3'-4"	7' - 4"	H1 J1	Yes
302	Elev. Control Room	PAIR WD 7' - 0" 7' - 0"	F HM F10B 7' - 4"	7' - 4"		Yes
Grand total: 2	1					

· .12 · · ·

GLAZING LEGEND		
G1 IMPACT, INSULATED, LOW E WITH STANDARI) TINTE) GLASS
or min nor, incoextres, low is with on morning		, 02, 100
WIND SPEED: 170 MPH/ 132 MPH NOMINAL		
WIND SI EED. 170 WITH 132 WITH NOWINAL		
EXPOSURE: C		
EXPOSURE : C RISK CATEGORY : II	• .	




1500 Jackson Street, Suite 200 Fort Myers, Florida 33901 Phone: 239-278-3838 Fax: 239-275-5356

949 Central Ave.
Naples, Florida 34102
Phone: 239-643-3103 Fax: 239-643-7435

1st Avenue S.
Public Parking
Garage

Owner:
City of Naples

Consultant:

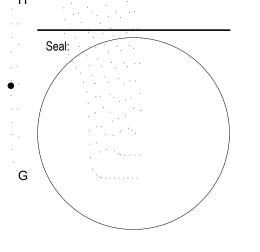

Project Phase:

Design Development

Project #: 2204.01
Project Issued: June/2022
Sheet Issued: --

No Date Revision

Copyright © 2022. BSSW Architects, Inc. reserves copyright and other rights restricting these documents to the original site or purpose for which they were prepared. Reproductions, changes or assignments are


changes or assignments are prohibited.


Sheet Title:
Door and Frame Types

A Sheet No.


A6.01


Autodesk Docs://2204.01 - Naples Playhouse Parking Garage/2204.01 - 1st Avenue S. Public Parking Garage_R-22.rvt 1/12/2023 5:47:14 PM

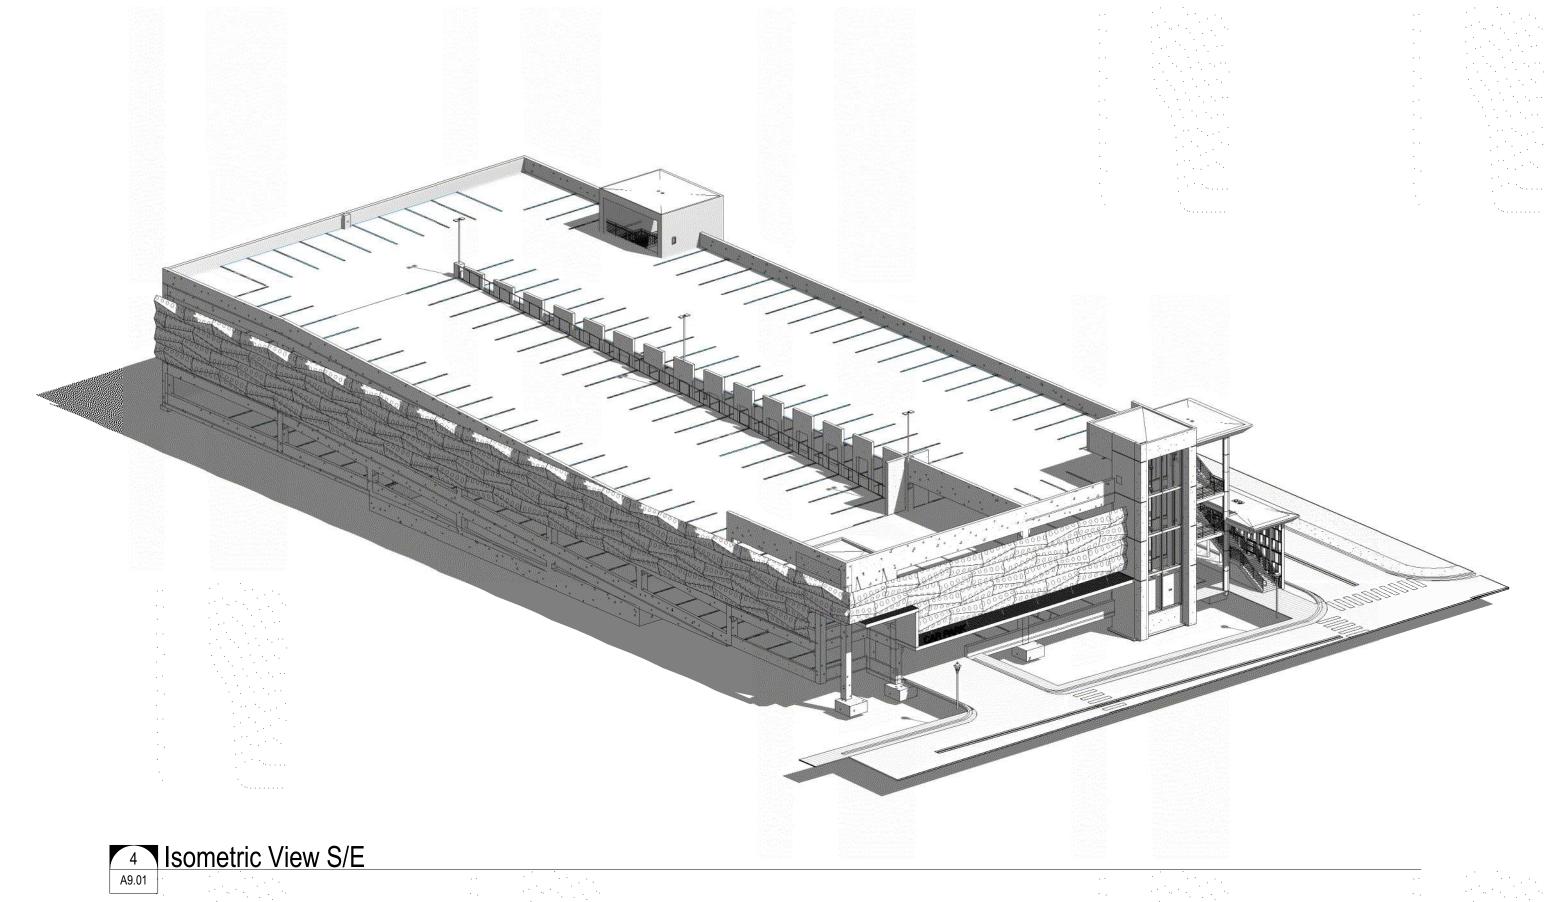

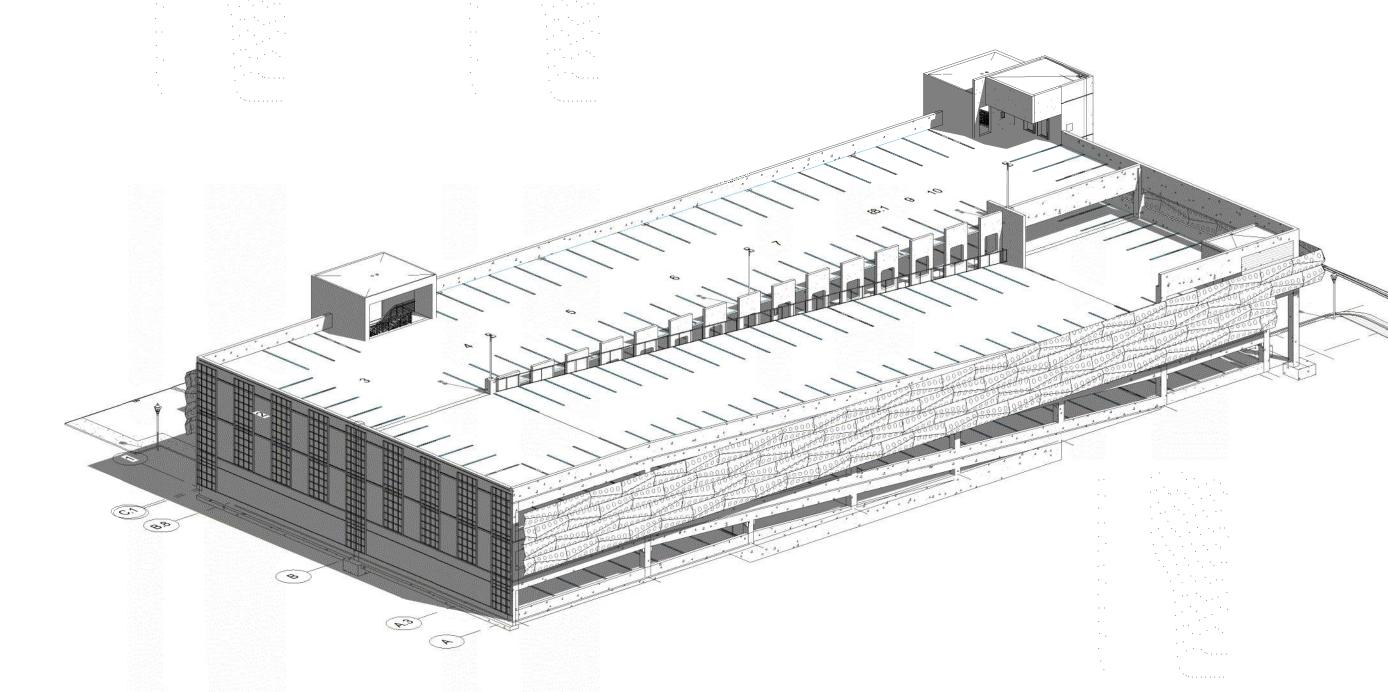

1 Isometric View S/W

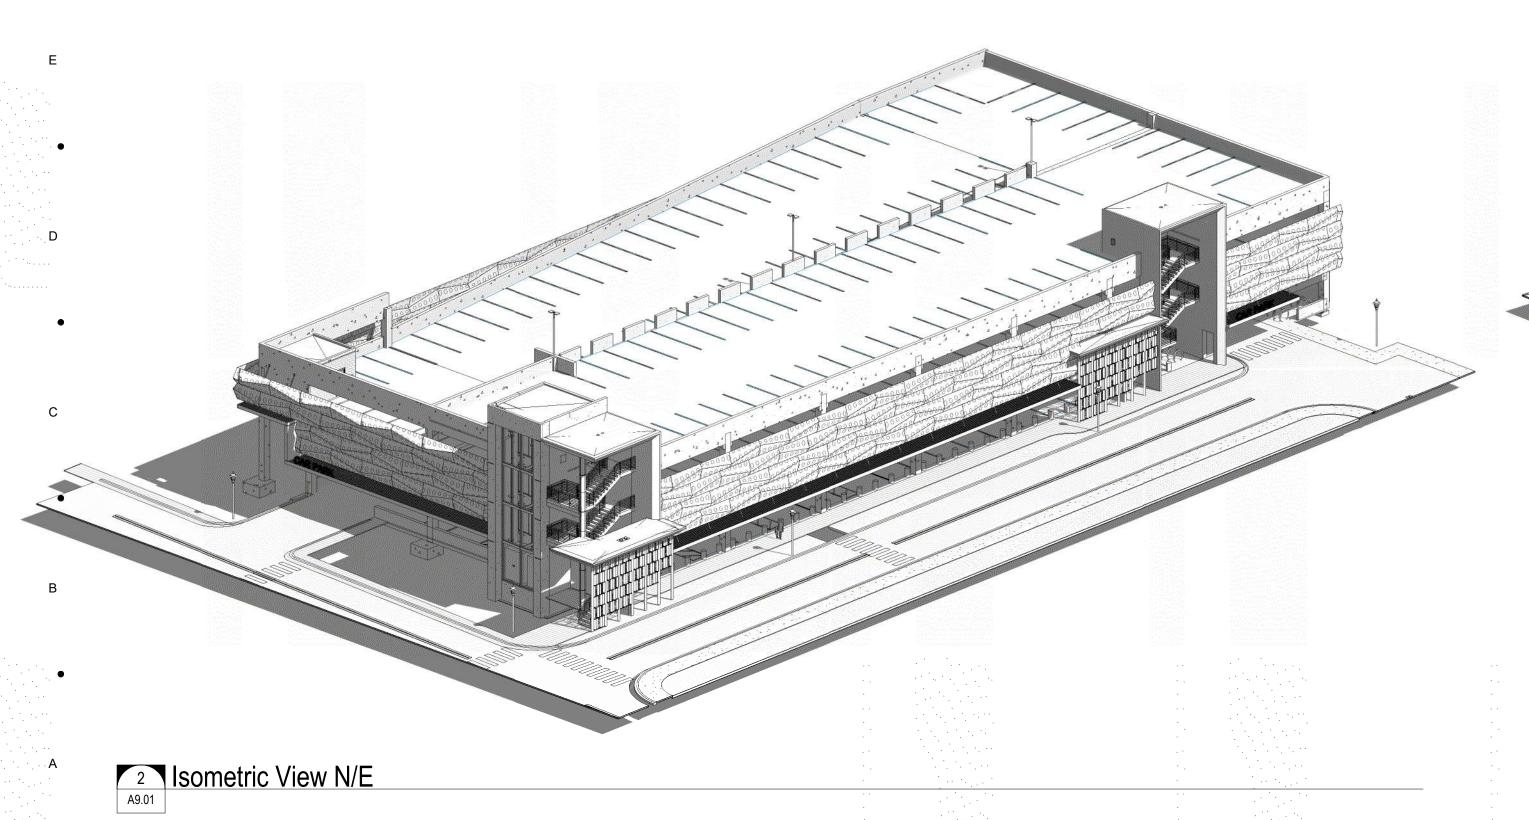

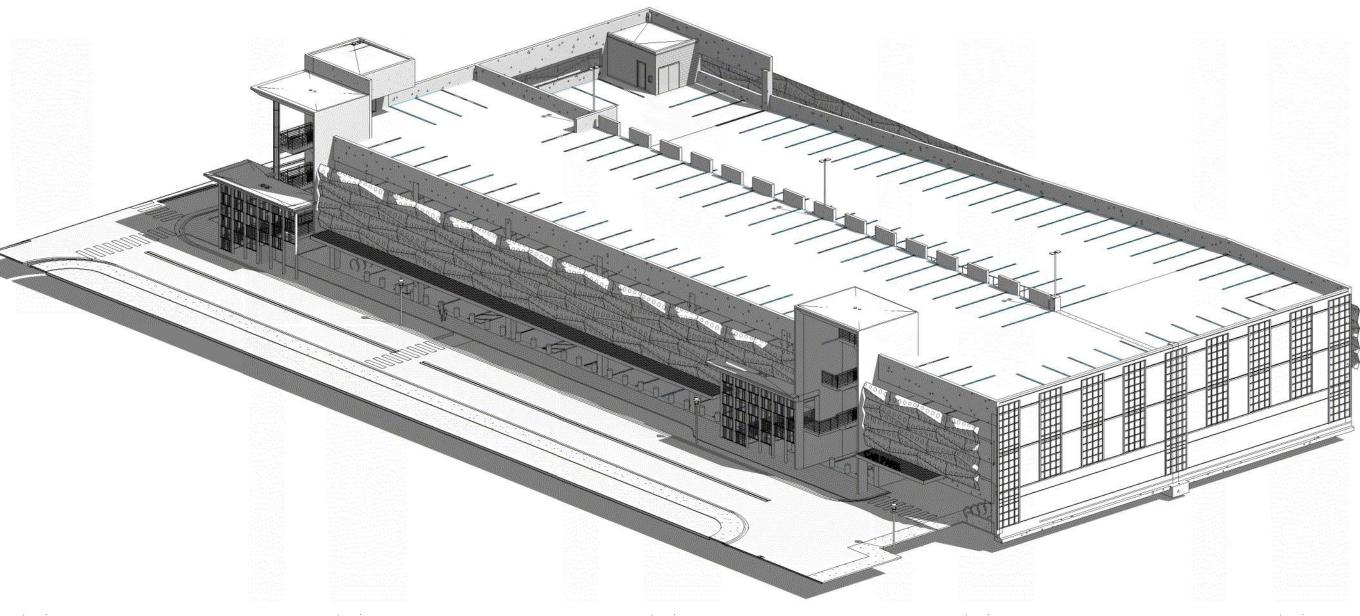

3 Isometric View N/W

BSSVV

ARCHITECTS INC
License # AA C001863

Phone: 239-278-3838 Fax: 239-275-5356

949 Central Ave.
Naples, Florida 34102
Phone: 239-643-3103 Fax: 239-643-7435

-

1st Avenue S.
Public Parking
Garage

Owner:
City of Naples

Consultant:

Seal:

Project Phase:
Design Development

Project #: 2204.01
Project Issued: June/2022
Sheet Issued: 01-05-2023

No	Date	Revision
		• •
		*. **
		. `.
		· · · ·
		. *-
		· .
	1 1 1 1 1 1	
		*. **
		·

Copyright © 2022. BSSW Architects, Inc. reserves copyright and other rights restricting these documents to the original site or purpose for which they were prepared. Reproductions, changes or assignments are prohibited.

Sheet Title: 3D Views

A A A

Autodesk Docs://2204.01 - Naples Playhouse Parking Garage/2204.01 - 1st Avenue S. Public Parking Garage_R-22.rvt 1/12/2023 5:48:28 PM





A R C H I T E C T S I N C
License # AA C001863

1500 Jackson Street, Suite 200
Fort Myers, Florida 33901
Phone: 239-278-3838 Fax: 239-275-5356


949 Central Ave.
Naples, Florida 34102
Phone: 239-643-3103 Fax: 239-643-7435

Project:

1st Avenue S. Public Parking Garage

City of Naples

Consultant:

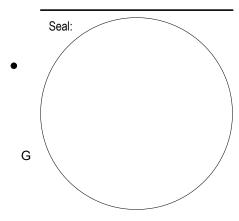

Design Development

Project #: 2204.01
Project Issued: June/2022
Sheet Issued: 01-05-2023

Е	No	Date	Revision
•			
_			
D			
•			
С			
-			

Copyright © 2022. BSSW Architects, Inc. reserves copyright and other rights restricting these documents to the original site or purpose for which they were prepared. Reproductions, changes or assignments are

Sheet Title: 3D Rendering

Sheet No.

Autodesk Docs://2204.01 - Naples Playhouse Parking Garage/2204.01 - 1st Avenue S. Public Parking Garage_R-22.rvt 1/12/2023 5:48:29 PM






949 Central Ave.
Naples, Florida 34102
Phone: 239-643-3103 Fax: 239-643-7435

Project:

1st Avenue S. Public Parking Garage

Owner:
City of Naples

Consultant:

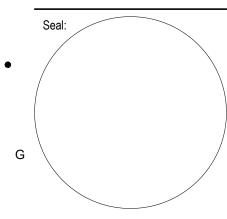

Project Phase: Design Development

Project #: 2204.01
Project Issued: June/2022
Sheet Issued: 01-05-2023

	No	Date	Revision
)			
,			
)			

Copyright © 2022. BSSW Architects, Inc. reserves copyright and other rights restricting these documents to the original site or purpose for which they were prepared. Reproductions, changes or assignments are prohibited.

Sheet Title: 3D Rendering

A Sheet No.

Autodesk Docs://2204.01 - Naples Playhouse Parking Garage/2204.01 - 1st Avenue S. Public Parking Garage_R-22.rvt 1/12/2023 5:48:30 PM






949 Central Ave.
Naples, Florida 34102
Phone: 239-643-3103 Fax: 239-643-7435

Drainati

1st Avenue S. Public Parking Garage

Owner:
City of Naples

Consultant:

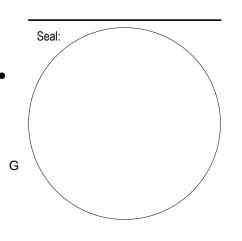

Design Development

Project #: 2204.01
Project Issued: June/2022
Sheet Issued: 01-05-2023

_	No	Date	Revision
_			
•			
D			
_			
•			
С			
_	L		

Copyright © 2022. BSSW Architects, Inc. reserves copyright and other rights restricting these documents to the original site or purpose for which they were prepared. Reproductions, changes or assignments are

prohibited.
Sheet Title:
3D Rendering

. Sheet N

Autodesk Docs://2204.01 - Naples Playhouse Parking Garage/2204.01 - 1st Avenue S. Public Parking Garage_R-22.rvt 1/12/2023 5:48:31 PM






949 Central Ave.
Naples, Florida 34102
Phone: 239-643-3103 Fax: 239-643-7435

1st Avenue S. Public Parking Garage

Owner:
City of Naples

Consulta

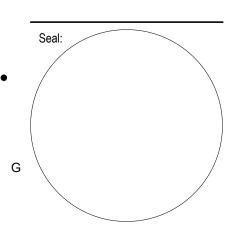

Design Development

Project #: 2204.01
Project Issued: June/2022
Sheet Issued: 01-05-2023

-	No	Date	Revision
)			
)			
		1	

Copyright © 2022. BSSW Architects, Inc. reserves copyright and other rights restricting these documents to the original site or purpose for which they were prepared. Reproductions, changes or assignments are

Sheet Title: 3D Rendering

. Sheet N

Autodesk Docs://2204.01 - Naples Playhouse Parking Garage/2204.01 - 1st Avenue S. Public Parking Garage_R-22.rvt 1/12/2023 5:48:31 PM






949 Central Ave.
Naples, Florida 34102
Phone: 239-643-3103 Fax: 239-643-7435

1st Avenue S. Public Parking Garage

Owner:
City of Naples

Consultant:

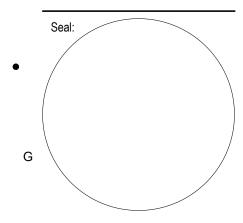

Project Phase: Design Development

Project #: 2204.01
Project Issued: June/2022
Sheet Issued: 01-05-2023

	No	Date	Revision
•			
D			
•			
_			
С			

Copyright © 2022. BSSW Architects, Inc. reserves copyright and other rights restricting these documents to the original site or purpose for which they were prepared. Reproductions, changes or assignments are prohibited.

Sheet Title: 3D Rendering

A Sheet No.

Autodesk Docs://2204.01 - Naples Playhouse Parking Garage/2204.01 - 1st Avenue S. Public Parking Garage_R-22.rvt 1/12/2023 5:48:32 PM



BSSVV

ARCHITECTS INC
License # AA C001863

L 1500 Jackson Street, Suite 200 Fort Myers, Florida 33901 Phone: 239-278-3838 Fax: 239-275-5356


949 Central Ave.
Naples, Florida 34102
Phone: 239-643-3103 Fax: 239-643-7435

Drainati

1st Avenue S. Public Parking Garage

Owner:
City of Naples

Consultant:

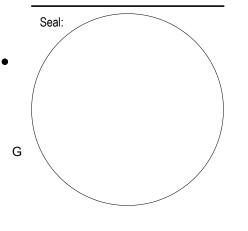

Project Phase: Design Development


Project #: 2204.01
Project Issued: June/2022
Sheet Issued: 01-05-2023

_	No	Date	Revision
)			
C			

Copyright © 2022. BSSW Architects, Inc. reserves copyright and other rights restricting these documents to the original site or purpose for which they were prepared. Reproductions, changes or assignments are prohibited.

Sheet Title: 3D Rendering

A Sheet No.

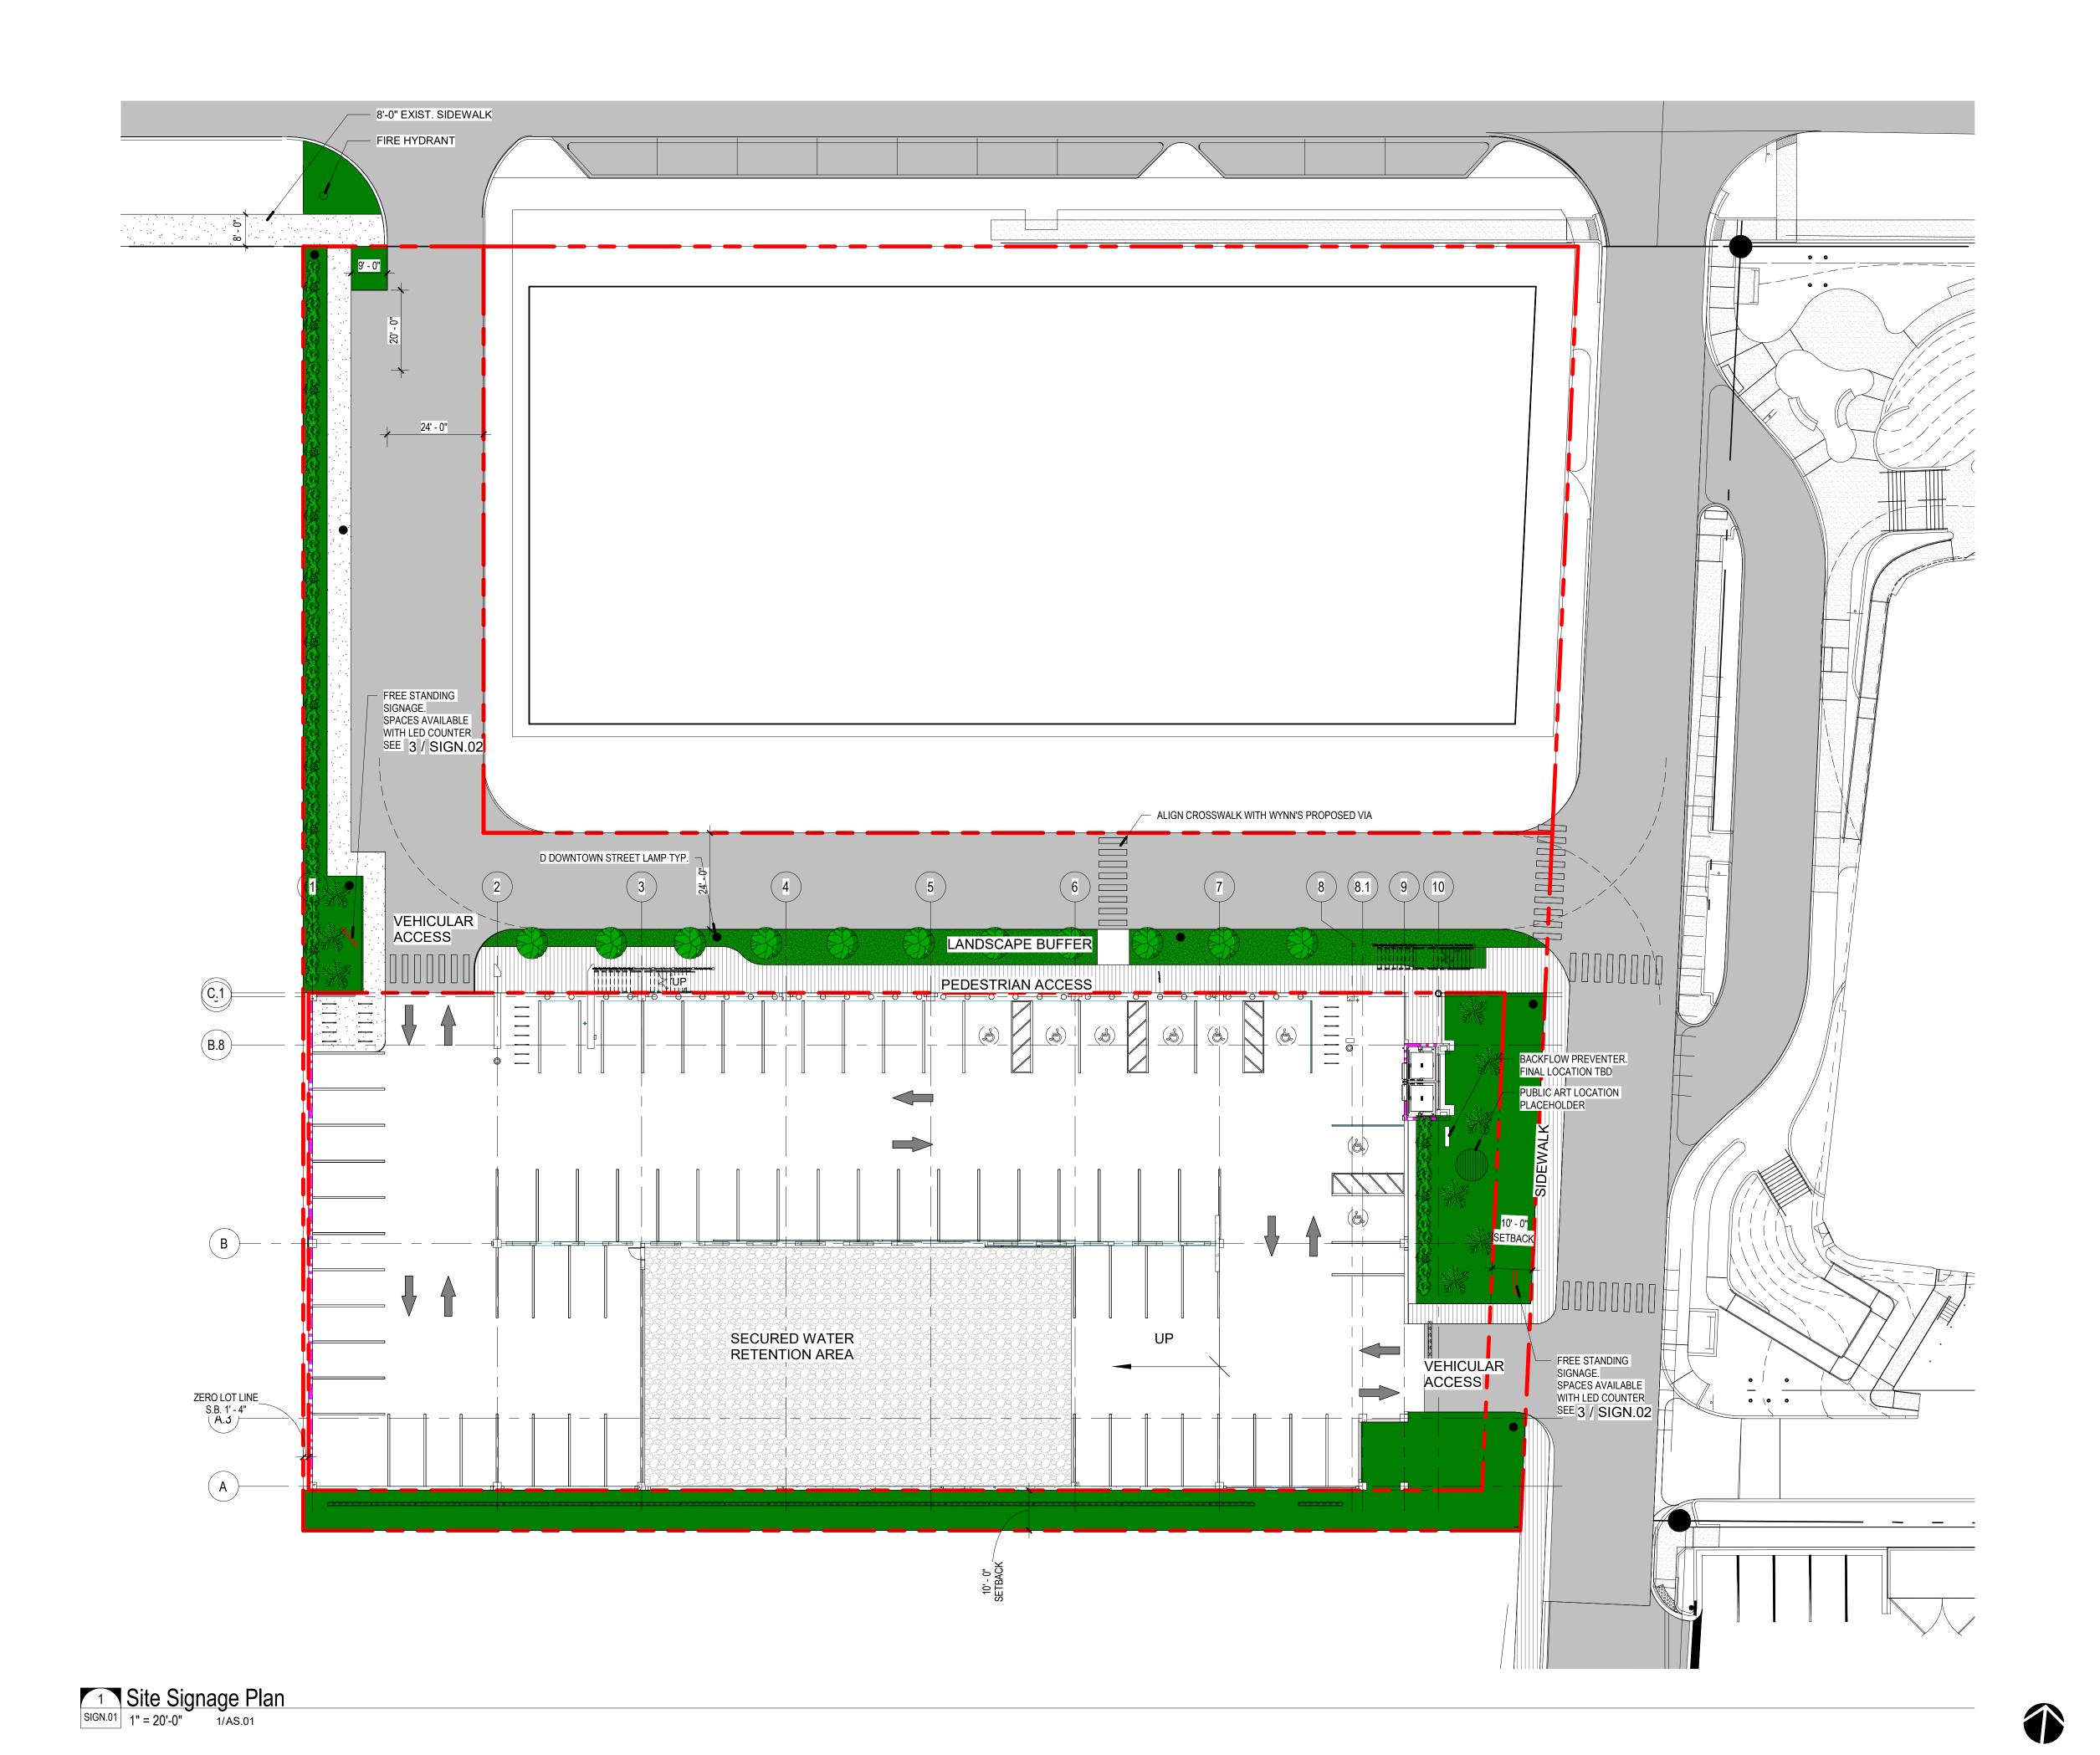



949 Central Ave.
Naples, Florida 34102
Phone: 239-643-3103 Fax: 239-643-7435

1 1 110116. 203

1st Avenue S. Public Parking Garage

Owner:
City of Naple

Concultant

Seal:

Project Phase:

Design Development

Project #: 2204.01
Project Issued: June/2022
Sheet Issued: 01-12-2023

Ξ	No	Date	Revision
)			
;			

Copyright © 2022. BSSW Architects, Inc. reserves copyright and other rights restricting these documents to the original site or purpose for which they were prepared. Reproductions,


changes or assignments are prohibited.

Sheet Title: Site Signage Plan

A Sheet No.

Autodesk Docs://2204.01 - Naples Playhouse Parking Garage/2204.01 - 1st Avenue S. Public Parking Garage_R-22.rvt 1/12/2023 6:08:18 PM

SIGN.01

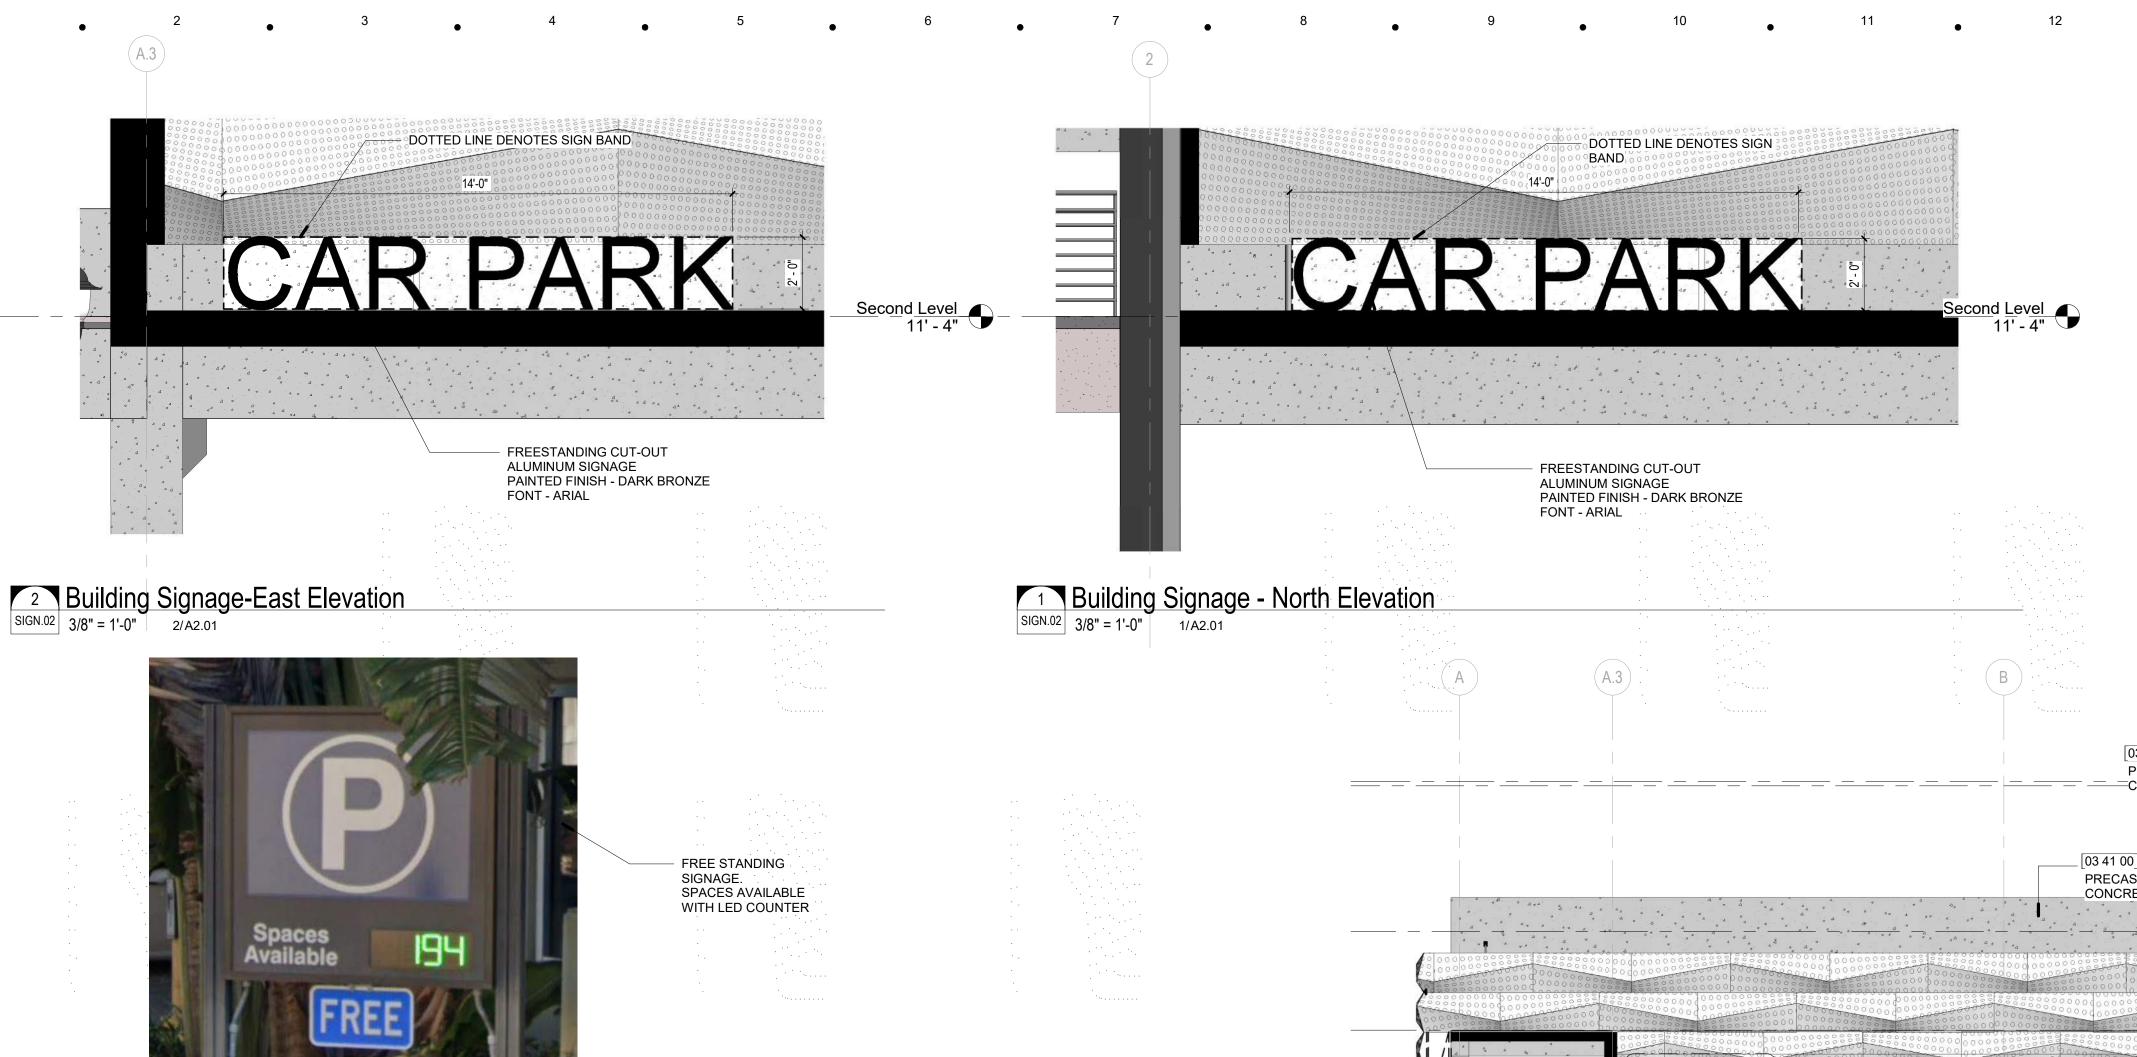

Spaces Available Signage
3 Spaces Available Signage
3 3" = 1'-0"

5 North Elevation Signage

SIGN.02 3/32" = 1'-0" 11/A1.01

03 41 00____ PRECAST STRUCTURAL Room 49' - 6" METAL WALL PANELS <u>T.O. Stair Tower</u> 44' - 11" 03 41 00 PRECAST STRUCTURAL T.O.Parapet 37' - 1" _CONCRETE Roof Level 33' - 4" Third Level 22' - 4" CAR PARK Second Level 11' - 4" 10 14 23.15 10 73 13 ŞIGN.02 METAL AWNINGS **BUILDING SIGN** Ground Level 07 41 13 GLAZED ALUMINUM CURTAIN BICYCLE RACKS METAL ROOF PANELS WALLS 4 East Elevation Signage
SIGN.02 3/32" = 1'-0" 11/A1.01

05 58 00.A1

07 42 13

ALUMINUM COLUMN COVER

(8.1) 1Max. Height Allowed 50' - 0" T.O Elev. Machine Room 49' - 6" T.O. Stair Tower 44' - 11" _ 03 41 00____ PRECAST STRUCTURAL CONCRETE 07 42 13 07 42 13 07 41 13 05 52 13 05 58 00.A1 METAL WALL PANELS METAL WALL PANELS METAL ROOF PANELS | PIPE AND TUBE RAILINGS ALUMINUM COLUMN COVER T.O.Parapet 37' - 1" Roof Level 33' - 4" 07 41 13 METAL ROOF PANELS Third Level 22' - 4" CAR PARK Second Level 11' - 4" 10 14 23.15 **BUILDING SIGN** Ground Level ____[12 93 13 [12 93 13] BICYCLE RACKS __[12 93 13 _____ 6.75' N.A.V.D __[32 31 10____ BOLLARD BICYCLE RACKS BICYCLE RACKS

A Sheet No.

License # AA C001863

1500 Jackson Street, Suite 200 Fort Myers, Florida 33901 Phone: 239-278-3838 Fax: 239-275-5356

949 Central Ave. Naples, Florida 34102


Consultant:

Max. Height Allowed
T.O Elev. Machine

Autodesk Docs://2204.01 - Naples Playhouse Parking Garage/2204.01 - 1st Avenue S. Public Parking Garage_R-22.rvt 1/12/2023 6:08:57 PM

1st Avenue S. **Public Parking** Garage

City of Naples

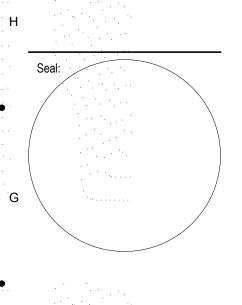

Project Phase: Design Development


Project #: 2204.01 Project Issued: June/2022 Sheet Issued: 01-12-2023

Date

Copyright © 2022. BSSW Architects, Inc. reserves copyright and other rights restricting these documents to the original site or purpose for which they were prepared. Reproductions, changes or assignments are

Sheet Title: Exterior Details

SIGN.02

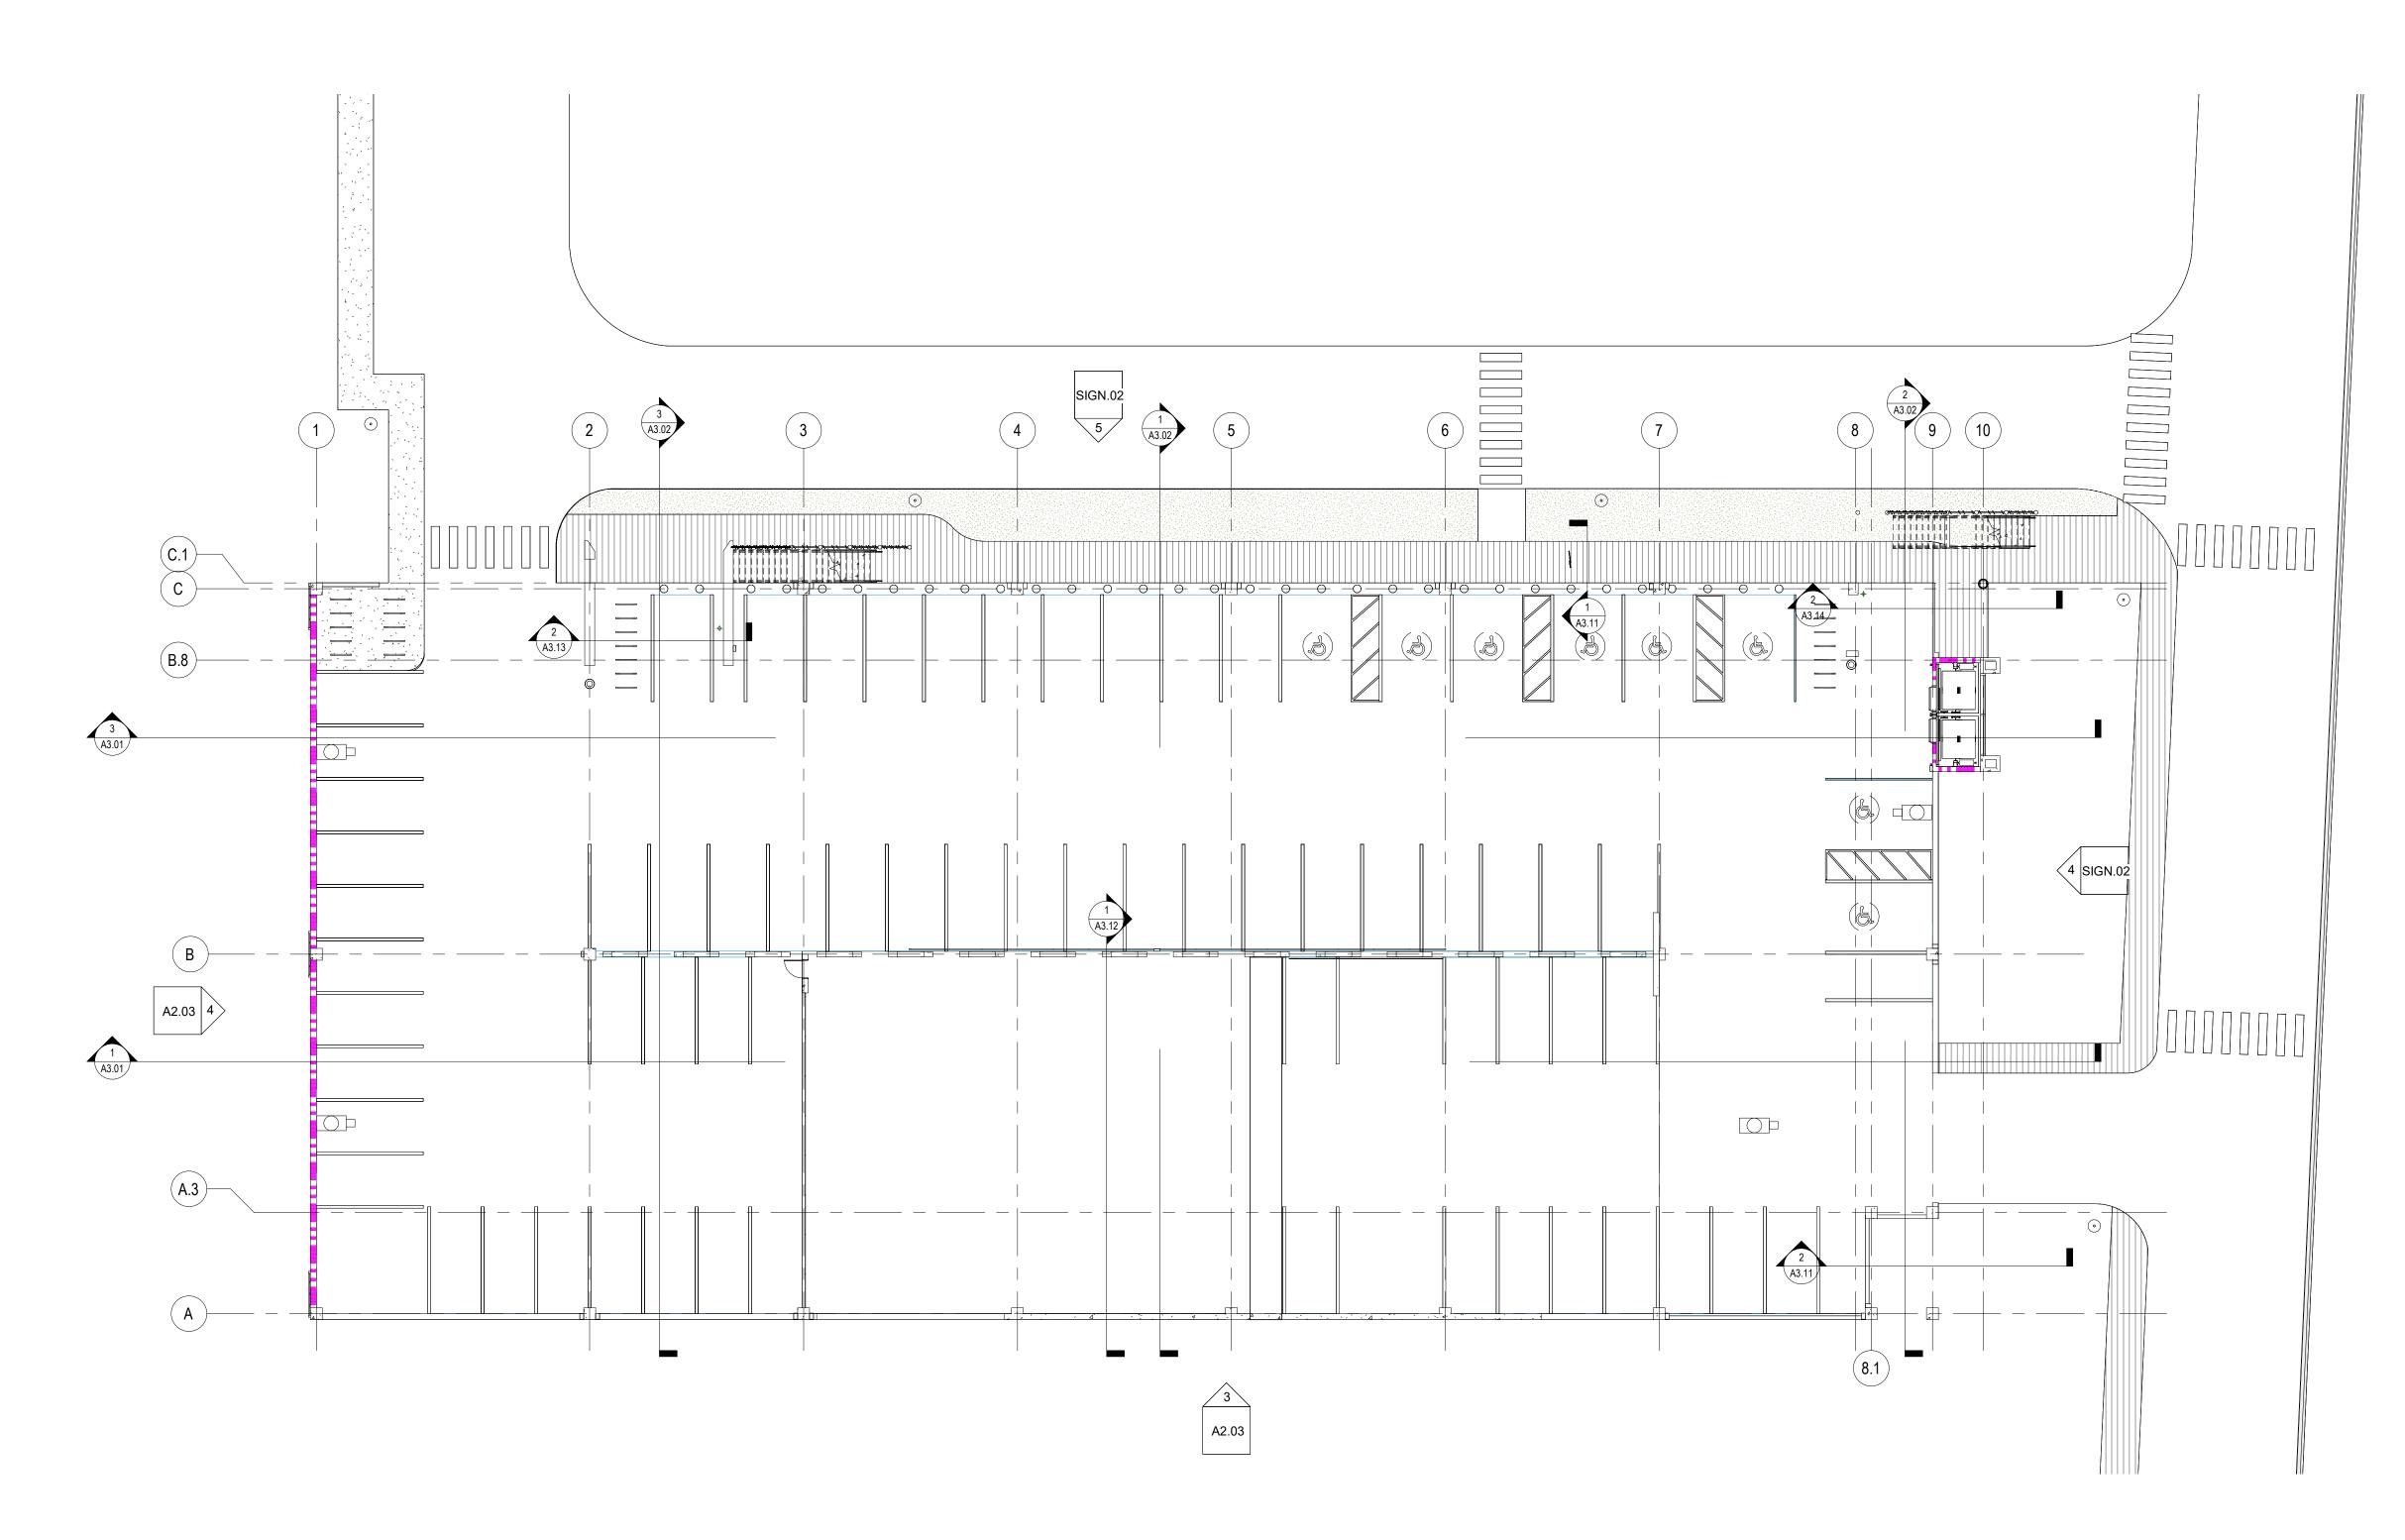



LEGEND

DESCRIPTION CCTV CAMERA

GENERAL NOTES

CAMERA LOCATIONS ARE APPROXIMATE. THE CONTRACTOR SHALL COORDINATE THE EXACT LOCATION AND COVERAGE AREA OF EACH CAMERA WITH THE OWNER'S DESIGNATED REPRESENTATIVE PRIOR TO INSTALLATION. CAMERA FIELDS OF VIEW SHALL BE COORDINATED WITH AND APPROVED BY THE OWNER WITH THE USE OF A HANDHELD VIEWFINDER (CHUGAI VM300 OR EQUIVALENT) TO DETERMINE THE BEST LENS AND CAMERA ANGLE. FINAL CAMÉRA LOCATIONS SHALL BE ABLE TO MOVE UP TO 30 FEET FROM LOCATION SHOWN WITHOUT ADDITIONAL COST. PARTICULAR ATTENTION SHALL BE GIVEN TO COORDINATION OF CAMERA LOCATIONS RELATIVE TO ANY OBSTRUCTIONS, AND OTHER CAMERA VIEWS. AFTER FINAL


LOCATION IS DETERMINED AND THE SYSTEM IS IN

OPERATION, CONTRACTOR SHALL COORDINATE WITH OWNER FOR EXACT CAMERA ANGLES AND LENS SETTINGS. A R C H I T E C T S I N C License # AA C001863

1500 Jackson Street, Suite 200 Fort Myers, Florida 33901 Phone: 239-278-3838 Fax: 239-275-5356

949 Central Ave.
Naples, Florida 34102
Phone: 239-643-3103 Fax: 239-643-7435

1st Avenue S. **Public Parking** Garage

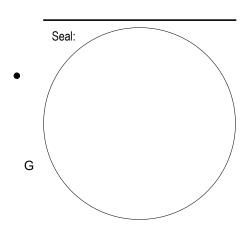

Design Development


Project #: 2204.01 Project Issued: June/2022 Sheet Issued: 01-12-2023

Ε	No	Date	Revision
•			
D			
_			
•			
С			
•			

Copyright © 2022. BSSW Architects, Inc. reserves copyright and other rights restricting these documents to the original site or purpose for which they were prepared. Reproductions, changes or assignments are

Ground Level - CCTV Camera Location Plan

Sheet No.

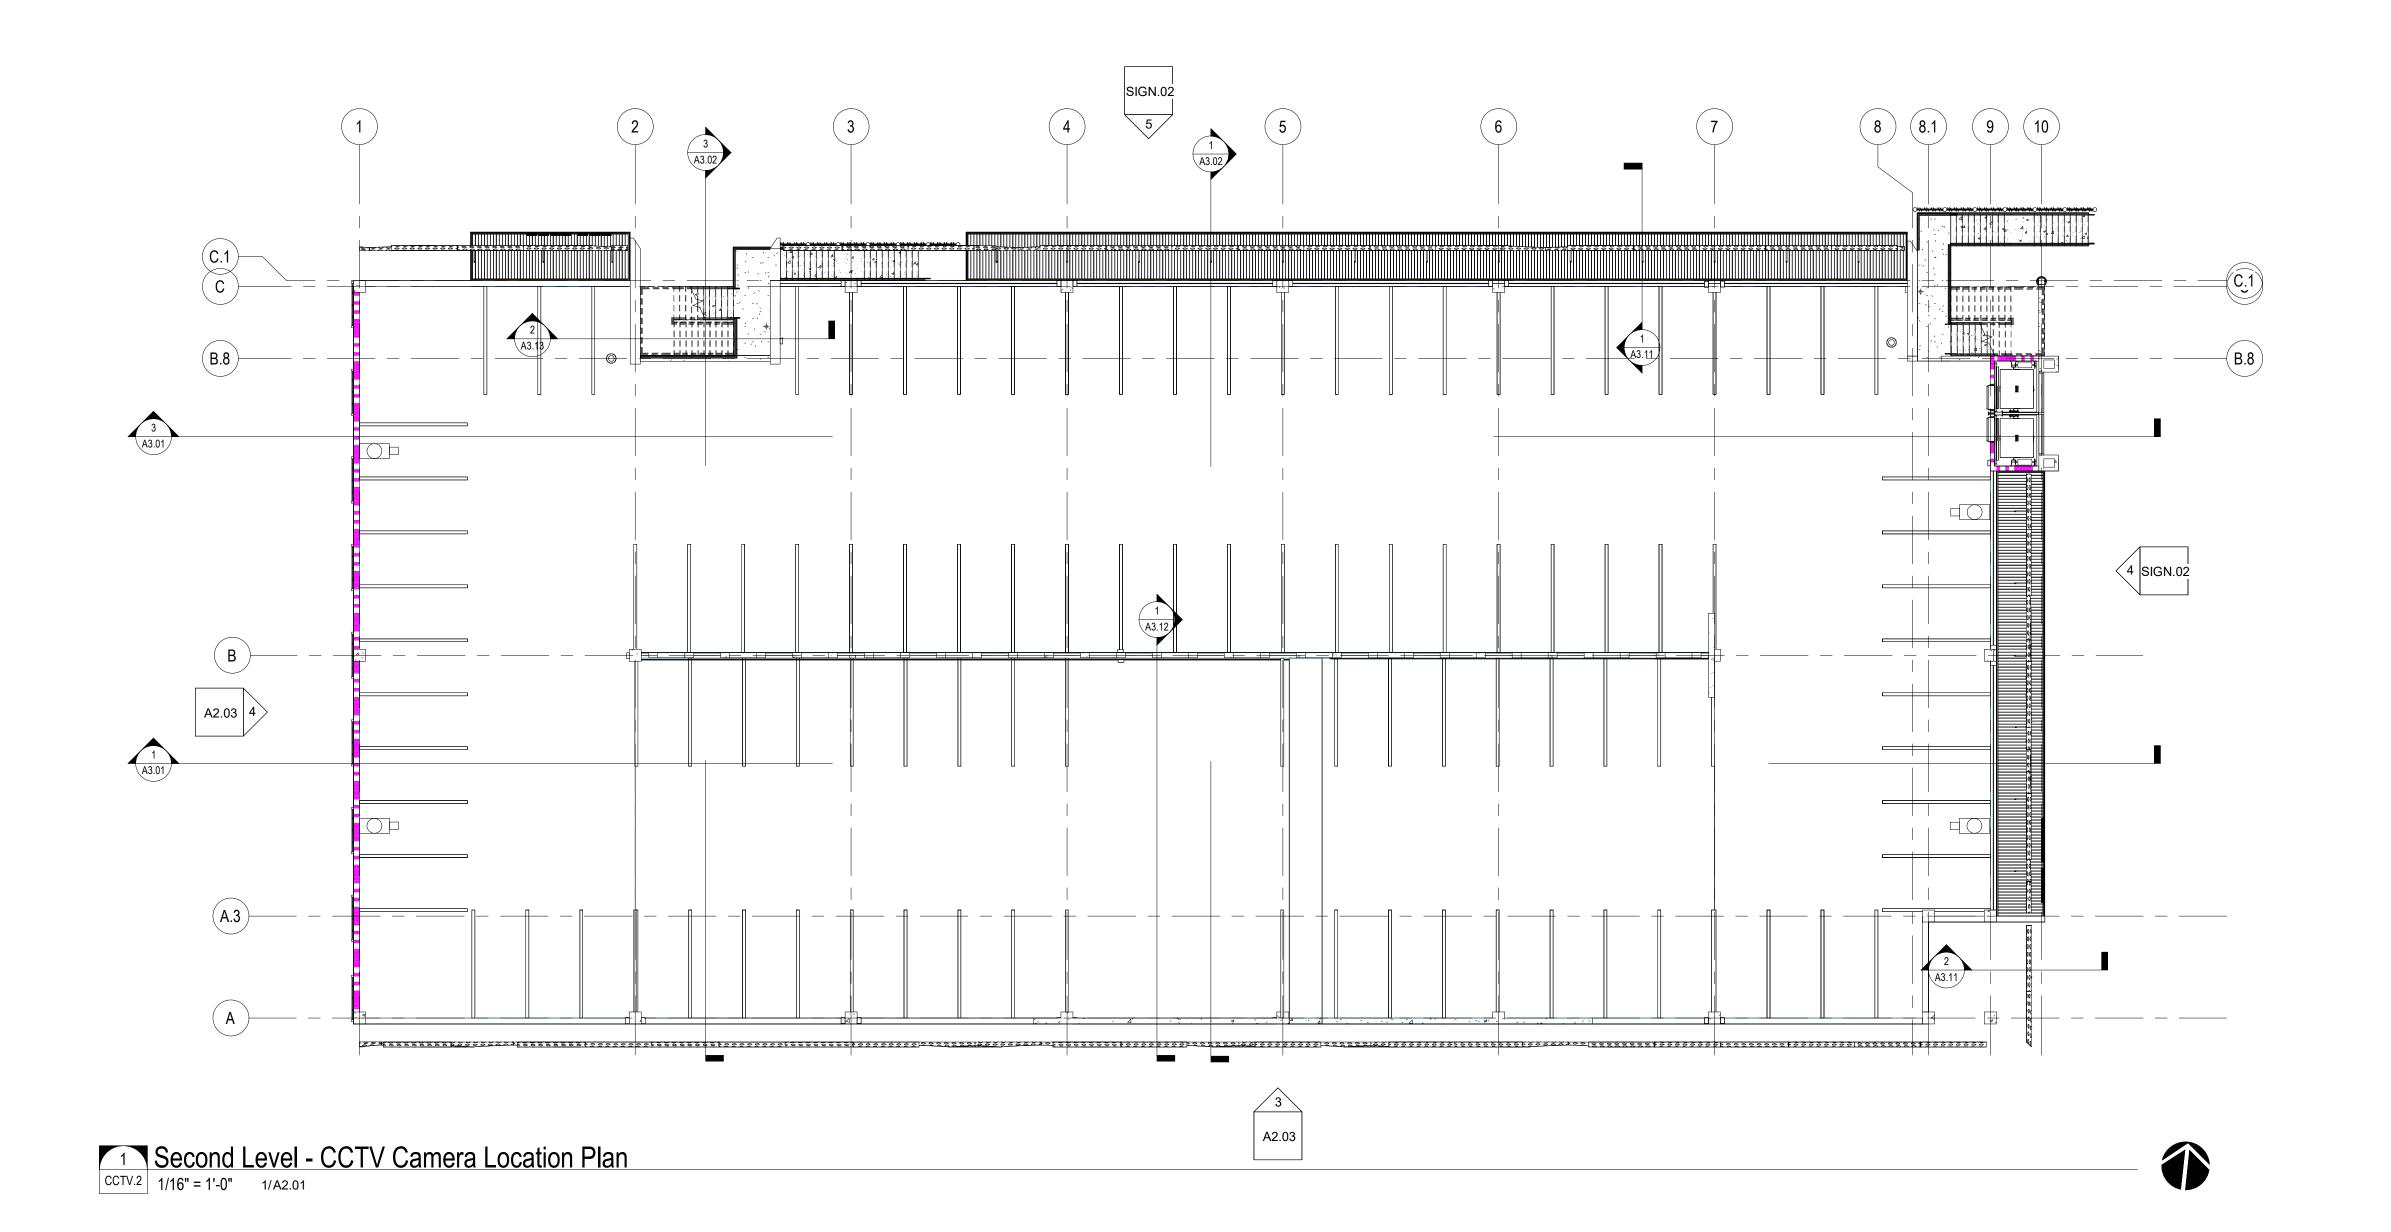

A R C H I T E C T S I N C License # AA C001863


1500 Jackson Street, Suite 200 Fort Myers, Florida 33901 Phone: 239-278-3838 Fax: 239-275-5356

949 Central Ave.
Naples, Florida 34102
Phone: 239-643-3103 Fax: 239-643-7435

1st Avenue S. Public Parking Garage

Owner:
City of Naples

Consultant:

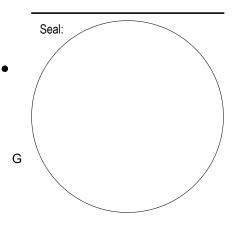

Project Phase: Design Development

Project #: 2204.01
Project Issued: June/2022
Sheet Issued: 01-12-2023

Е	No	Date	Revision
•			
D			
•			
С			

LEGEND

SYMBOL

GENERAL NOTES

DESCRIPTION

CCTV CAMERA

TO INSTALLATION. CAMERA FIELDS OF VIEW SHALL BE

LOCATION IS DETERMINED AND THE SYSTEM IS IN OPERATION, CONTRACTOR SHALL COORDINATE

CAMERA LOCATIONS ARE APPROXIMATE. THE CONTRACTOR SHALL COORDINATE THE EXACT LOCATION AND COVERAGE AREA OF EACH CAMERA WITH THE OWNER'S DESIGNATED REPRESENTATIVE PRIOR

COORDINATED WITH AND APPROVED BY THE OWNER WITH THE USE

LOCATIONS SHALL BE ABLE TO MOVE UP TO 30 FEET FROM LOCATION

SHOWN WITHOUT ADDITIONAL COST. PARTICULAR ATTENTION SHALL BE GIVEN TO COORDINATION OF CAMERA LOCATIONS RELATIVE TO ANY OBSTRUCTIONS, AND OTHER CAMERA VIEWS. AFTER FINAL

OF A HANDHELD VIEWFINDER (CHUGAI VM300 OR EQUIVALENT) TO

DETERMINE THE BEST LENS AND CAMERA ANGLE. FINAL CAMERA

WITH OWNER FOR EXACT CAMERA ANGLES AND LENS SETTINGS.

Copyright © 2022. BSSW Architects, Inc. reserves copyright and other rights restricting these documents to the original site or purpose for which they were prepared. Reproductions,


changes or assignments are prohibited.

Second Level - CCTV

• Camera Location Plan

Autodesk Docs://2204.01 - Naples Playhouse Parking Garage/2204.01 - 1st Avenue S. Public Parking Garage_R-22.rvt 1/12/2023 6:03:23 PM

CCTV.2

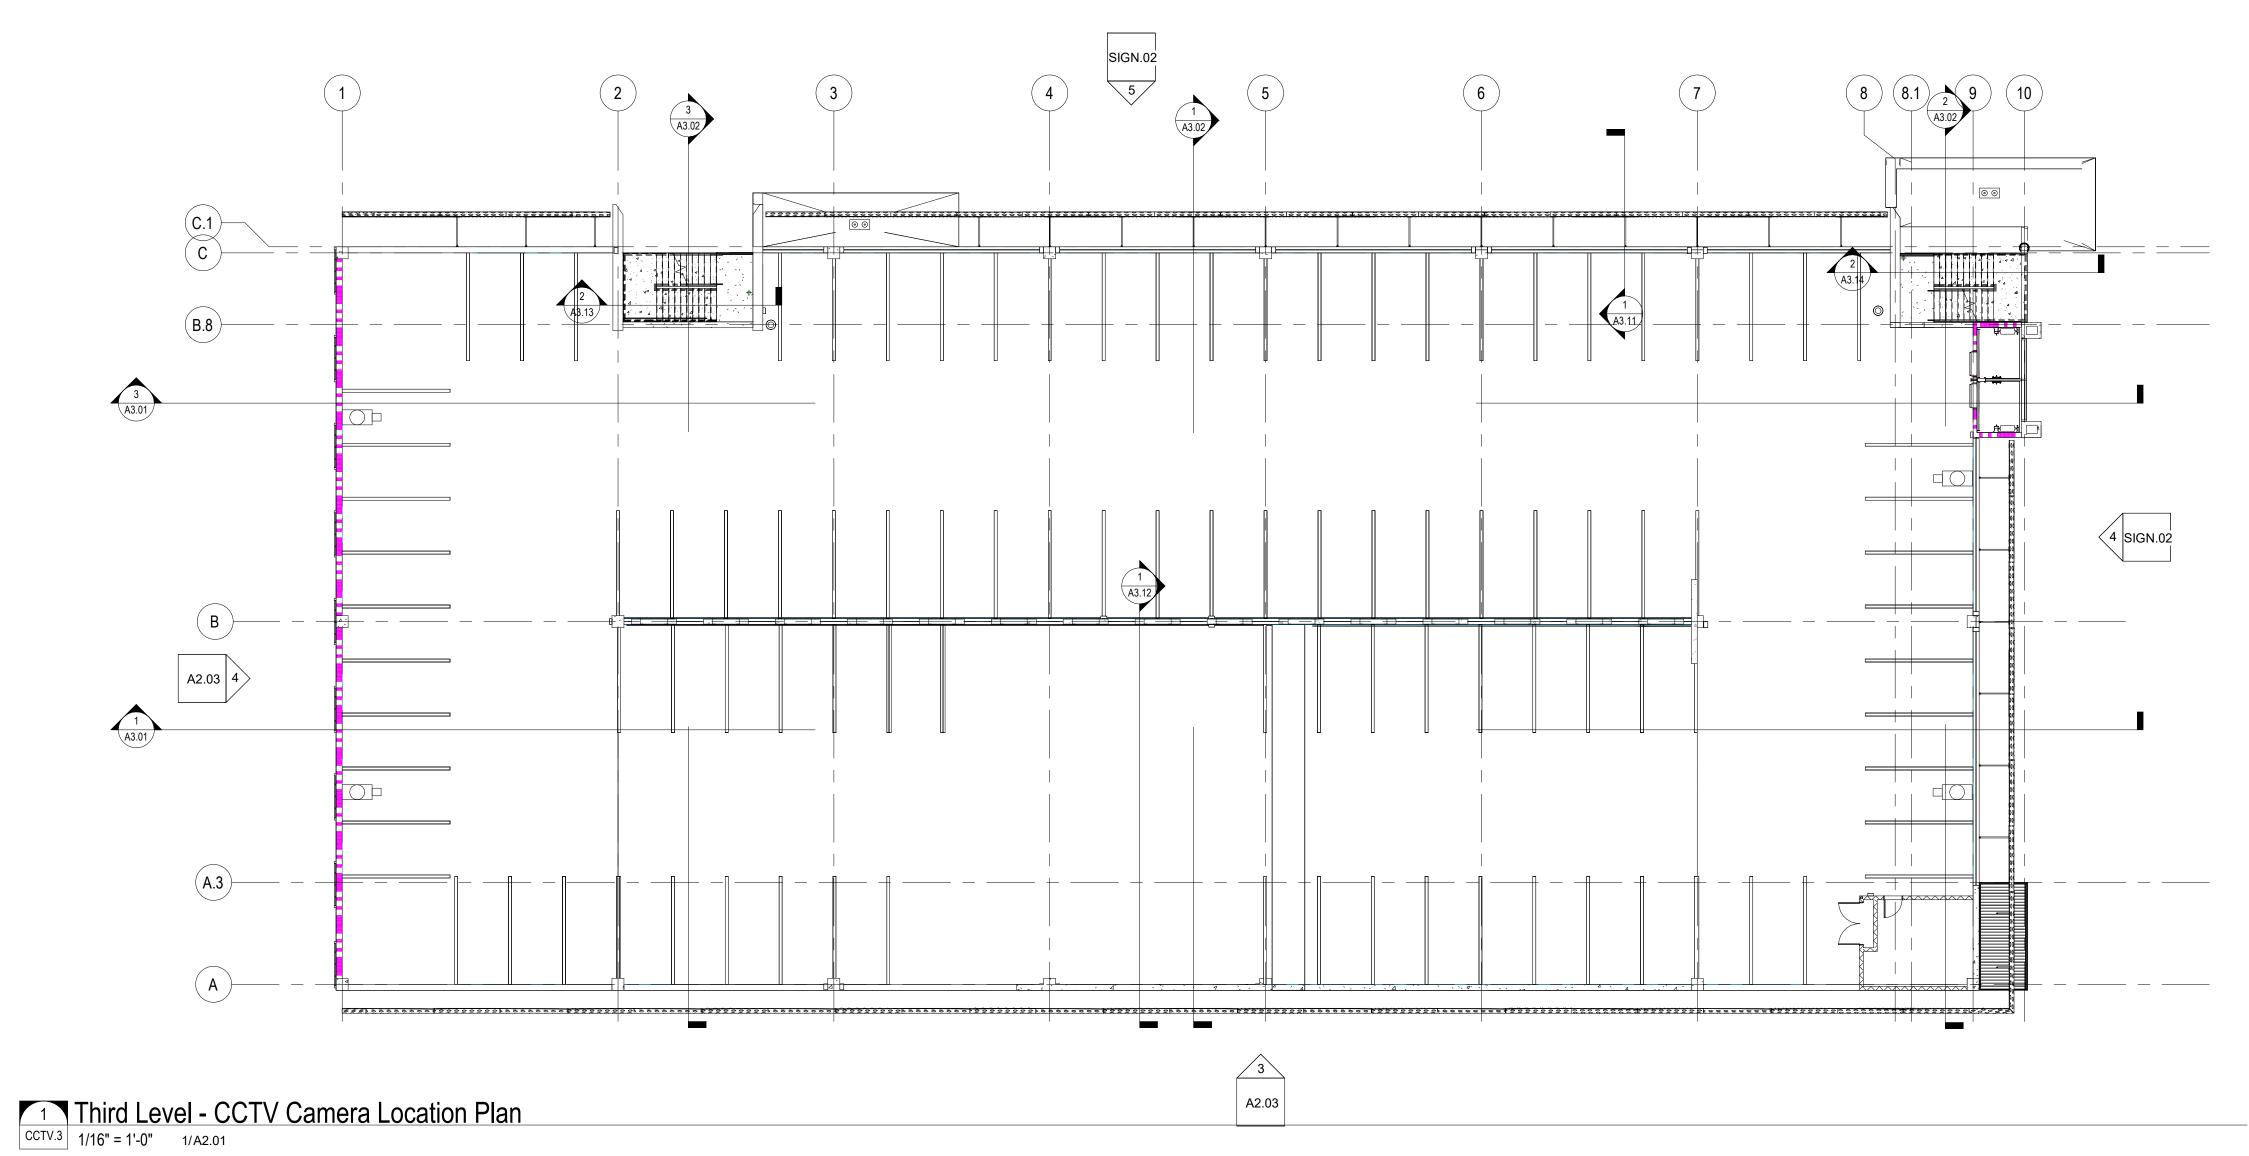

1

SYMBOL

LEGEND

OL DESCRIPTION

CCTV CAMERA

GENERAL NOTES

CAMERA LOCATIONS ARE APPROXIMATE. THE CONTRACTOR SHALL COORDINATE THE EXACT LOCATION AND COVERAGE AREA OF EACH CAMERA WITH THE OWNER'S DESIGNATED REPRESENTATIVE PRIOR TO INSTALLATION. CAMERA FIELDS OF VIEW SHALL BE COORDINATED WITH AND APPROVED BY THE OWNER WITH THE USE OF A HANDHELD VIEWFINDER (CHUGAI VM300 OR EQUIVALENT) TO DETERMINE THE BEST LENS AND CAMERA ANGLE. FINAL CAMERA LOCATIONS SHALL BE ABLE TO MOVE UP TO 30 FEET FROM LOCATION SHOWN WITHOUT ADDITIONAL COST. PARTICULAR ATTENTION SHALL BE GIVEN TO COORDINATION OF CAMERA LOCATIONS RELATIVE TO ANY OBSTRUCTIONS, AND OTHER CAMERA VIEWS. AFTER FINAL LOCATION IS DETERMINED AND THE SYSTEM IS IN OPERATION, CONTRACTOR SHALL COORDINATE

WITH OWNER FOR EXACT CAMERA ANGLES AND LENS SETTINGS.

BSSVV

ARCHITECTSINC

License # AA C001863

1500 Jackson Street, Suite 200 Fort Myers, Florida 33901 Phone: 239-278-3838 Fax: 239-275-5356


949 Central Ave.
Naples, Florida 34102
Phone: 239-643-3103 Fax: 239-643-7435

Drainati

1st Avenue S. Public Parking Garage

Owner:
City of Naples

Consultant:

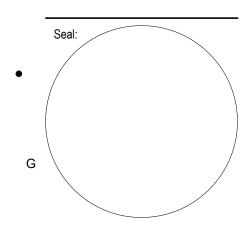

Design Development


Project #: 2204.01
Project Issued: June/2022
Sheet Issued: 01-12-2023

Е	No	Date	Revision
•			
D			
•			
С			

Copyright © 2022. BSSW Architects, Inc. reserves copyright and other rights restricting these documents to the original site or purpose for which they were prepared. Reproductions, changes or assignments are

sheet Title:
Third Level - CCTV


Third Level - CCTV
 Camera Location Plan

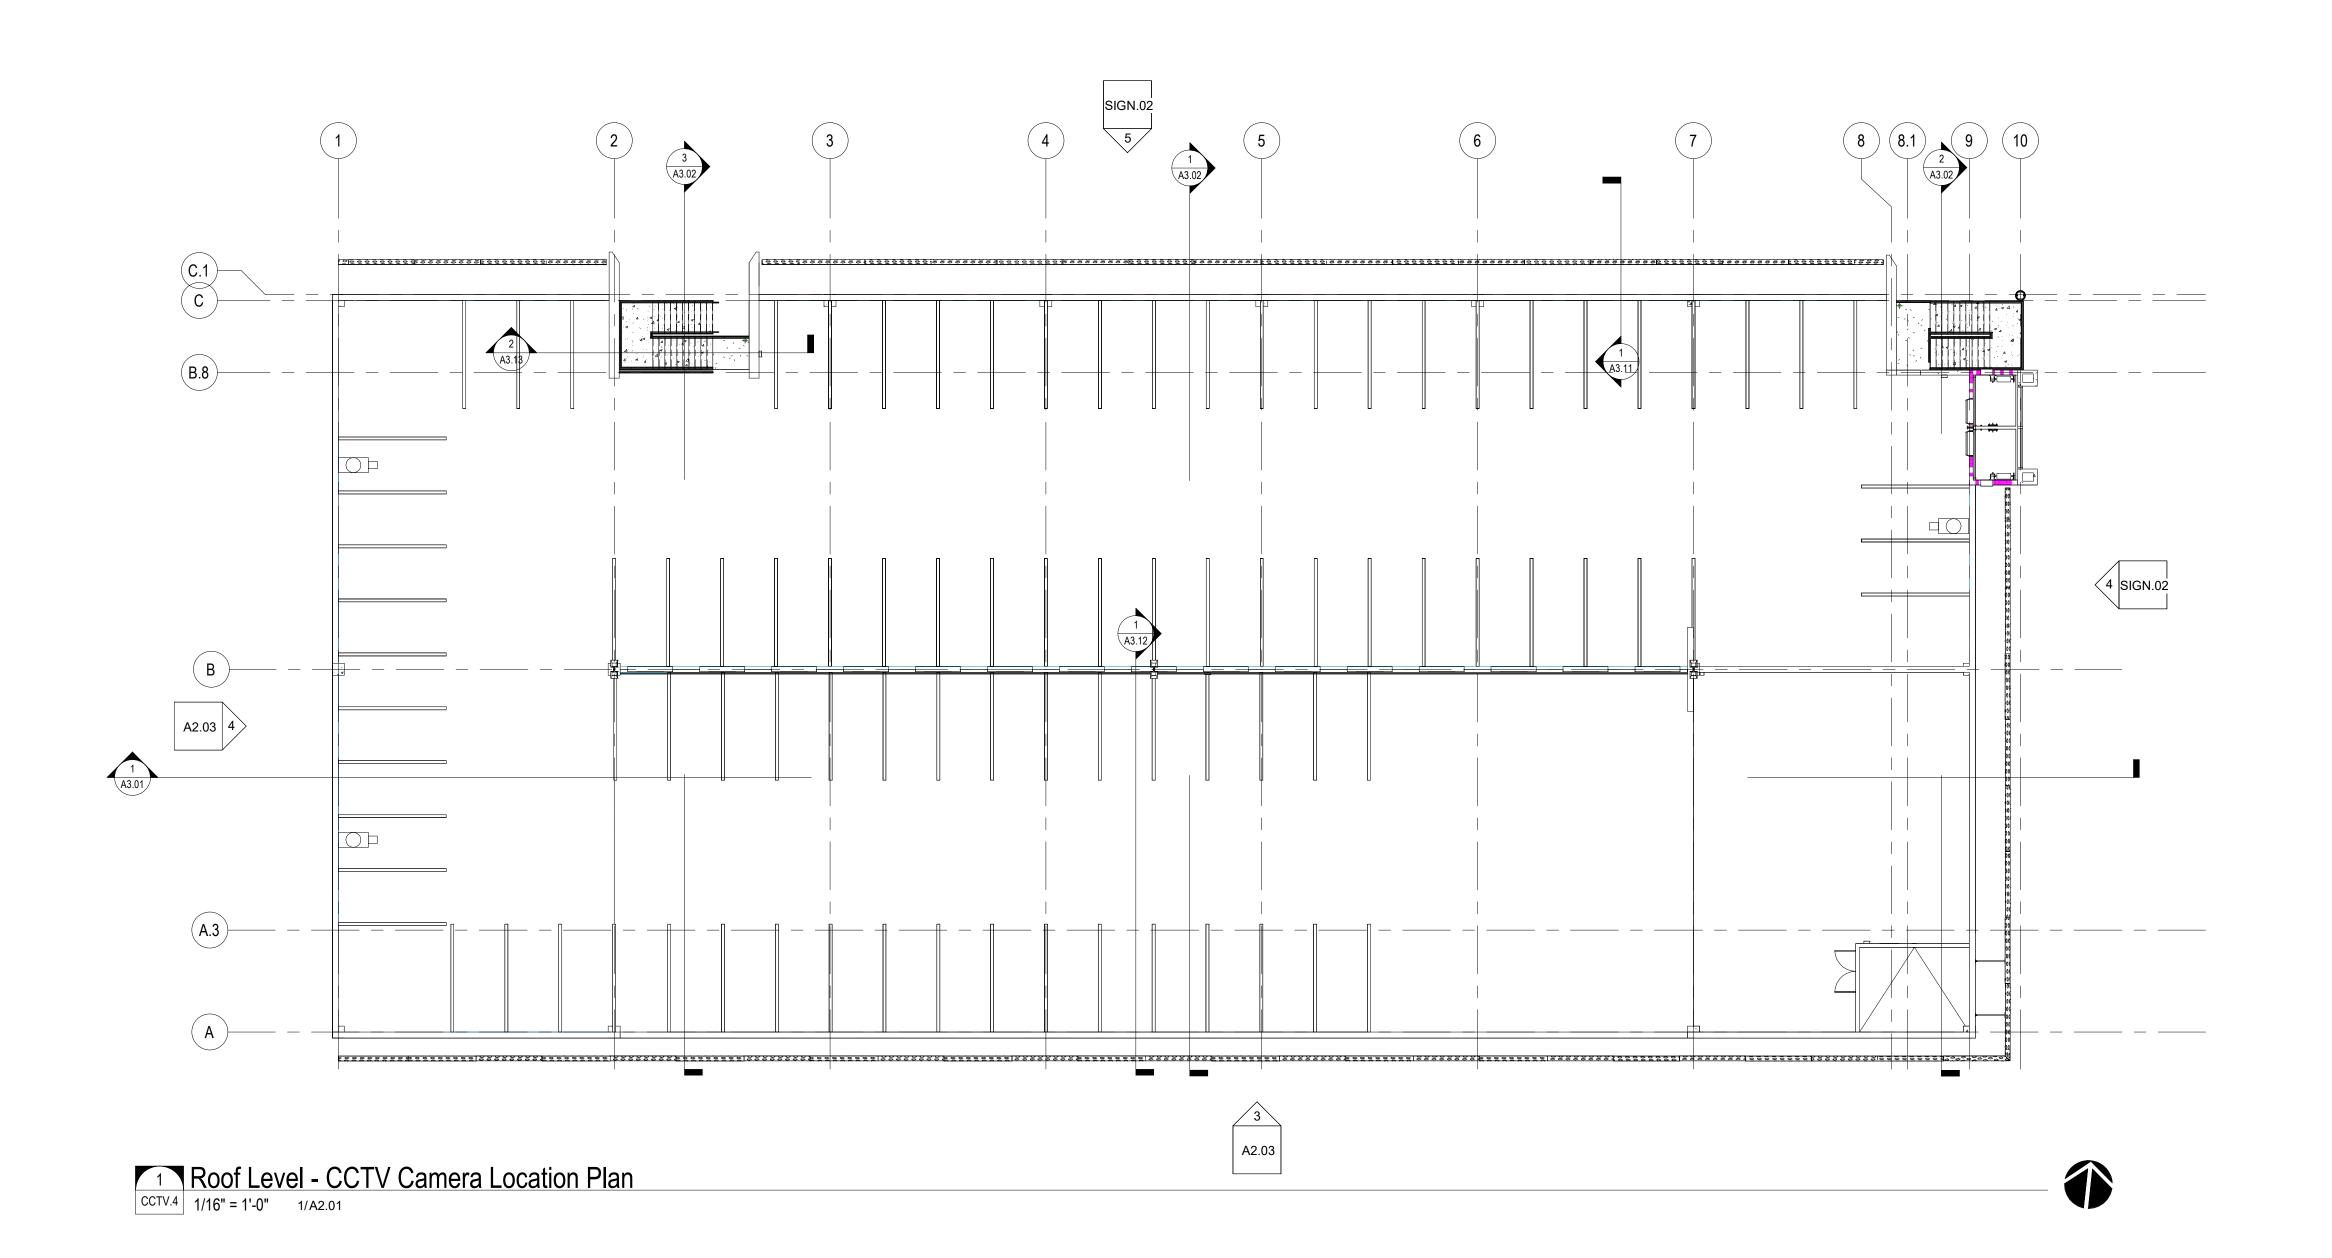

License # AA C001863

949 Central Ave.
Naples, Florida 34102
Phone: 239-643-3103 Fax: 239-643-7435

1st Avenue S. **Public Parking** Garage

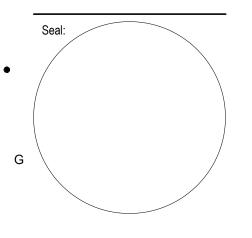

Design Development

Project #: 2204.01 Project Issued: June/2022 Sheet Issued: 01-12-2023

Е	No	Date	Revision
•			
D			
•			
С			
Ü			

Copyright © 2022. BSSW Architects, Inc. reserves copyright and other rights restricting these documents to the original site or purpose for which they were prepared. Reproductions, changes or assignments are

Sheet Title: Roof Level - CCTV Camera Location Plan

LEGEND

GENERAL NOTES

DESCRIPTION

CCTV CAMERA

TO INSTALLATION. CAMERA FIELDS OF VIEW SHALL BE

LOCATION IS DETERMINED AND THE SYSTEM IS IN OPERATION, CONTRACTOR SHALL COORDINATE

CAMERA LOCATIONS ARE APPROXIMATE. THE CONTRACTOR SHALL

COORDINATE THE EXACT LOCATION AND COVERAGE AREA OF EACH CAMERA WITH THE OWNER'S DESIGNATED REPRESENTATIVE PRIOR

COORDINATED WITH AND APPROVED BY THE OWNER WITH THE USE OF A HANDHELD VIEWFINDER (CHUGAI VM300 OR EQUIVALENT) TO DETERMINE THE BEST LENS AND CAMERA ANGLE. FINAL CAMERA LOCATIONS SHALL BE ABLE TO MOVE UP TO 30 FEET FROM LOCATION SHOWN WITHOUT ADDITIONAL COST. PARTICULAR ATTENTION SHALL BE GIVEN TO COORDINATION OF CAMERA LOCATIONS RELATIVE TO ANY OBSTRUCTIONS, AND OTHER CAMERA VIEWS. AFTER FINAL

WITH OWNER FOR EXACT CAMERA ANGLES AND LENS SETTINGS.